






PLEASE NOTE THAT THE DETAILS SHOWN ON THIS PAGE ARE FOR GENERAL REFERENCE ONLY AND MAY NOT BE APPLICABLE FOR THIS PARTICULAR PROJECT.

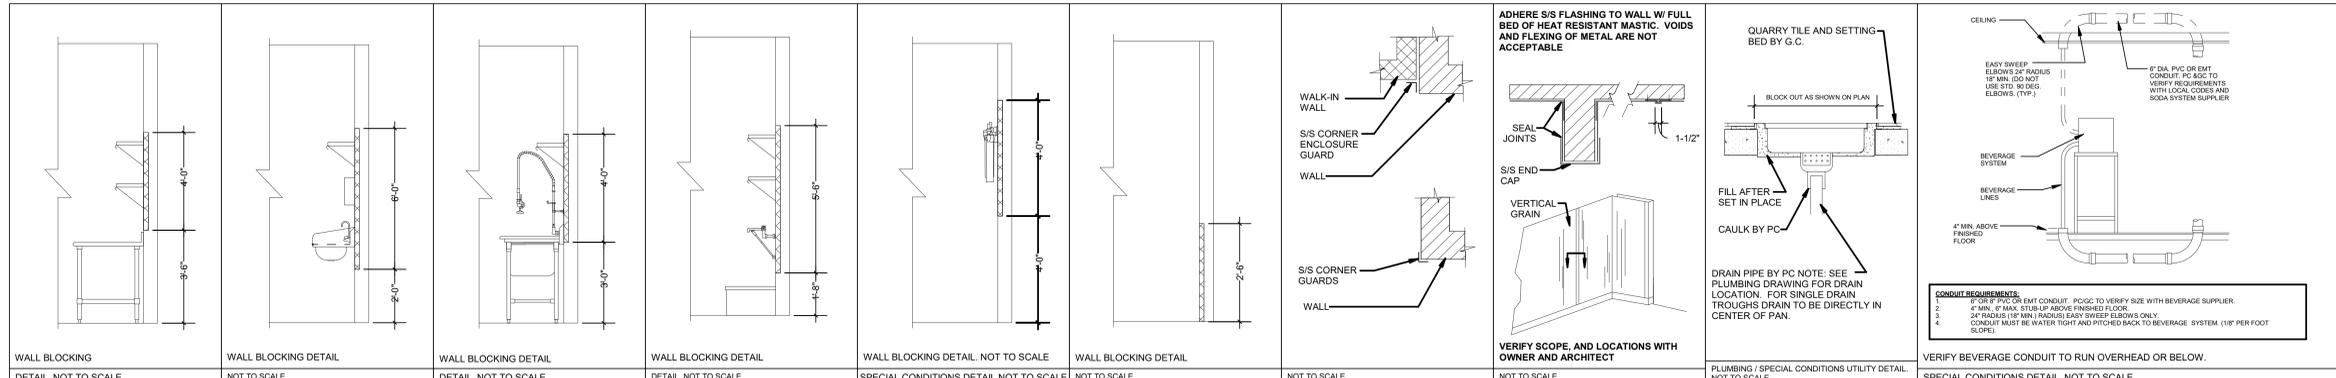


01	Wall Shelving Backing	02	Hand Sink	03	Pre-Rinse Bracket	04	MOP SINK & SHELVES	05	WATER FILTER	06	Wall Backing As Noted	07	S/S CORNER GUARDS & ENCLOSURE STRIPS	08	S/S WALL PANELS	09	TROUGH DETAIL	10	BEVERAGE CONDUIT
----	-----------------------	----	-----------	----	-------------------	----	--------------------	----	--------------	----	-----------------------	----	--------------------------------------	----	-----------------	----	---------------	----	------------------

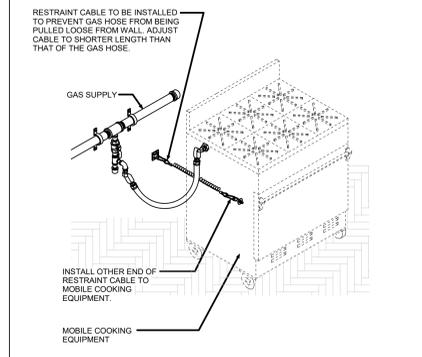


11 Quick Disconnect Hose Detail

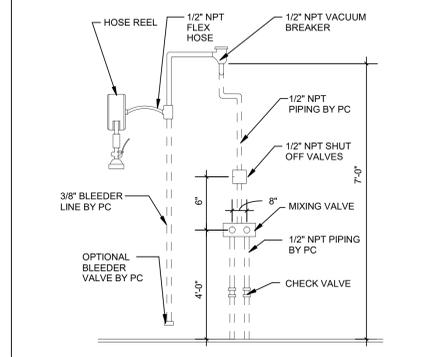


12 HOSE REEL DETAIL

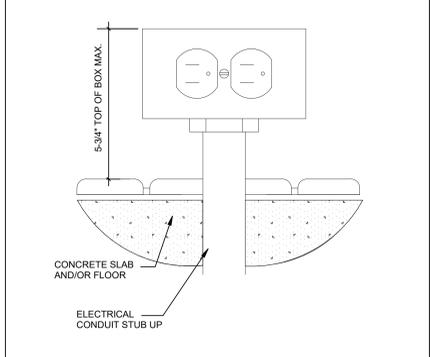

13 FLOOR MTD RECEPTACLE

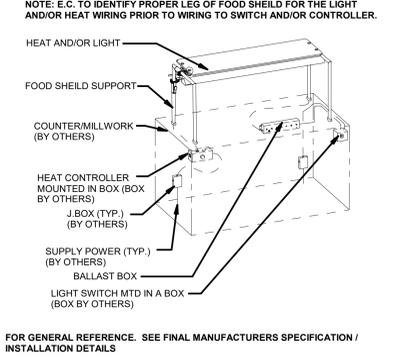

14 SNEEZE GUARD HEAT AND/OR LIGHT WIRING DETAIL

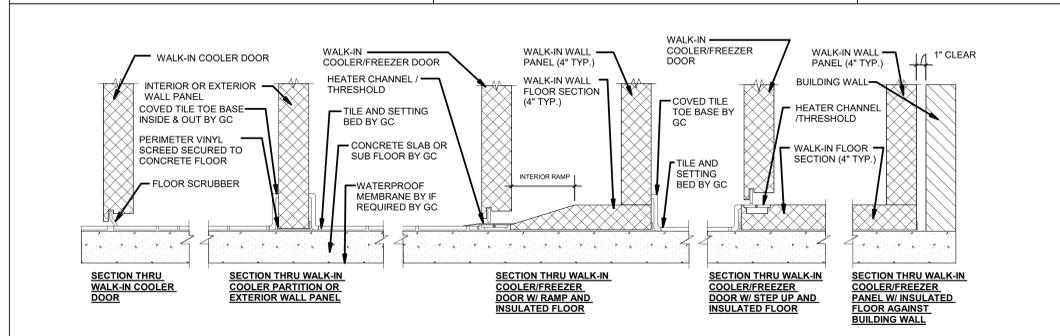

THESE ARE TYPICAL WALK-IN CROSS SECTIONS FOR WALK-INS INSTALLED WITHOUT A DEPRESSED SLAB. PLEASE NOTE THAT THESE CROSS SECTIONS ARE FOR REFERENCE ONLY AND MAY NOT BE APPLICABLE FOR THIS PARTICULAR PROJECT. PLEASE SEE FINAL APPROVED MANUFACTURERS DRAWINGS.

15 WALKING DETAIL: WALK-IN PLACED ATOP SLAB/SUBFLOOR W/ TILE FLOOR IN WALK-IN COOLER AND/OR TILE TERMINATING INTO WALK-IN PANEL

**Singer Equipment Company**  
 180 Heller Place,  
 Bellmawr, NJ  
 08030  
 856-559-4200

COPYRIGHT, THESE DOCUMENTS IN PART OR IN WHOLE, AND THE DESIGN THEY REPRESENT, ARE THE SOLE PROPERTY OF SINGER EQUIPMENT COMPANY. THESE DOCUMENTS ARE INTENDED FOR THE PROJECT ON SITE INDICATED. ANY USE, REPRODUCTION, MODIFICATION OR ADOPTION WITHOUT THE EXPRESS WRITTEN CONSENT OF SINGER EQUIPMENT COMPANY IS STRICTLY PROHIBITED.

**JOB NAME:**  
**Sanctuary Golf**

**ADDRESS:**  
 25191 Chamber of Commerce Dr  
 Bonita Springs  
 FL 34135

**PROJECT #:** ---  
**DRAWN BY:** JL  
**CHECKED BY:** XXX

SUBMITTALS & REVISIONS		
REV	DATE	DESCRIPTION
07-22-25		Design development
07-25-25		Design development
08-04-25		Full Set
1	08-19-25	JL Revisions per owner

**SHEET NAME:**  
**Details**

**SCALE:**

**DRAWING SHEET NO.**  
**FS0.01**



Singer Equipment Company

180 Heller Place, Bellmawr, NJ 08030

856-559-4200

COPYRIGHT, THESE DOCUMENTS IN PART OR IN WHOLE, AND THE DESIGN THEY REPRESENT, ARE THE SOLE PROPERTY OF SINGER EQUIPMENT COMPANY. THESE DOCUMENTS ARE INTENDED FOR THE PROJECT ON SITE INDICATED. ANY USE, REPRODUCTION, MODIFICATION OR ADOPTION WITHOUT THE EXPRESS WRITTEN CONSENT OF SINGER EQUIPMENT COMPANY IS STRICTLY PROHIBITED.

JOB NAME: Sanctuary Golf

ADDRESS: 25191 Chamber of Commerce Dr Bonita Springs, FL 34135


PROJECT #: -- DRAWN BY: JL CHECKED BY: XXX

Table with 3 columns: REV, DATE, NAME, DESCRIPTION. Revisions per owner.




SHEET NAME: Equipment & Schedule

SCALE: 1/4" = 1'-0"

DRAWING SHEET NO. FS1.10

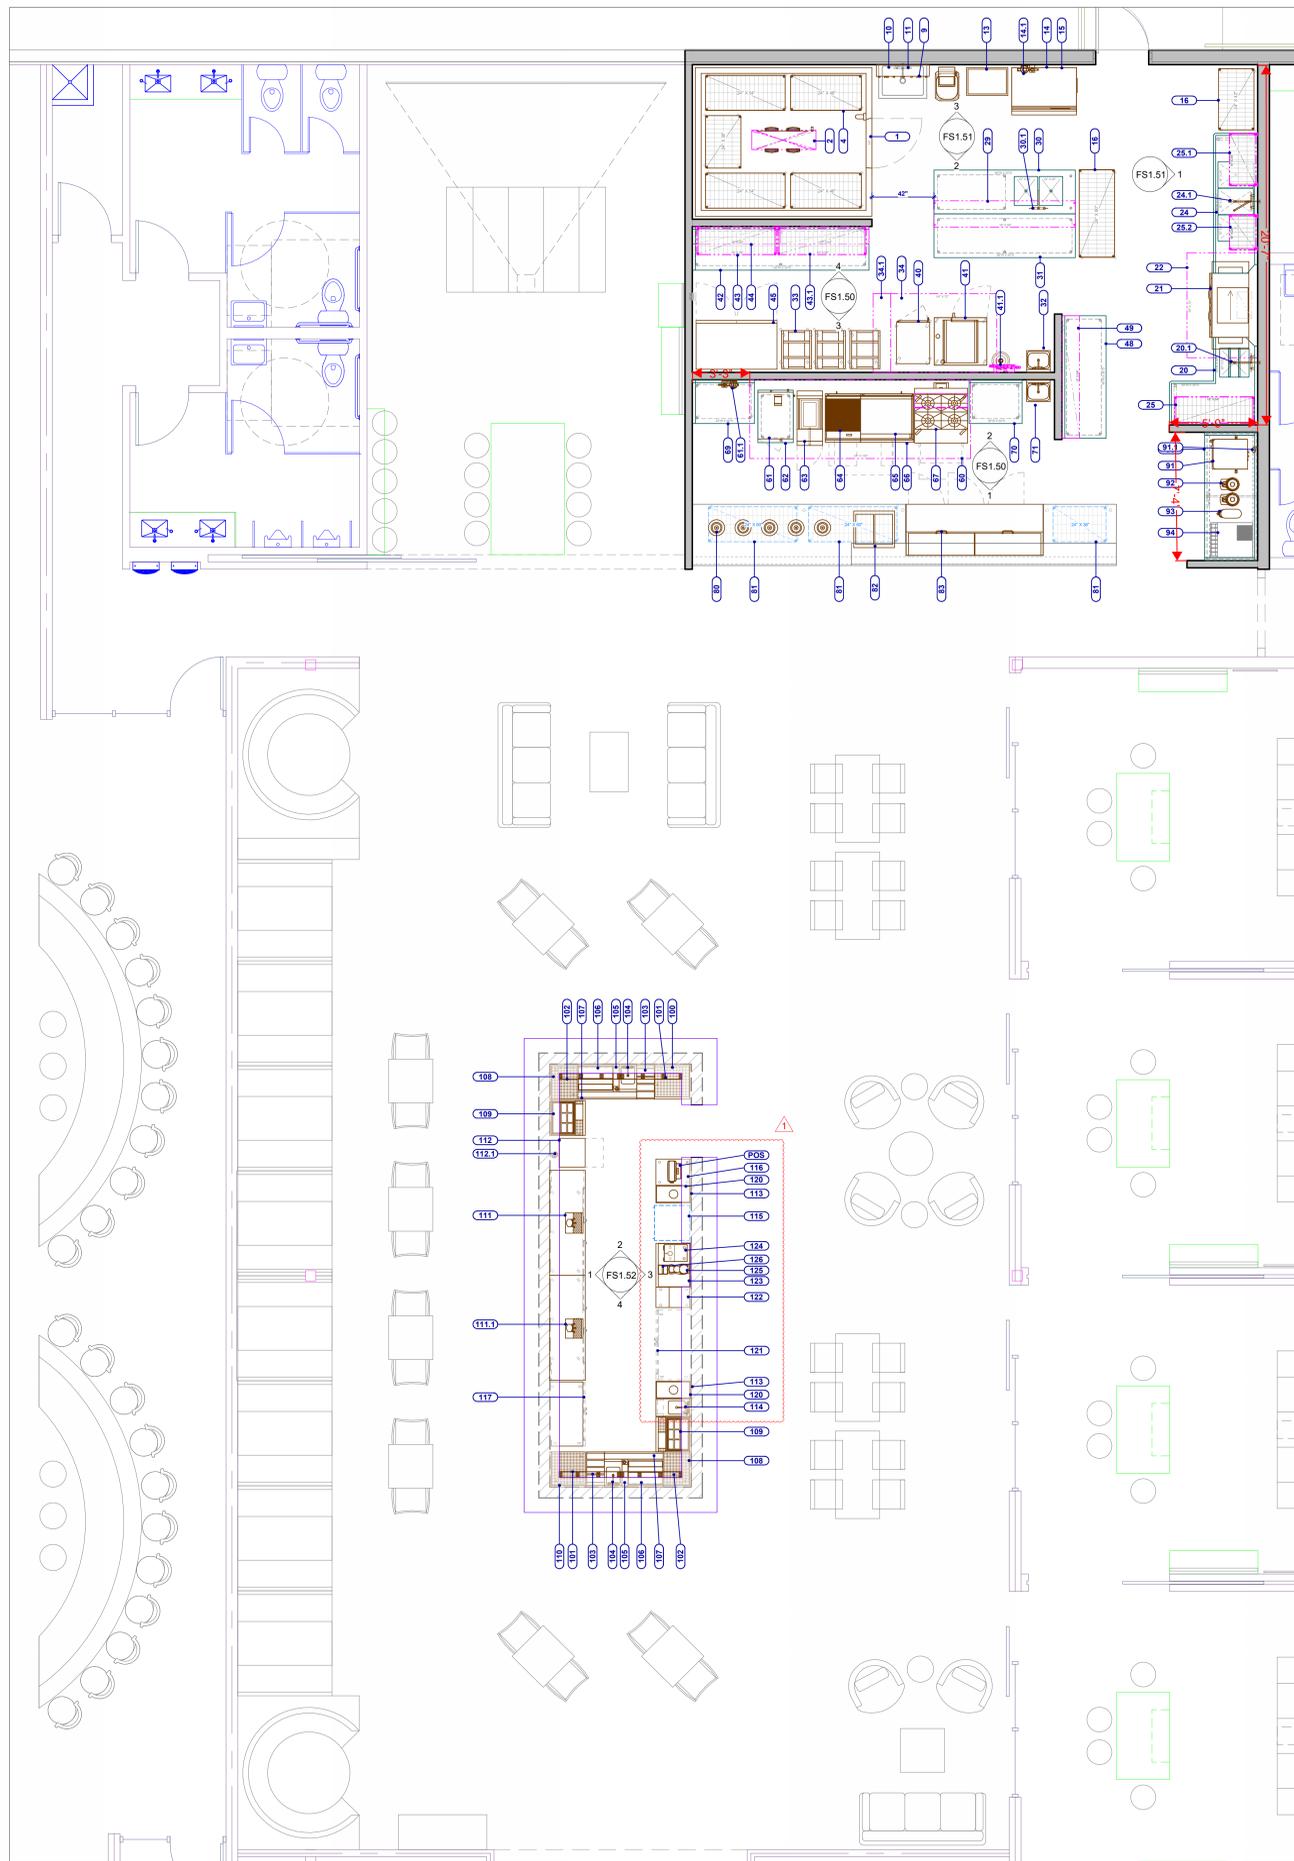


EQUIPMENT SCHEDULE table with columns: ITEM #, QTY, DESCRIPTION, MANUFACTURER, MODEL, EQUIPMENT REMARK. Lists various kitchen equipment items and their specifications.

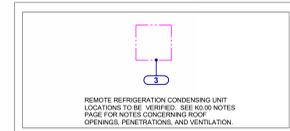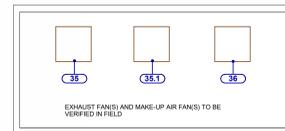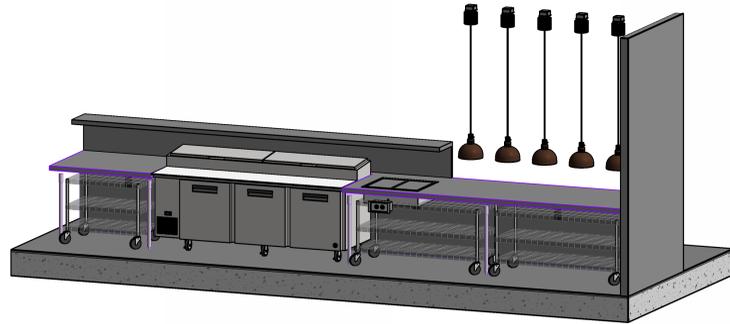


EQUIPMENT UTILITY SCHEDULE

ITEM #	QTY	DESCRIPTION	MANUFACTURER	MODEL	EQUIPMENT REMARK	VOLTS	PHASE	AMPS	HP	CONN TYPE	ELEC R/HHT (AFF)	ELECTRICAL REMARKS	CW SIZE	CW R/HHT (AFF)	HW SIZE	HW R/HHT (AFF)	DW CONN SIZE	DW R/HHT (AFF)	INDIRECT WASTE SIZE	GAS SIZE	GAS INPUT (BTU)	GAS R/HHT (AFF)	PLUMBING REMARKS	
1	1	WALK-IN COOLER	PER SPECIFICATION	CUSTOM	SIZE & SHAPE PER PLAN; REFER TO FABRICATOR'S FINAL APPROVED DRAWINGS	120 V	1	15.0 A		DIRECT	108"	FOR LIGHTS, DOOR HEATER, ETC.; REFER TO FABRICATOR'S FINAL APPROVED DRAWINGS												
2	1	EVAPORATOR COIL - MED TEMP	PER SPECIFICATION	PER SPECIFICATION		120 V	1	1.0 A		DIRECT	108"	REFER TO FABRICATOR'S FINAL APPROVED DRAWINGS								3/4"			IW TO MOP SINK	
3	1	REMOTE CONDENSER - MEDIUM TEMP STORAGE SHELVING UNIT	FABRICATOR	CUSTOM		208 V	1	15.0 A	1	DIRECT		LOCATION TBD; EC TO VERIFY REQUIREMENTS W/ FABRICATOR'S FINAL APPROVED DRAWINGS												
4	5	UTILITY SHELF	JOHN BOOS	PBMS836																				
9	1	MOP SINK	NIC BY OTHERS	NIC BY OTHERS	VERIFY SIZE AND LOCATION																		NIC BY OTHERS. VERIFY LOCATION AND DRAIN SIZE	
10	1	SERVICE SINK FAUCET	NIC BY OTHERS	NIC BY OTHERS																				
11	1	BAG-IN-BOX RACK	BY VENDOR	BNB		120 V	1	20.0 A		CORD & PLUG	48"	NIC BY OTHERS. VERIFY REQUIREMENTS W/ OWNER/VENDOR	1/2"	36"	1/2"	36"							NIC BY OTHERS. VERIFY REQUIREMENTS W/ OWNER/VENDOR	
14	1	STACKABLE SQUARE CUBER	HOSHIZAKI	IM500SAB		120 V	1	11.5 A		DIRECT	60"													
14.1	1	WATER FILTER, ICE MAKER	HOSHIZAKI	H9320-51																			BTC CW FROM WATER FILTER, IW TO FLOOR SINK	
15	1	ICE STORAGE BIN SERIES	HOSHIZAKI	B7005F																			BTC CW TO FINAL CONNECTION AT ICE MACHINE	
16	2	STORAGE SHELVING UNIT	PER SPECIFICATION	PER SPECIFICATION																			IW TO FLOOR SINK	
20	1	SOILED DISH TABLE W/ PRE-RINSE SINK	FABRICATOR	CUSTOM																			IW TO FLOOR SINK OR GREASE TRAP (BY OTHERS) PER LOCAL CODE	
20.1	1	WALL MOUNT PRE-RINSE	KROWNE METAL	17-109WL																				
21	1	DISHMACHINE, CONVEYOR	CHAMPION	44 PRO	VERIFY SPEC	208 V	3	111.0 A		DIRECT	54"	EC TO VERIFY PRIOR TO ROUGHING-IN. REFER TO SPEC SHEET	1/2"	18"	1/2"	18"							1 1/2"	VERIFY REQUIREMENTS W/ OWNER/VENDOR, CW REQUIRED FOR DRAIN TEMPERING, IW TO FLOOR SINK OR GREASE TRAP (BY OTHERS) PER LOCAL CODE
22	1	CONDENSATE HOOD	PER SPECIFICATION	CUSTOM	WALL BLOCKING & OVERHEAD SUPPORTS BY GC; REFER TO FABRICATOR'S FINAL APPROVED DRAWINGS																			
24	1	3-COMP SINK / SOILED DISH TABLE	FABRICATOR	CUSTOM																				
24.1	1	WALL MOUNT PRE-RINSE	KROWNE METAL	17-109WL																				IW TO FLOOR SINK OR GREASE TRAP (BY OTHERS) PER LOCAL CODE
25	2	18" X 54" WIRE WALL SHELVING	PER SPECIFICATION	PER SPECIFICATION																				
25.1	2	18" X 36" WIRE WALL SHELVING	PER SPECIFICATION	PER SPECIFICATION																				
25.2	2	18" X 24" WIRE WALL SHELVING	PER SPECIFICATION	PER SPECIFICATION																				
29	1	CEILING-MOUNTED OVERSHELF	FABRICATOR	CUSTOM	BLOCKING/SUPPORT BY GC																			
30	1	WORK TABLE W/ SINKS	FABRICATOR	CUSTOM	FAUCET INCLUDED																			
30.1	1	DECK MOUNT FAUCET	KROWNE METAL	15-812L																				IW TO FLOOR SINK
31	1	WORK TABLE	FABRICATOR	PER SPECIFICATION																				PC TO STUB UP HOT AND COLD WATER FROM FLOOR
32	1	HANDSINK	KROWNE METAL	HS-26L																				
33	3	BUN PAN RACK	CHANNEL MANUFACTURING	401A																				
34	1	EXHAUST HOOD	PER SPECIFICATION	CUSTOM	WALL BLOCKING & OVERHEAD SUPPORTS BY GC; REFER TO FABRICATOR'S FINAL APPROVED DRAWINGS	0 V	1	0.0 A		INTERWIRE 0/LOW VOLTAGE	120"	EC BTC 120V FROM CONTROL PANEL FOR LIGHTS, EC TO PROVIDE LOW VOLTAGE CONDUIT AND WIRE TO CONTROL PANEL REQUIRED FOR HOOD TEMP SENSOR												
34.1	1	FIRE SUPPRESSION SYSTEM	PER SPECIFICATION	CUSTOM	REFER TO FABRICATOR'S FINAL APPROVED DRAWINGS	120 V	1	10.0 A		DIRECT	120"	JB DFA BTC. REFER TO FABRICATOR'S FINAL APPROVED DRAWINGS												
35	1	EXHAUST FAN	PER SPECIFICATION	PER SPECIFICATION	LOCATION TBD; REFER TO FABRICATOR'S FINAL APPROVED DRAWINGS	208 V	1	13.2 A		DIRECT		REFER TO FABRICATOR'S FINAL APPROVED DRAWINGS												
35.1	1	EXHAUST FAN	PER SPECIFICATION	PER SPECIFICATION	LOCATION TBD; REFER TO FABRICATOR'S FINAL APPROVED DRAWINGS	208 V	1	5.4 A		DIRECT		REFER TO FABRICATOR'S FINAL APPROVED DRAWINGS												
36	1	CONDENSATE FAN	PER SPECIFICATION	PER SPECIFICATION	LOCATION TBD; REFER TO FABRICATOR'S FINAL APPROVED DRAWINGS	120 V	1	20.0 A		DIRECT		REFER TO FABRICATOR'S FINAL APPROVED DRAWINGS												
40	1	LOW TEMP COOK & HOLD / SMOKER	ALTO SHAAM	1000SKI		208 V	1	31.4 A		DIRECT	60"													
41	1	SINGLE COMBI OVEN	BLOGGETT	INV0Q 101 BG		120 V	1	10.0 A		DIRECT	48"	EC TO VERIFY PRIOR TO ROUGHING-IN. REFER TO SPEC SHEET	3/4"	18"						2"	3/4"	72,000 BTU/H	30"	(2) WATER CONNECTIONS REQUIRED - (1) FILTERED AND (1) UNFILTERED, IW TO FLOOR SINK. VERIFY REQUIREMENTS PRIOR TO ROUGHING-IN. REFER TO SPEC SHEET
41.1	1	REVERSE OSMOSIS SYSTEM	BLOGGETT	RO150P/ST10									3/4"	72"										BTC RO SYSTEM TO FINAL CONNECTION AT COMBI OVEN. REFER TO SPEC SHEET
42	1	WORK TABLE	FABRICATOR	PER SPECIFICATION																				
43	1	18" X 54" WIRE WALL SHELVING	PER SPECIFICATION	PER SPECIFICATION																				
43.1	1	18" X 60" WIRE WALL SHELVING	PER SPECIFICATION	PER SPECIFICATION																				
44	2	12" X 60" SOLID S/S WALL SHELF	PER SPECIFICATION	PER SPECIFICATION																				
45	1	FREEZER	HOSHIZAKI AMERICA	F2A-F5		120 V	1	8.7 A		CORD & PLUG	48"													
48	1	WORK TABLE	FABRICATOR	PER SPECIFICATION																				
49	2	12" X 60" SOLID S/S WALL SHELF	PER SPECIFICATION	PER SPECIFICATION																				
60	1	EXHAUST HOOD	PER SPECIFICATION	CUSTOM	WALL BLOCKING & OVERHEAD SUPPORTS BY GC; REFER TO FABRICATOR'S FINAL APPROVED DRAWINGS	0 V	1	0.0 A		DIRECT	120"	EC BTC 120V FROM CONTROL PANEL FOR LIGHTS, EC TO PROVIDE LOW VOLTAGE CONDUIT AND WIRE TO CONTROL PANEL REQUIRED FOR HOOD TEMP SENSOR												
61	1	STEAMER, GAS	CROWN	SX5G3		120 V	1	2.0 A		CORD & PLUG	24"		3/8"	18"										
61.1	1	WATER FILTER ASSEMBLY	EVERPURE	EV9797-50																				
62	1	EQUIPMENT STAND	FABRICATOR	CUSTOM																				
63	1	FRYER, GAS	HENNY PENNY	DFG 321		120 V	1	12.0 A		CORD & PLUG	24"													
64	1	CHARBROILER	SOUTHBEND	HDC-24																				
65	1	GRIDDLE	SOUTHBEND	HDC-36																				
66	1	REFRIGERATED EQUIPMENT STAND	HOSHIZAKI	CR60A		120 V	1	2.7 A		CORD & PLUG	24"													
67	1	4-BURNER RANGE W/ CONVECTION OVEN BASE	SOUTHBEND	P36A-XX		120 V	1	5.9 A	1/2	CORD & PLUG	24"													
69	1	WORK TABLE	FABRICATOR	PER SPECIFICATION																				
70	1	WORK TABLE	FABRICATOR	PER SPECIFICATION																				
71	1	HANDSINK	KROWNE METAL	HS-26L																				
80	5	RETRACTABLE HEAT LAMPS	HATCO	DLH750RCTL	BLACK SHADE AND BLACK CORD	120 V	1	3.1 A		DIRECT	120"	EC TO MOUNT JUNCTION BOX DIRECTLY ABOVE FINISHED CEILING. REFER TO SPEC SHEET	1/2"	16"	1/2"	16"	1 1/2"	21"						
81	3	UNDERCOUNTER SHELVING UNIT	PER SPECIFICATION	CUSTOM																				
82	1	DROP-IN HOT WELL	ALTO SHAAM	200HW/D6		120 V	1	10.0 A		CORD & PLUG	24"													
83	1	PIZZA PREP TABLE	HOSHIZAKI	PR93A		120 V	1	6.5 A		CORD & PLUG	24"													
90	1	BEVERAGE COUNTER	FABRICATOR	CUSTOM																				
91	1	COFFEE/TEA BREWER	BUNN	52400.0100		120 V	1	25.0 A		DIRECT	48"													
91.1	1	WATER FILTER ASSEMBLY	BUNN	WEQ10									3/8"	60"										BTC CW FROM WATER FILTER
92	2	COFFEE SERVER WITH BASE	BUNN	42750.0200									1/2"	60"										BTC CW TO FINAL CONNECTION AT COFFEE BREWER
93	1	TEA DISPENSER	BUNN	39600.0001																				
94	1	SODA/ICE DISPENSER	NIC BY OTHERS	NIC BY OTHERS		120 V	1	15.0 A		CORD & PLUG	48"													NIC BY OTHERS. VERIFY REQUIREMENTS W/ OWNER/VENDOR
100	1	GLASS STORAGE DRAINBOARD	GLASTENDER	DBGR-24																				
101	2	DRINK RAIL	GLASTENDER	DR42R																				
102	2	DRINK RAIL	GLASTENDER	DR42L																				
103	2	LIQUOR DISPLAY	GLASTENDER	LDA-12S																				
104	2	DUMP SINK	GLASTENDER	SWA-12																				
105	2	SODA GLN HOLDER	GLASTENDER	C-SHA-4																				
106	2	ICE BIN	GLASTENDER	IBA-24-CP10																				
107	2	SPEED RAIL	GLASTENDER	SSR-40																				

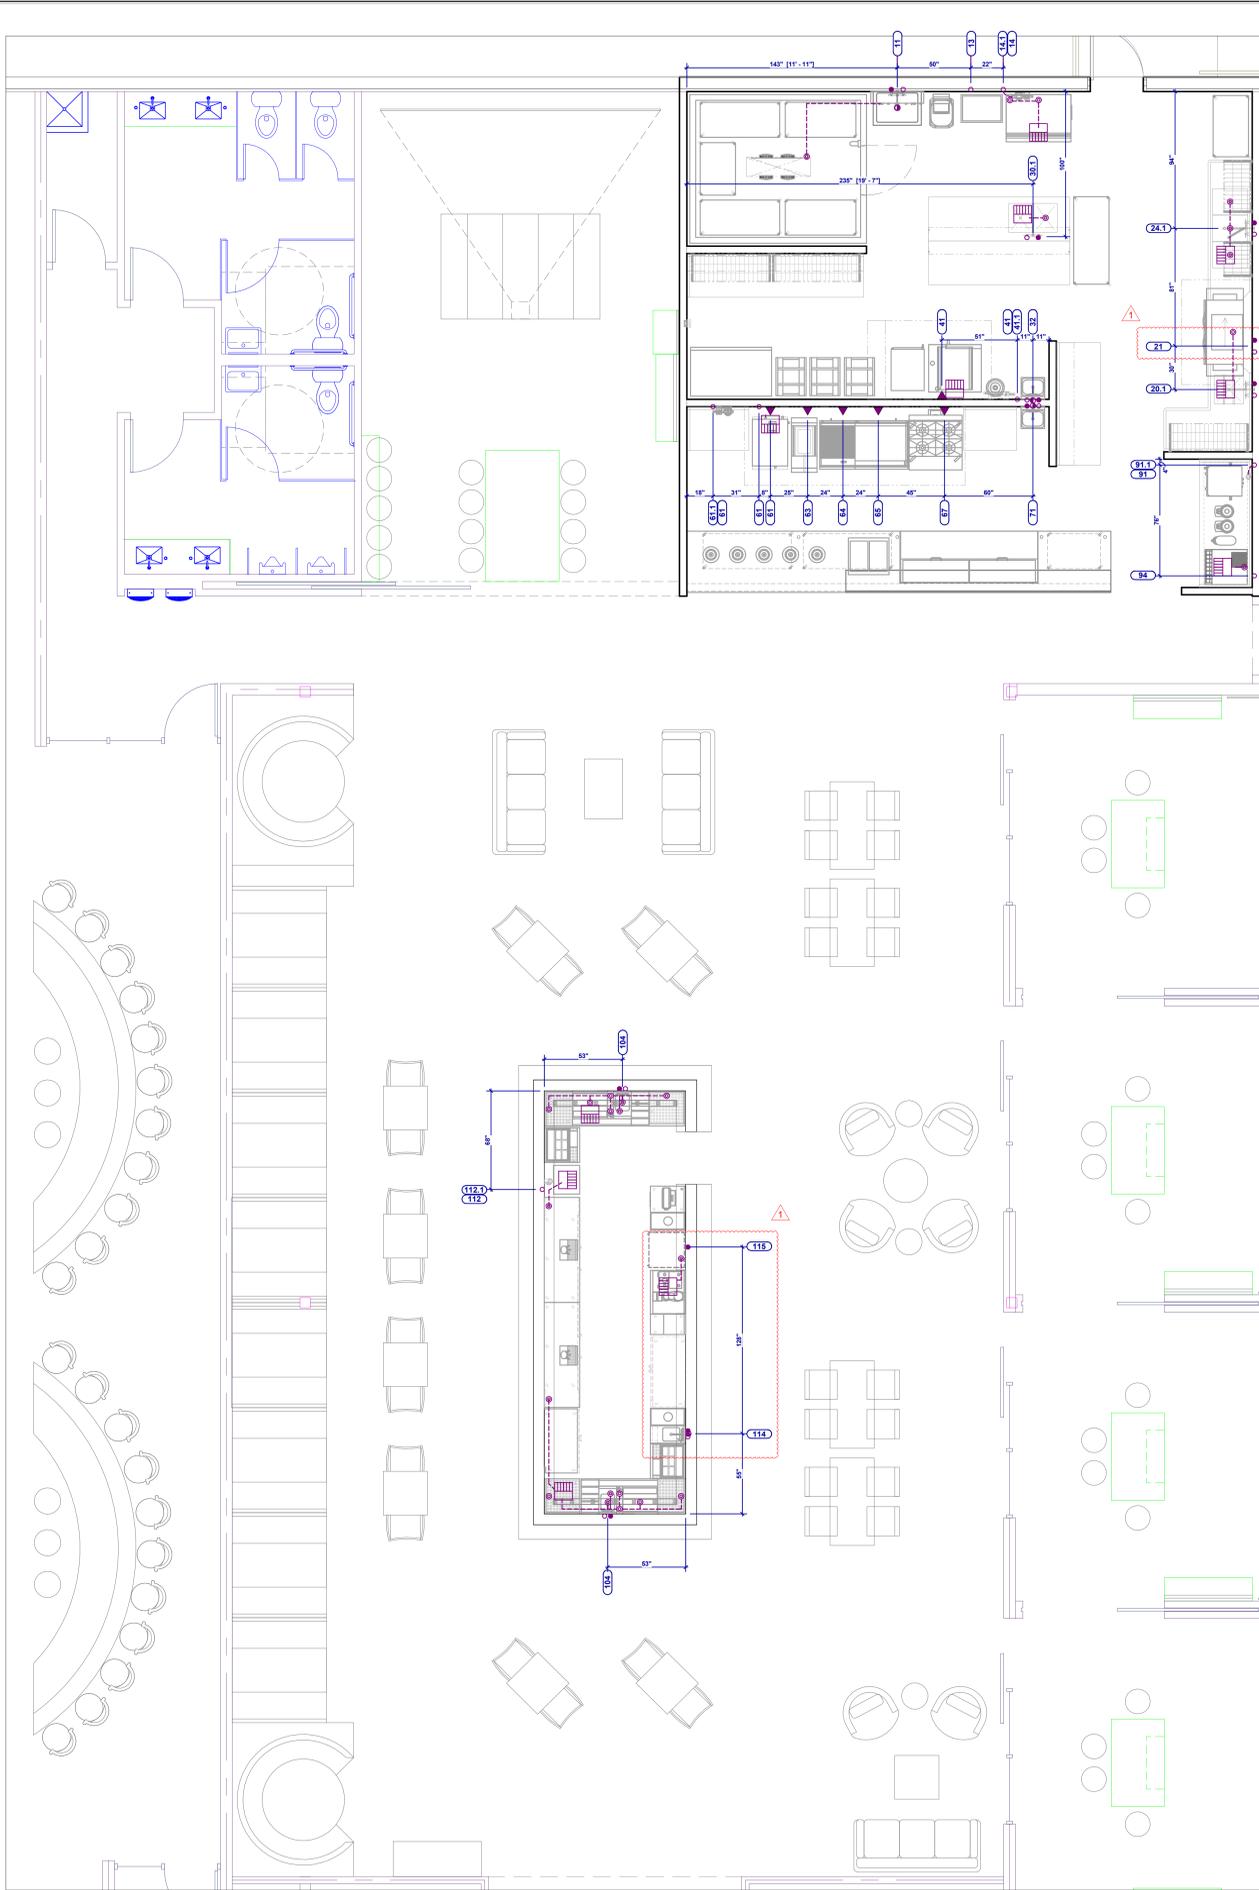

PLUMBING ROUGH-IN SCHEDULE													
ITEM #	QTY	DESCRIPTION	CW SIZE	CW R/H (AFF)	HW SIZE	HW R/H (AFF)	DW CONN SIZE	DW R/H (AFF)	IW CONN SIZE	GAS SIZE	GAS INPUT (BTU)	GAS R/H (AFF)	PLUMBING REMARKS
2	1	EVAPORATOR COIL - MED TEMP							3/4"				IW TO MOP SINK NIC BY OTHERS. VERIFY LOCATION AND DRAIN SIZE
10	1	MOP SINK											
11	1	SERVICE SINK FAUCET	1/2"	36"	1/2"	36"							NIC BY OTHERS. VERIFY REQUIREMENTS W/ OWNER/VENDOR
13	1	BAG-IN-BOX RACK	1/2"	72"									NIC BY OTHERS. VERIFY REQUIREMENTS W/ OWNER/VENDOR
14	1	STACKABLE SQUARE CUBER	1/2"						3/4"				BTC CW FROM WATER FILTER. IW TO FLOOR SINK
14.1	1	WATER FILTER, ICE MAKER	1/2"	96"									BTC CW TO FINAL CONNECTION AT ICE MACHINE
15	1	ICE STORAGE BIN SERIES							3/4"				IW TO FLOOR SINK
20	1	SOILED DISH TABLE W/ PRE-RINSE SINK							1 1/2"				IW TO FLOOR SINK OR GREASE TRAP (BY OTHERS) PER LOCAL CODE
20.1	1	WALL MOUNT PRE-RINSE	1/2"	18"	1/2"	18"							VERIFY REQUIREMENTS W/ OWNER/VENDOR. CW REQUIRED FOR DRAIN TEMPERING. IW TO FLOOR SINK OR GREASE TRAP (BY OTHERS) PER LOCAL CODE
21	1	DISHMACHINE, CONVEYOR	1/2"	18"	1/2"	18"			1 1/2"				IW TO FLOOR SINK OR GREASE TRAP (BY OTHERS) PER LOCAL CODE
24	1	3-COMP SINK/ SOILED DISHTABLE							1"				IW TO FLOOR SINK OR GREASE TRAP (BY OTHERS) PER LOCAL CODE
24.1	1	WALL MOUNT PRE-RINSE	1/2"	18"	1/2"	18"							IW TO FLOOR SINK OR GREASE TRAP (BY OTHERS) PER LOCAL CODE
30	1	WORK TABLE W/SINKS							1 1/2"				IW TO FLOOR SINK
30.1	1	DECK MOUNT FAUCET	1/2"	4"	1/2"	4"							PC TO STUB UP HOT AND COLD WATER FROM FLOOR
32	1	HANDSINK	1/2"	16"	1/2"	16"	1 1/2"	21"					
41	1	SINGLE COMBI OVEN	3/4"	18"					2"	3/4"	72,000 BTU/H	30"	(2) WATER CONNECTIONS REQUIRED - (1) FILTERED AND (1) UNFILTERED. IW TO FLOOR SINK OR GREASE TRAP (BY OTHERS) PER LOCAL CODE
41.1	1	REVERSE OSMOSIS SYSTEM	3/4"	72"									BTC RW SYSTEM TO FINAL CONNECTION AT COMBI OVEN. REFER TO SPEC SHEET
61	1	STEAMER, GAS	3/8"	18"					1"	3/4"	47,000 BTU/H	30"	(2) CW CONNECTIONS REQUIRED - (1) FILTERED CW FOR BOILER, (1) UNFILTERED CW FOR CONDENSER. REFER TO SPEC SHEET
61.1	1	WATER FILTER ASSEMBLY											BTC CW TO FINAL CONNECTION AT STEAMER BOILER
63	1	FRYER, GAS	3/8"	26"						1/2"	85,000 BTU/H	30"	
64	1	CHARBROILER								3/4"	80,000 BTU/H	30"	
65	1	GRIDDLE								3/4"	90,000 BTU/H	30"	
67	1	4-BURNER RANGE W/ CONVECTION OVEN BASE								1"	225,000 BTU/H	30"	
71	1	HANDSINK	1/2"	16"	1/2"	16"	1 1/2"	21"					BTC CW FROM WATER FILTER
91	1	COFFEE/TEA BREWER	3/8"	60"									BTC CW TO FINAL CONNECTION AT COFFEE BREWER
91.1	1	WATER FILTER ASSEMBLY	1/2"	60"									NIC BY OTHERS. VERIFY REQUIREMENTS W/ OWNER/VENDOR
94	1	SODA/ICE DISPENSER	3/8"	60"					3/4"				
100	1	GLASS STORAGE DRAINBOARD							1/2"				IW TO FLOOR SINK
101	2	DRINK RAIL							1/2"				IW TO FLOOR SINK
102	2	DRINK RAIL							1/2"				IW TO FLOOR SINK
104	2	DUMP SINK	3/8"	12"	3/8"	12"			1 1/2"				IW TO FLOOR SINK
105	2	SODA GUN HOLDER							1/2"				IW TO FLOOR SINK
106	2	ICE BIN							3/4"				IW TO FLOOR SINK
108	2	CORNER INSIDE DRAINBOARD							1/2"				IW TO FLOOR SINK
110	1	CORNER INSIDE DRAINBOARD							1/2"				IW TO FLOOR SINK
111	1	KEG COOLER							1/2"				IW TO FLOOR SINK
111.1	1	KEG COOLER							1/2"				IW TO FLOOR SINK
112	1	LARGE SQUARE ICE CUBER	1/2"						3/4"				BTC CW FROM WATER FILTER. IW TO FLOOR SINK
112.1	1	WATER FILTER ASSEMBLY	1/2"	30"									BTC CW TO FINAL CONNECTION AT ICE MAKER
114	1	HAND SINK	3/8"	12"	3/8"	12"	1 1/2"	16"					
115	1	UNDERCOUNTER DISHMACHINE			1/2"	12"			5/8"				IW TO FLOOR SINK

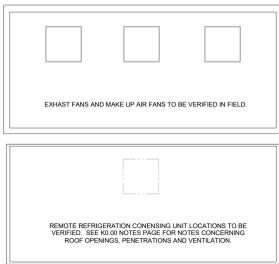

Plumbing Symbols	
All symbols may not be to same scale as on the drawing.	
XXX	Rough-IN Number
[X]	Detail Drawing Reference
●	Hot Water
○	Cold Water
●	Indirect Waste
●	Direct Waste
▲	Gas Connection
■	Floor Sink
⊕	Area Floor Drain
⊗	Funnel Floor Drain
■	Chilled Water Supply & Return



**Singer  
Equipment  
Company**

180 Heller Place,  
Bellmawr, NJ  
08030

856-559-4200

COPYRIGHT, THESE DOCUMENTS IN PART OR IN WHOLE, AND THE DESIGN THEY REPRESENT, ARE THE SOLE PROPERTY OF SINGER EQUIPMENT COMPANY. THESE DOCUMENTS ARE INTENDED FOR THE PROJECT ON SITE INDICATED. ANY USE, REPRODUCTION, MODIFICATION OR ADOPTION WITHOUT THE EXPRESS WRITTEN CONSENT OF SINGER EQUIPMENT COMPANY IS STRICTLY PROHIBITED.

**JOB NAME:**  
**Sanctuary  
Golf**

**ADDRESS:**  
25191 Chamber of  
Commerce Dr  
Bonita Springs  
FL 34135


**PROJECT #:** ---  
**DRAWN BY:** JL  
**CHECKED BY:** XXX

SUBMITTALS & REVISIONS			
REV	DATE	NAME	DESCRIPTION
	07-22-25		Design development
	07-25-25		Design development Full Set
1	08-19-25	JL	Revisions per owner

**SHEET NAME:**  
**Plumbing  
Rough-in  
Plan**

**SCALE:** 1/4" = 1'-0"

**DRAWING SHEET NO.**  
**FS1.20**

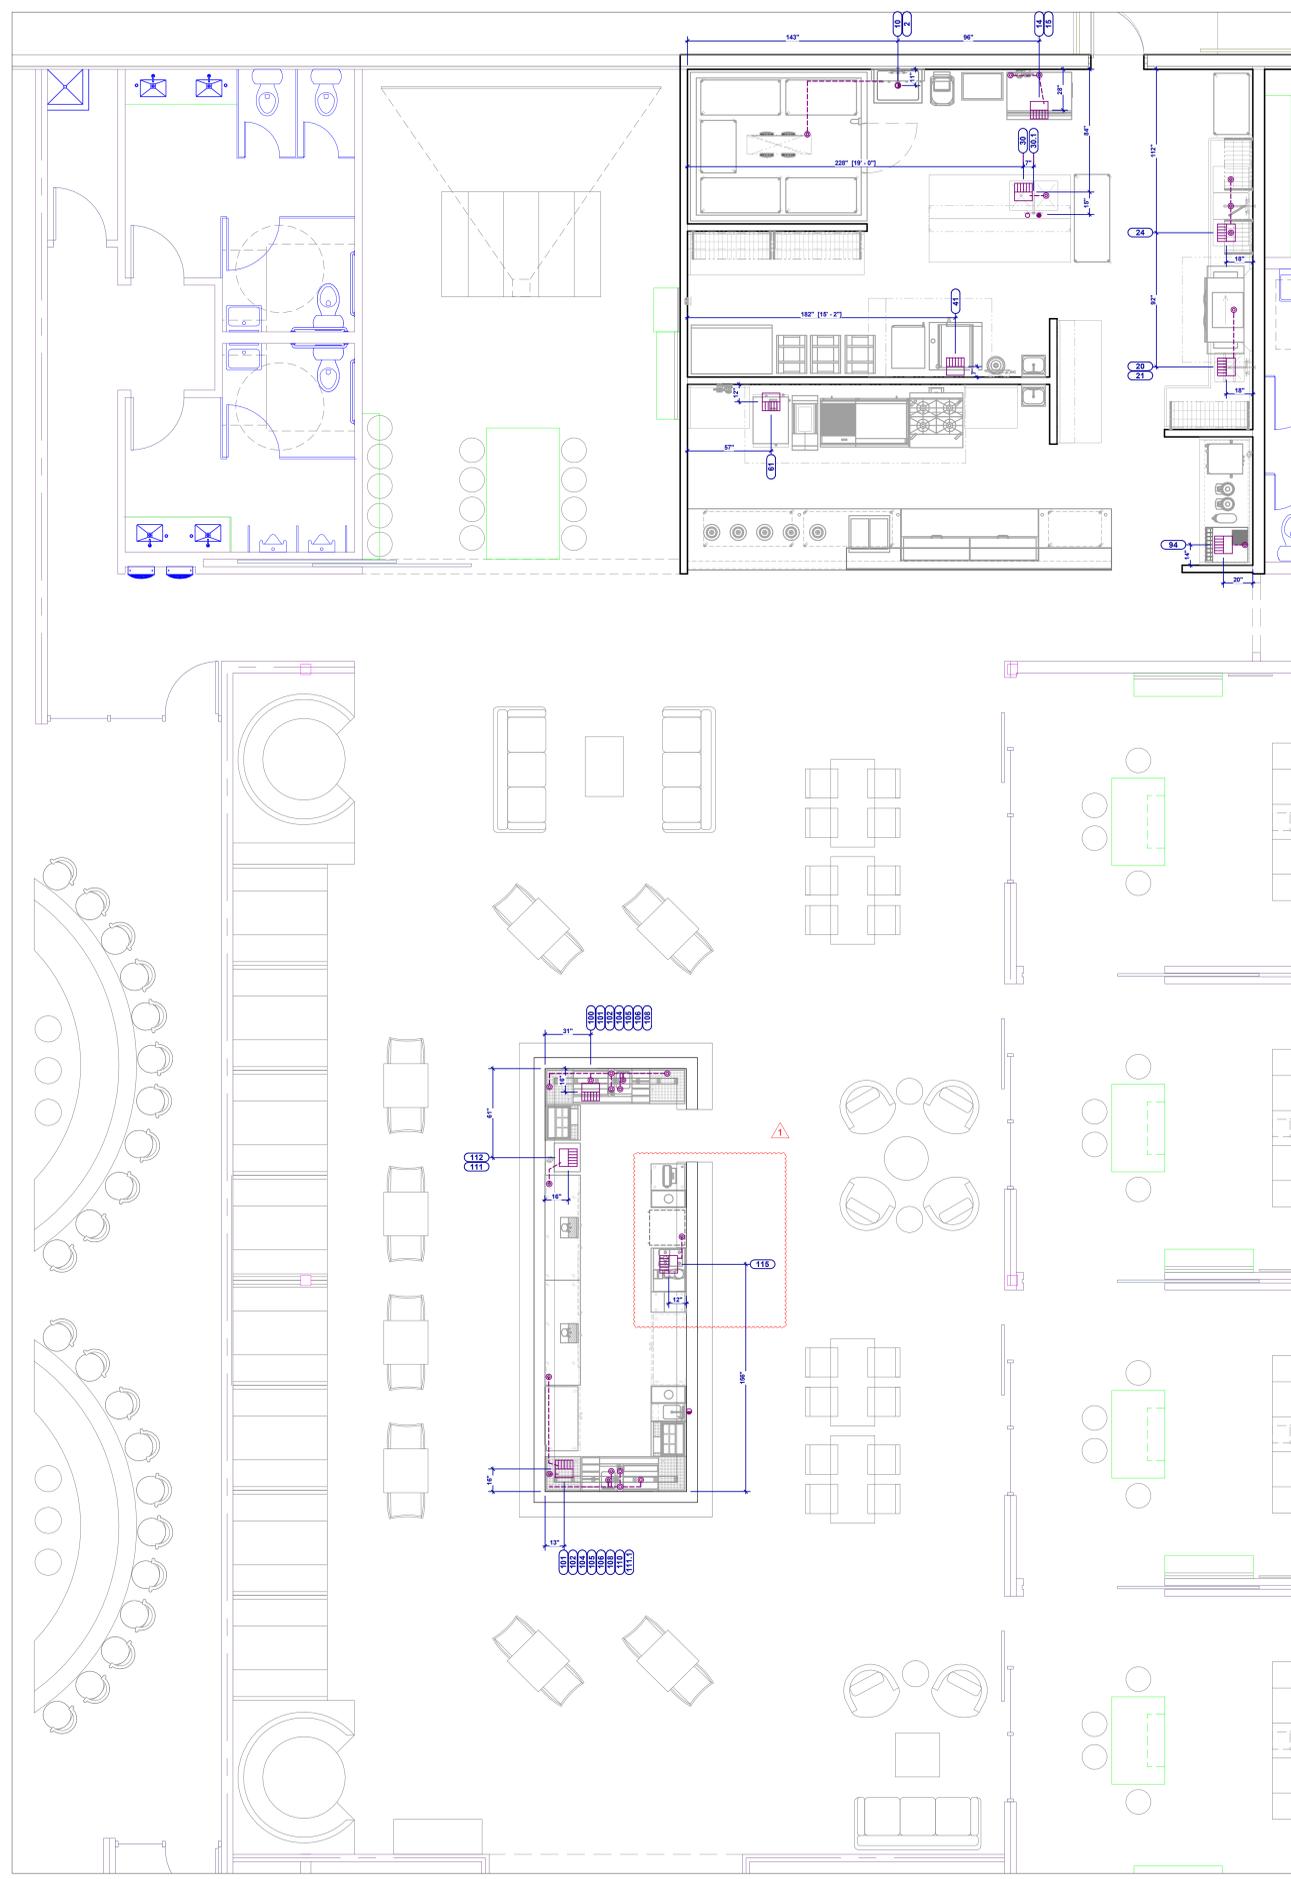

PLUMBING DRAIN ROUGH-IN SCHEDULE						
ITEM #	QTY	DESCRIPTION	D/W CONN. SIZE	D/W R/H (A/F)	I/W CONN. SIZE	PLUMBING REMARKS
2	1	EVAPORATOR COIL - MED TEMP			3/4"	IW TO MOP SINK
10	1	MOP SINK	2"	0"		NIC BY OTHERS. VERIFY LOCATION AND DRAIN SIZE
11	1	SERVICE SINK FAUCET				
13	1	BAG-IN-BOX RACK			3/4"	NIC BY OTHERS. VERIFY REQUIREMENTS W/ OWNER/VENDOR
14	1	STACKABLE SQUARE CUBER			3/4"	BTC CW FROM WATER FILTER. IW TO FLOOR SINK
14.1	1	WATER FILTER, ICE MAKER				BTC CW TO FINAL CONNECTION AT ICE MACHINE
15	1	ICE STORAGE BIN SERIES			3/4"	IW TO FLOOR SINK
20	1	SOILED DISH TABLE W/ PRE-RINSE SINK			1 1/2"	IW TO FLOOR SINK OR GREASE TRAP (BY OTHERS) PER LOCAL CODE
20.1	1	WALL MOUNT PRE-RINSE				
21	1	DISHMACHINE, CONVEYOR			1 1/2"	VERIFY REQUIREMENTS W/ OWNER/VENDOR. CW REQUIRED FOR DRAIN TEMPERING. IW TO FLOOR SINK OR GREASE TRAP (BY OTHERS) PER LOCAL CODE
24	1	3-COMP SINK/ SOILED DISHTABLE			1"	IW TO FLOOR SINK OR GREASE TRAP (BY OTHERS) PER LOCAL CODE
24.1	1	WALL MOUNT PRE-RINSE				
30	1	WORK TABLE W/ SINKS			1 1/2"	IW TO FLOOR SINK
30.1	1	DECK MOUNT FAUCET				PG TO STUB UP HOT AND COLD WATER FROM FLOOR
32	1	HANDSINK	1 1/2"	21"		
41	1	SINGLE COMBI OVEN			2"	(2) WATER CONNECTIONS REQUIRED - (1) FILTERED AND (1) UNFILTERED. IW TO FLOOR SINK. VERIFY REQUIREMENTS PRIOR TO ROUGHING-IN. REFER TO SPEC SHEET
41.1	1	REVERSE OSMOSIS SYSTEM				BTC RO SYSTEM TO FINAL CONNECTION AT COMBI OVEN. REFER TO SPEC SHEET
61	1	STEAMER, GAS			1"	(2) CW CONNECTIONS REQUIRED - (1) FILTERED CW FOR BOILER, (1) UNFILTERED CW FOR CONDENSER. REFER TO SPEC SHEET
61.1	1	WATER FILTER ASSEMBLY				BTC CW TO FINAL CONNECTION AT STEAMER BOILER
63	1	FRYER, GAS				
64	1	CHARBROILER				
65	1	GRIDDLE				
67	1	4-BURNER RANGE W/ CONVECTION OVEN BASE				
71	1	HANDSINK	1 1/2"	21"		
91	1	COFFEE/TEA BREWER				BTC CW FROM WATER FILTER
91.1	1	WATER FILTER ASSEMBLY				BTC CW TO FINAL CONNECTION AT COFFEE BREWER
94	1	SOJA/ICE DISPENSER			3/4"	NIC BY OTHERS. VERIFY REQUIREMENTS W/ OWNER/VENDOR
100	1	GLASS STORAGE DRAINBOARD			1/2"	IW TO FLOOR SINK
101	2	DRINK RAIL			1/2"	IW TO FLOOR SINK
102	2	DRINK RAIL			1/2"	IW TO FLOOR SINK
104	2	DUMP SINK			1 1/2"	IW TO FLOOR SINK
105	2	SOJA GUN HOLDER			1/2"	IW TO FLOOR SINK
106	2	ICE BIN			3/4"	IW TO FLOOR SINK
108	2	CORNER INSIDE DRAINBOARD			1/2"	IW TO FLOOR SINK
110	1	CORNER INSIDE DRAINBOARD			1/2"	IW TO FLOOR SINK
111	1	KEG COOLER			1/2"	IW TO FLOOR SINK
111.1	1	KEG COOLER			1/2"	IW TO FLOOR SINK
112	1	LARGE SQUARE ICE CUBER			3/4"	BTC CW FROM WATER FILTER. IW TO FLOOR SINK
112.1	1	WATER FILTER ASSEMBLY				BTC CW TO FINAL CONNECTION AT ICE MAKER
114	1	HAND SINK	1 1/2"	16"		
115	1	UNDERCOUNTER DISHMACHINE			5/8"	IW TO FLOOR SINK



**Singer Equipment Company**  
 180 Heller Place,  
 Bellmawr, NJ  
 08030  
 856-559-4200

COPYRIGHT, THESE DOCUMENTS IN PART OR IN WHOLE, AND THE DESIGN THEY REPRESENT, ARE THE SOLE PROPERTY OF SINGER EQUIPMENT COMPANY. THESE DOCUMENTS ARE INTENDED FOR THE PROJECT ON SITE INDICATED. ANY USE, REPRODUCTION, MODIFICATION OR ADOPTION WITHOUT THE EXPRESS WRITTEN CONSENT OF SINGER EQUIPMENT COMPANY IS STRICTLY PROHIBITED.

**JOB NAME:**  
**Sanctuary Golf**

**ADDRESS:**  
 25191 Chamber of Commerce Dr  
 Bonita Springs  
 FL 34135

**PROJECT #:** ---  
**DRAWN BY:** JL  
**CHECKED BY:** XXX

SUBMITTALS & REVISIONS		
REV	DATE	DESCRIPTION
	07-22-25	Design development
	07-25-25	Design development
	08-04-25	Full Set
1	08-19-25	Revisions per owner

**SHEET NAME:**  
**Plumbing Drain Plan**

**SCALE:** 1/4" = 1'-0"


**DRAWING SHEET NO.**  
**FS1.21**

**Plumbing Symbols**  
All symbols may not be to same scale as on the drawing.

	Rough-IN Number
	Detail Drawing Reference
	Hot Water
	Cold Water
	Indirect Waste
	Direct Waste
	Gas Connection
	Floor Sink
	Area Floor Drain
	Funnel Floor Drain
	Chilled Water Supply & Return

**EXHAUST FANS AND MAKE UP AIR FANS TO BE VERIFIED IN FIELD.**

**REMOTE REFRIGERATION CONDENSING UNIT LOCATIONS TO BE VERIFIED. SEE K0.00 NOTES PAGE FOR NOTES CONCERNING ROOF OPENINGS, PENETRATIONS AND VENTILATION.**

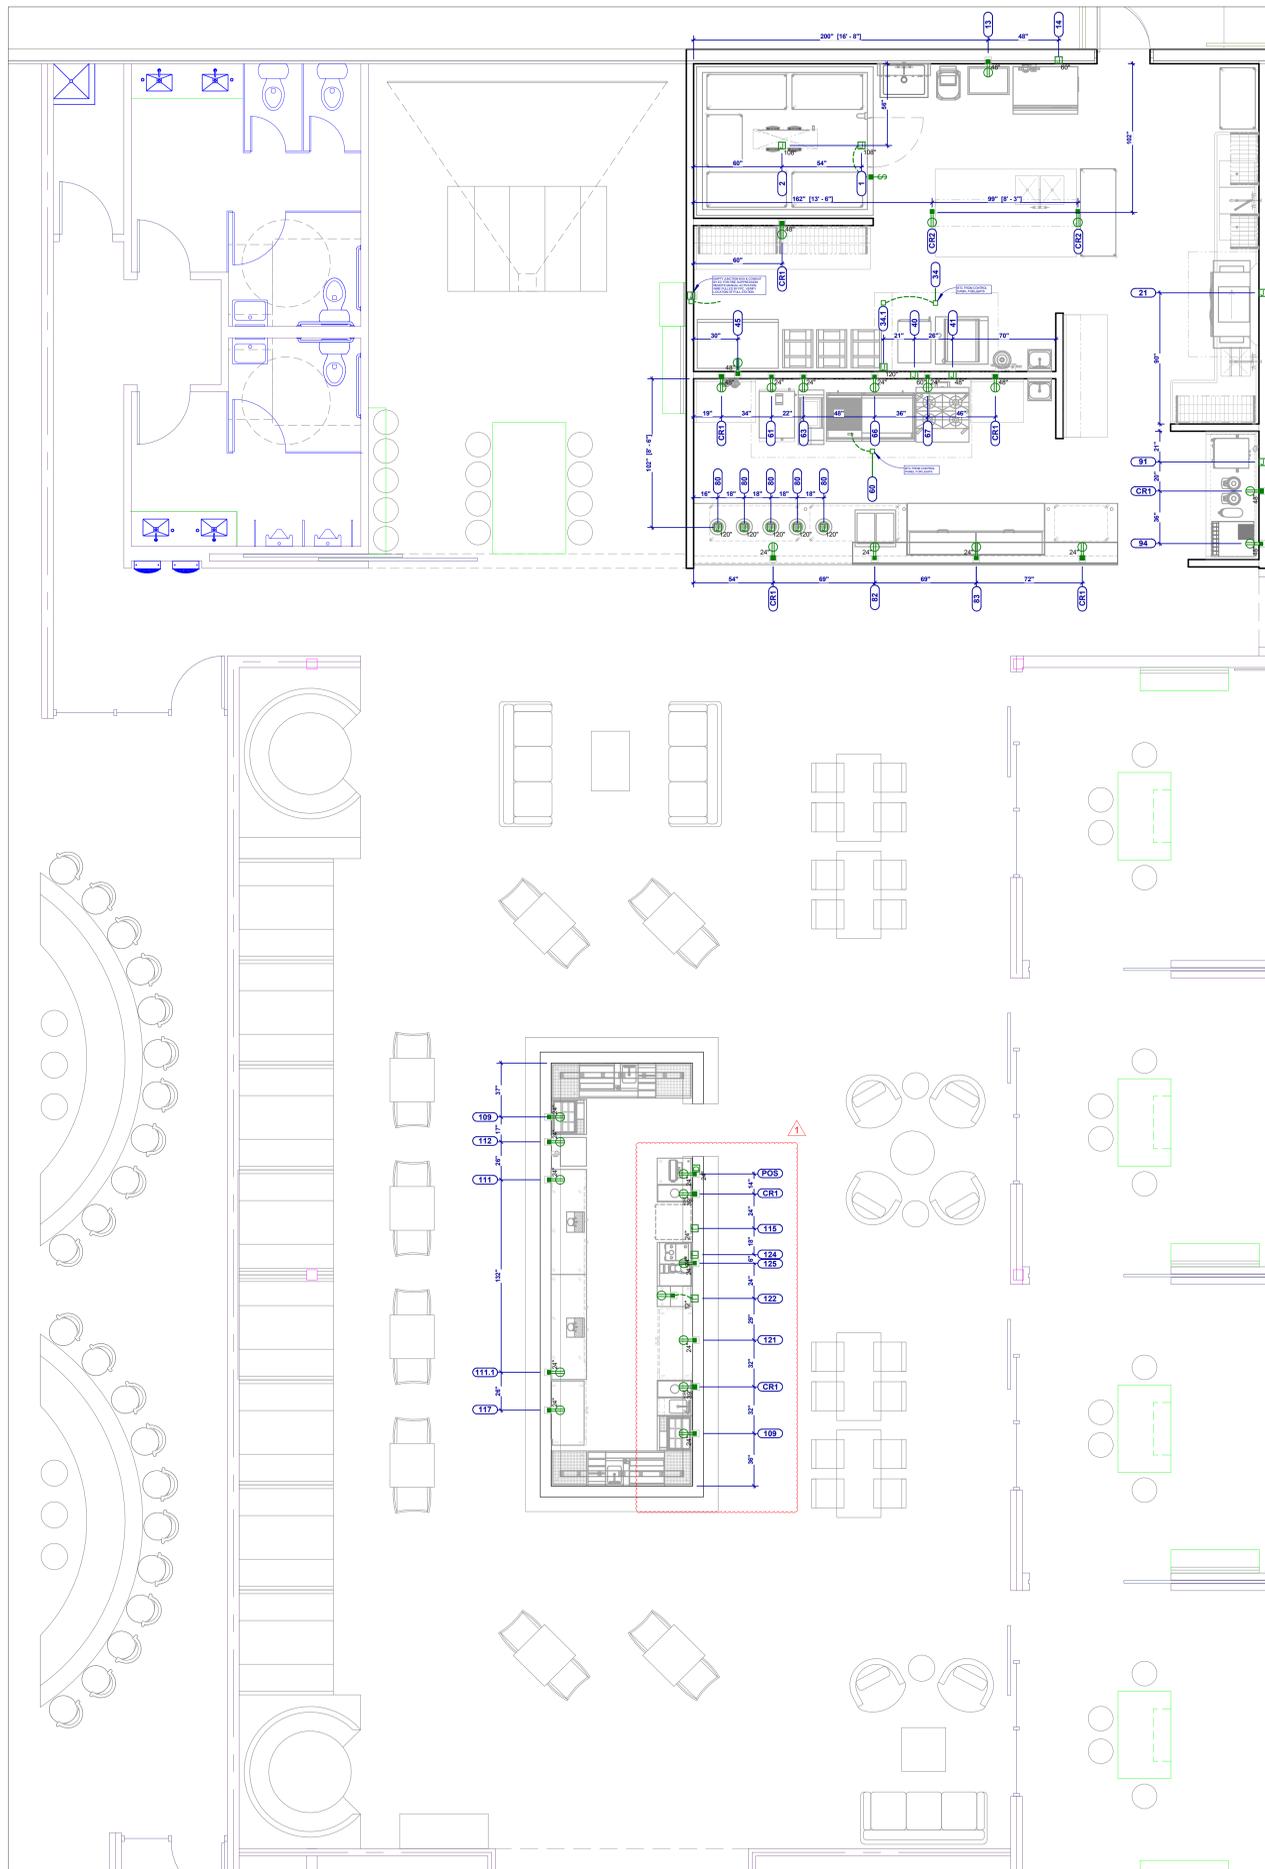

### ELECTRIC ROUGH-IN SCHEDULE

ITEM #	QTY	DESCRIPTION	VOLTS	PHASE	AMPS	HP	CONN TYPE	ELEC RI HT (AFF)	ELECTRICAL REMARKS
1	1	WALK-IN COOLER	120 V	1	15.0 A		DIRECT	108"	FOR LIGHTS, DOOR HEATER, ETC; REFER TO FABRICATOR'S FINAL APPROVED DRAWINGS
2	1	EVAPORATOR COIL - MED TEMP	120 V	1	1.0 A		DIRECT	108"	REFER TO FABRICATOR'S FINAL APPROVED DRAWINGS
3	1	REMOTE CONDENSER - MEDIUM TEMP	208 V	1	15.0 A	1	DIRECT		LOCATION TBD; EC TO VERIFY REQUIREMENTS W/ FABRICATOR'S FINAL APPROVED DRAWINGS
13	1	BAG-IN-BOX RACK	120 V	1	20.0 A		CORD & PLUG	48"	NIC BY OTHERS. VERIFY REQUIREMENTS W/ OWNER/VENDOR
14	1	STACKABLE SQUARE CUBER	120 V	1	11.5 A		DIRECT	60"	
21	1	DISHMACHINE, CONVEYOR	208 V	3	11.0 A		DIRECT	54"	EC TO VERIFY PRIOR TO ROUGHING-IN. REFER TO SPEC SHEET
34	1	EXHAUST HOOD	0 V	1	0.0 A		INTERWIRED/LOW VOLTAGE	120"	EC BTC 120V FROM CONTROL PANEL FOR LIGHTS. EC TO PROVIDE LOW VOLTAGE CONDUIT AND WIRE TO CONTROL PANEL REQUIRED FOR HOOD TEMP SENSOR
34.1	1	FIRE SUPPRESSION SYSTEM	120 V	1	10.0 A		DIRECT	120"	JIB D/A BTC. REFER TO FABRICATOR'S FINAL APPROVED DRAWINGS
35	1	EXHAUST FAN	208 V	1	13.2 A		DIRECT		REFER TO FABRICATOR'S FINAL APPROVED DRAWINGS
35.1	1	EXHAUST FAN	208 V	1	5.4 A		DIRECT		REFER TO FABRICATOR'S FINAL APPROVED DRAWINGS
36	1	CONDENSATE FAN	120 V	1	20.0 A		DIRECT		REFER TO FABRICATOR'S FINAL APPROVED DRAWINGS
40	1	LOW TEMP COOK & HOLD/SMOKER	208 V	1	31.4 A		DIRECT	60"	
41	1	SINGLE COMBI OVEN	120 V	1	10.0 A		DIRECT	48"	EC TO VERIFY PRIOR TO ROUGHING-IN. REFER TO SPEC SHEET
45	1	FREEZER	120 V	1	8.7 A		CORD & PLUG	48"	
60	1	EXHAUST HOOD	0 V	1	0.0 A		DIRECT	120"	EC BTC 120V FROM CONTROL PANEL FOR LIGHTS. EC TO PROVIDE LOW VOLTAGE CONDUIT AND WIRE TO CONTROL PANEL REQUIRED FOR HOOD TEMP SENSOR
61	1	STEAMER, GAS	120 V	1	2.0 A		CORD & PLUG	24"	
63	1	FWER, GAS	120 V	1	12.0 A		CORD & PLUG	24"	
66	1	REFRIGERATED EQUIPMENT STAND	120 V	1	2.7 A		CORD & PLUG	24"	
67	1	4-BURNER RANGE W/ CONVECTION OVEN BASE	120 V	1	5.9 A	1/2	CORD & PLUG	24"	
80	5	RETRACTABLE HEAT LAMPS	120 V	1	3.1 A		DIRECT	120"	EC TO MOUNT JUNCTION BOX DIRECTLY ABOVE FINISHED CEILING. REFER TO SPEC SHEET
82	1	DROP-IN HOT WELL	120 V	1	10.0 A		CORD & PLUG	24"	
93	1	PIZZA PREP TABLE	120 V	1	6.5 A		CORD & PLUG	24"	
91	1	COFFEE/TEA BREWER	120 V	1	25.0 A		DIRECT	48"	
94	1	SODA/ICE DISPENSER	120 V	1	15.0 A		CORD & PLUG	48"	
109	2	COCKTAIL PREP COOLER	120 V	1	2.2 A	1/8	CORD & PLUG	24"	
111	1	KEG COOLER	120 V	1	3.5 A	1/6	CORD & PLUG	24"	
111.1	1	KEG COOLER	120 V	1	3.5 A	1/6	CORD & PLUG	24"	
112	1	LARGE SQUARE ICE CUBER	115 V	1	5.0 A		CORD & PLUG	24"	
115	1	UNDERCOUNTER DISHMACHINE	208 V	3	22.0 A	1	DIRECT	24"	
117	1	WINE COOLER, 2-ZONE	120 V	1	2.8 A	1/8	CORD & PLUG	24"	
121	1	BACK BAR COOLER	120 V	1	2.8 A	1/8	CORD & PLUG	24"	
122	1	BLENDER STATION, FILLER BOARD	120 V	1	20.0 A		CORD & PLUG	12"	EC TO PROVIDE OUTLET. BTC TO JUNCTION BOX INCLUDED BELOW WORK SURFACE
124	1	ESPRESSO MACHINE	120 V	1	15.0 A		DIRECT	24"	EC TO VERIFY REQUIREMENTS PRIOR TO ROUGHING IN. RUN CORD THRU GROMMET IN COUNTERTOP. REFER TO SPEC SHEET
125	1	ESPRESSO GRINDER	120 V	1	2.1 A		CORD & PLUG	24"	EC TO RUN CORD THRU GROMMET IN COUNTERTOP
POS	1	POS TABLET SYSTEM	120 V	1	15.0 A		CORD & PLUG	24"	DEDICATED CIRCUIT; EC TO PROVIDE QUAD RECEPTACLE & DATA BOX

### ELECTRIC - CONVENIENCE RECEPTACLE SCHEDULE

ITEM NUMBER	COUNT	DESCRIPTION	VOLTS	PHASE	AMPS	ELECTRICAL REMARKS
CR1	3	CONVENIENCE RECEPTACLE	120 V	1	20 A	EC TO PROVIDE 120V CONVENIENCE OUTLET AT ROUGH-IN HEIGHT SHOWN ON PLAN
CR2	2	DROP CORD	120 V	1	20 A	EC TO PROVIDE RETRACTABLE DROP CORD

### Electrical Symbols

All symbols may not be to same scale as on the drawing.

- XXX Rough-In Number
- X-1 Detail Drawing Reference
- CR1 120V/1P/20A For Duplex Convenience Outlet
- CR2 208V/1P/20A For Convenience Outlet
- CR3 120V Single Receptacle
- CR4 120V Duplex Receptacle
- CR5 120V Quad Receptacle
- CR6 208/220V Receptacle
- CR7 Wall Switch (Multiple Examples)
- CR8 Electrical Connection/ Junction Box
- CR9 Communication (Data) Outlet
- CR10 Disconnect Switch
- CR11 Conduit
- CR12 Electric Stub-Up

REFER TO ELECTRICAL SCHEDULE FOR EQUIPMENT ELECTRICAL REQUIREMENTS

**Singer Equipment Company**  
 180 Heller Place,  
 Bellmawr, NJ  
 08030  
 856-559-4200

COPYRIGHT, THESE DOCUMENTS IN PART OR IN WHOLE, AND THE DESIGN THEY REPRESENT, ARE THE SOLE PROPERTY OF SINGER EQUIPMENT COMPANY. THESE DOCUMENTS ARE INTENDED FOR THE PROJECT ON SITE INDICATED. ANY USE, REPRODUCTION, MODIFICATION OR ADOPTION WITHOUT THE EXPRESS WRITTEN CONSENT OF SINGER EQUIPMENT COMPANY IS STRICTLY PROHIBITED.

**JOB NAME:**  
**Sanctuary Golf**

**ADDRESS:**  
 25191 Chamber of Commerce Dr  
 Bonita Springs  
 FL 34135

**PROJECT #:** ---  
**DRAWN BY:** JL  
**CHECKED BY:** XXX



#### SUBMITTALS & REVISIONS

REV	DATE	NAME	DESCRIPTION
	07-22-25		Design development
	07-25-25		Design development
	08-04-25		Full Set
1	08-19-25	JL	Revisions per owner

**SHEET NAME:**  
**Electric Rough-in Plan**

**SCALE:** 1/4" = 1'-0"

**DRAWING SHEET NO.**  
**FS1.30**

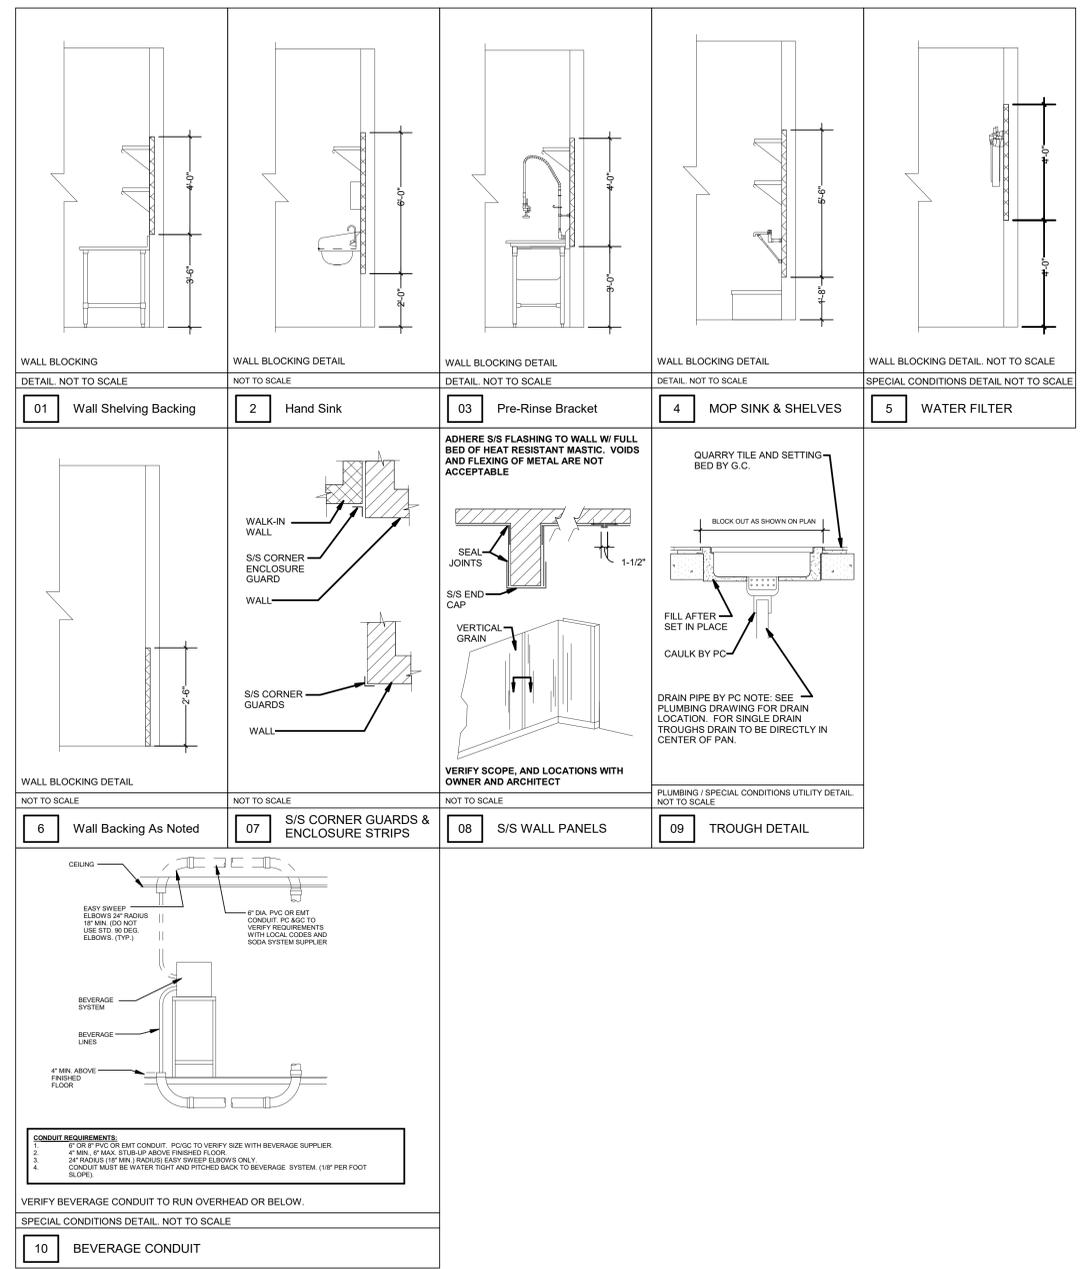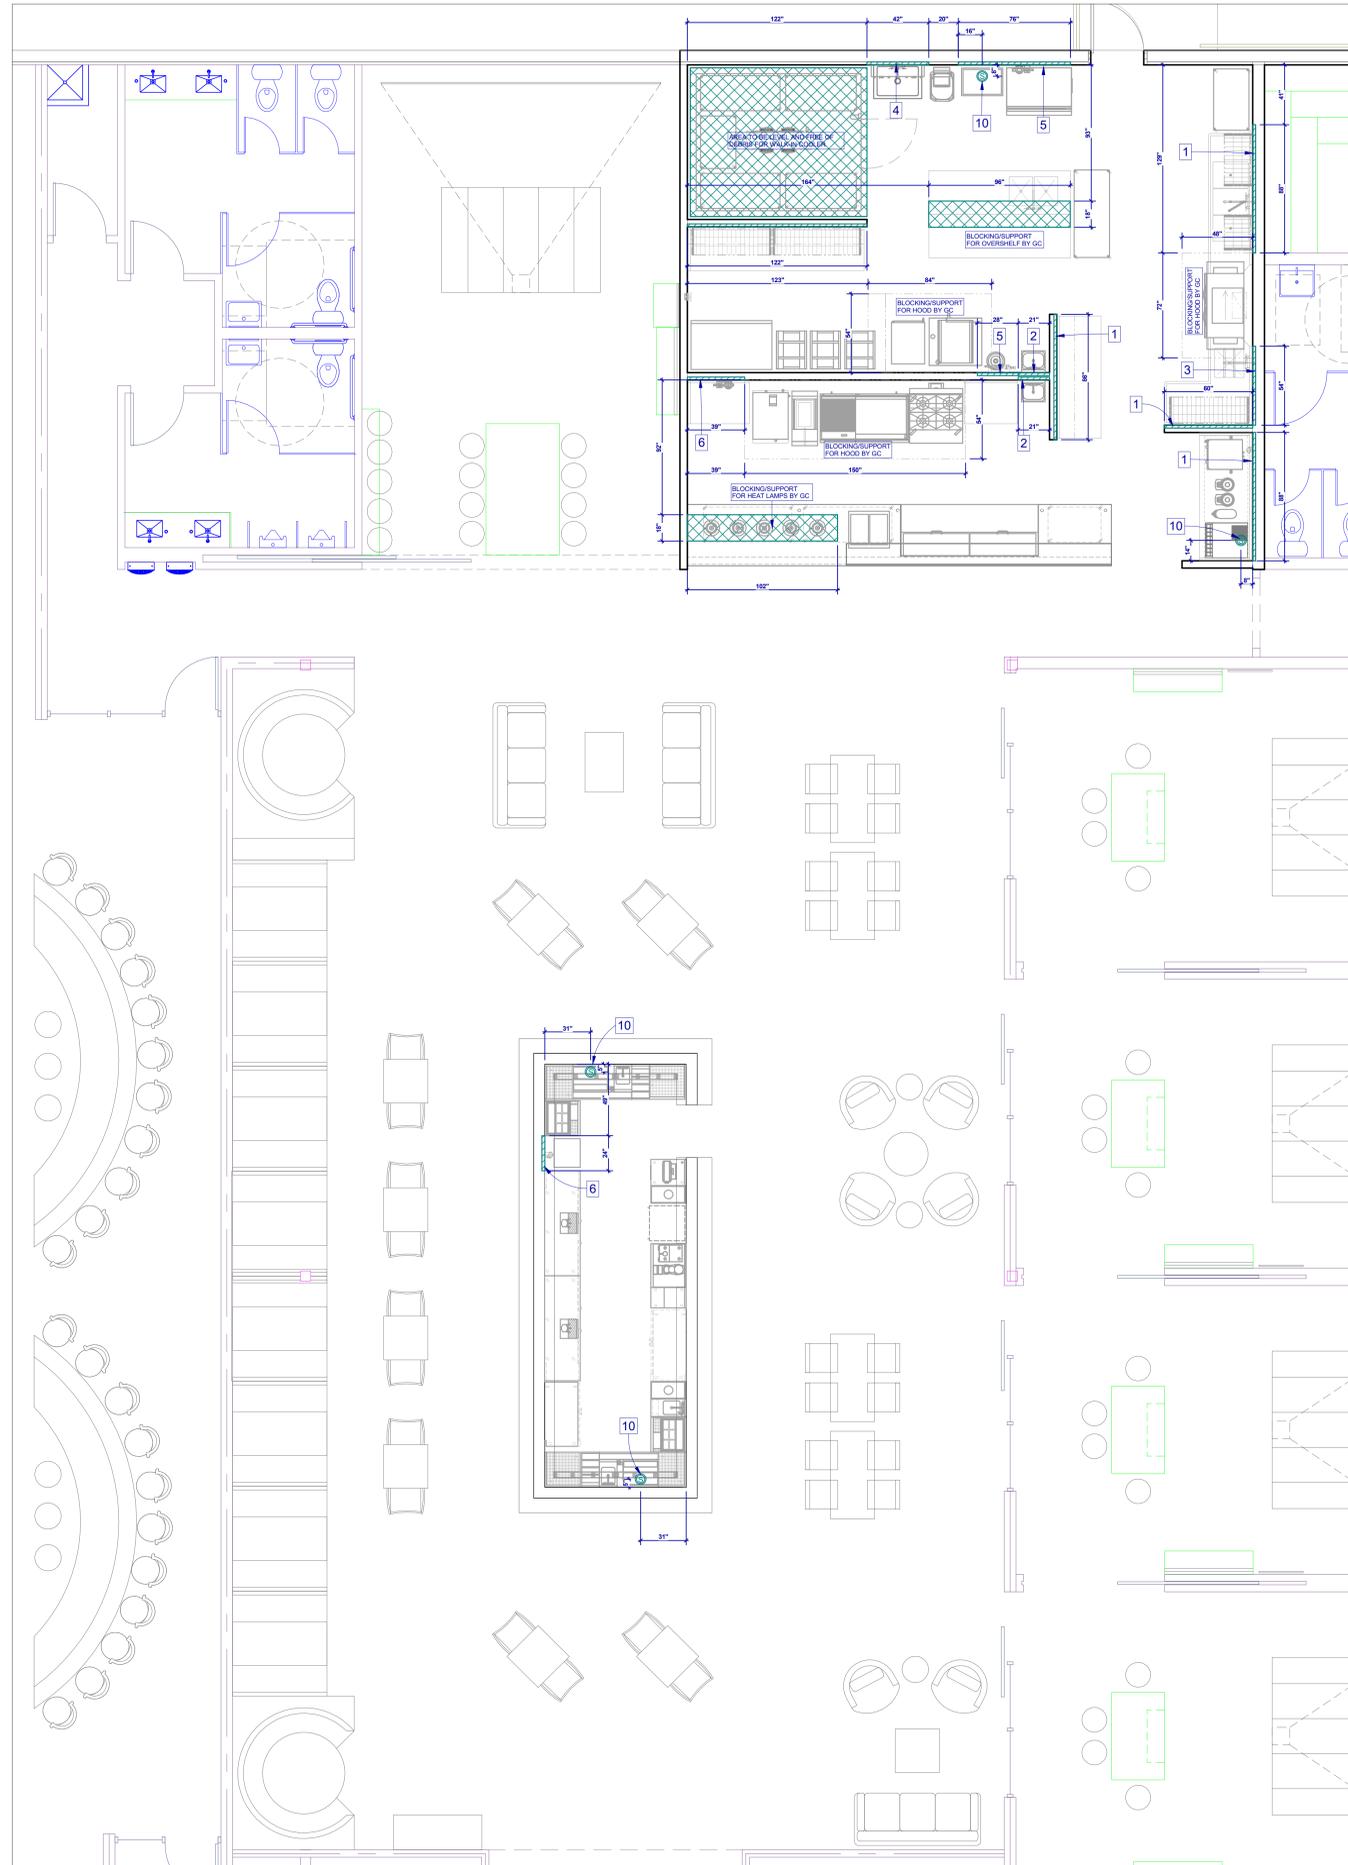

**Special Conditions Symbols**

All symbols may not be to same scale as on the drawing.

XXX	Rough-IN Number
X	Detail Drawing Reference
⊕	Soda Conduit, Lines Bundle
⊕	Beer Conduit, Lines Bundle
⊕	Wine Conduit, Lines Bundle
⊕	Chilled Drinking Water Line
⊕	Refrigeration Line
L	S/S Corner Guard
- - -	S/S Wall Cladding
▬	Wall Backing
▬	Return Duct
▬	Supply Duct

**Singer Equipment Company**

180 Heller Place,  
Bellmawr, NJ  
08030

856-559-4200

COPYRIGHT, THESE DOCUMENTS IN PART OR IN WHOLE, AND THE DESIGN THEY REPRESENT, ARE THE SOLE PROPERTY OF SINGER EQUIPMENT COMPANY. THESE DOCUMENTS ARE INTENDED FOR THE PROJECT ON SITE INDICATED. ANY USE, REPRODUCTION, MODIFICATION OR ADOPTION WITHOUT THE EXPRESS WRITTEN CONSENT OF SINGER EQUIPMENT COMPANY IS STRICTLY PROHIBITED.

**JOB NAME:**  
**Sanctuary Golf**

**ADDRESS:**  
25191 Chamber of Commerce Dr  
Bonita Springs  
FL 34135

**PROJECT #:** ---  
**DRAWN BY:** JL  
**CHECKED BY:** XXX

**SUBMITTALS & REVISIONS**

REV	DATE	NAME	DESCRIPTION
07-22-25			Design development
07-25-25			Design development
08-04-25			Full Set
1	08-19-25	JL	Revisions per owner

**SHEET NAME:**  
**Special Conditions Plan**

**SCALE:** 1/4" = 1'-0"

**DRAWING SHEET NO.**  
**FS1.40**

ELEVATION DRAWINGS ARE FOR REFERENCE USE ONLY. FABRICATION AND MILLWORKS DRAWING ARE FOR REFERENCE ONLY AND GENERAL INTENT. SEE FINAL APPROVED MANUFACTURE DETAILS DRAWINGS.



**Singer  
Equipment  
Company**

180 Heller Place,  
Bellmawr, NJ  
08030

856-559-4200

COPYRIGHT, THESE DOCUMENTS IN PART OR IN WHOLE, AND THE DESIGN THEY REPRESENT, ARE THE SOLE PROPERTY OF SINGER EQUIPMENT COMPANY. THESE DOCUMENTS ARE INTENDED FOR THE PROJECT ON SITE INDICATED. ANY USE, REPRODUCTION, MODIFICATION OR ADOPTION WITHOUT THE EXPRESS WRITTEN CONSENT OF SINGER EQUIPMENT COMPANY IS STRICTLY PROHIBITED.

JOB NAME:

**Sanctuary  
Golf**

ADDRESS:

25191 Chamber of  
Commerce Dr  
Bonita Springs  
FL 34135


PROJECT #: ---

DRAWN BY: JL


CHECKED BY: XXX

**SUBMITTALS & REVISIONS**



REV	DATE	NAME	DESCRIPTION
07-22-25			Design development
07-25-25			Design development
08-04-25			Full Set
1	08-19-25	JL	Revisions per owner

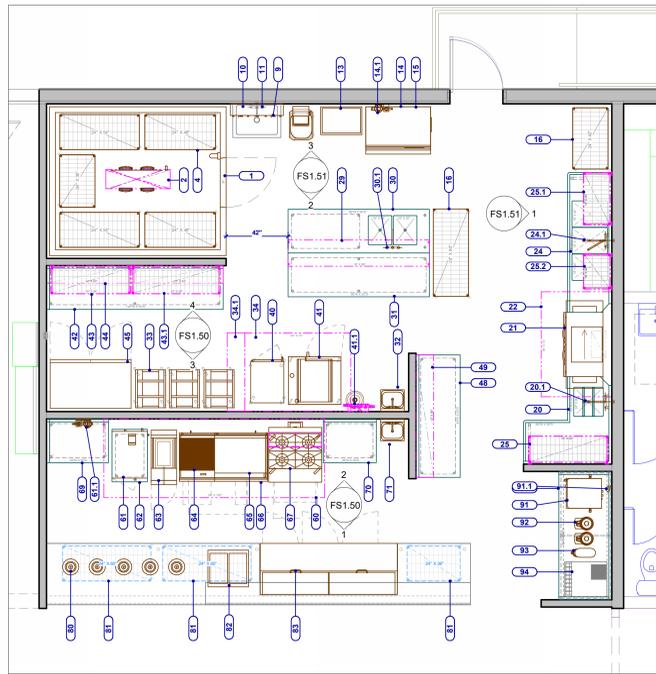


A Floor 1 - Layout View Elev.  
1/4" = 1'-0"

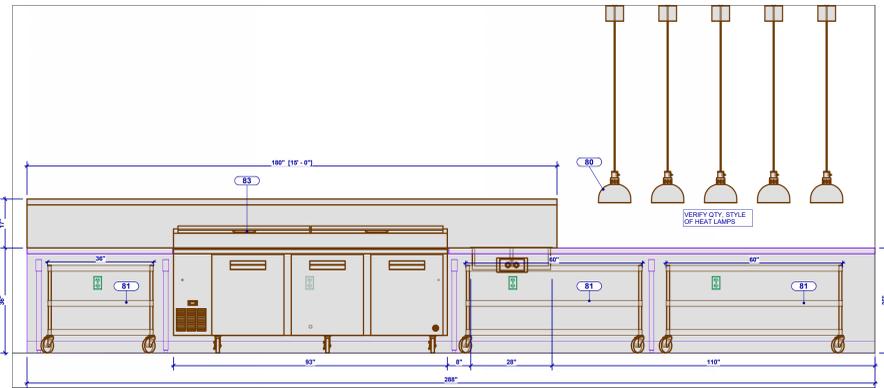


1 Chefs Counter  
1/2" = 1'-0"

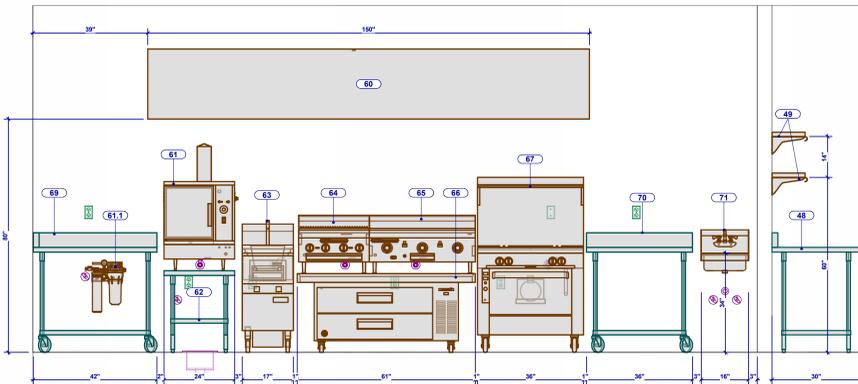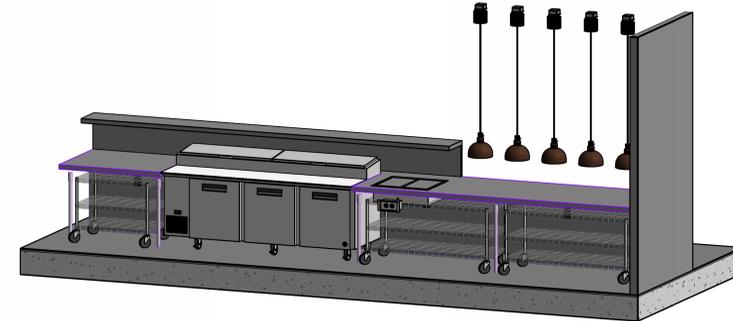




2 Cookline  
1/2" = 1'-0"

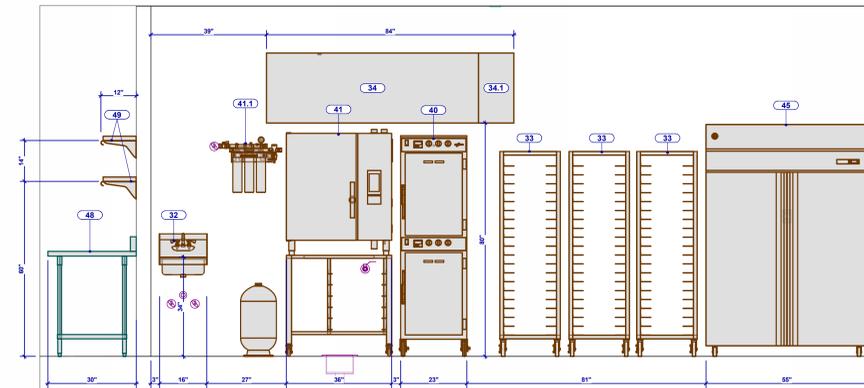

3 Prep Cookline  
1/2" = 1'-0"

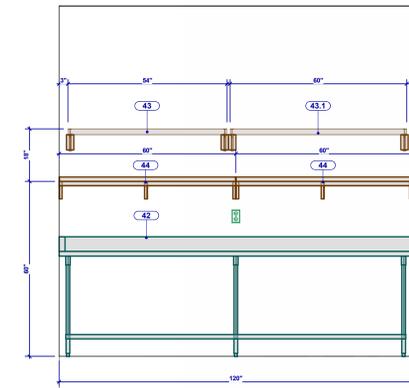

4 Prep  
1/2" = 1'-0"

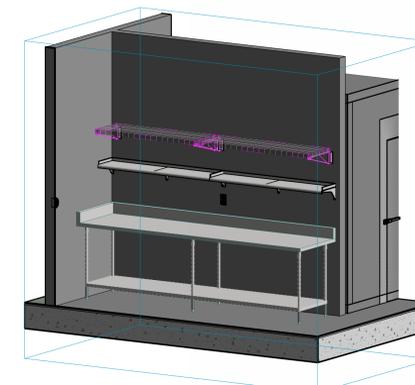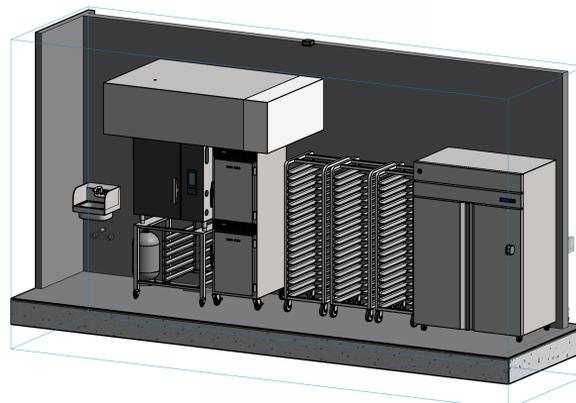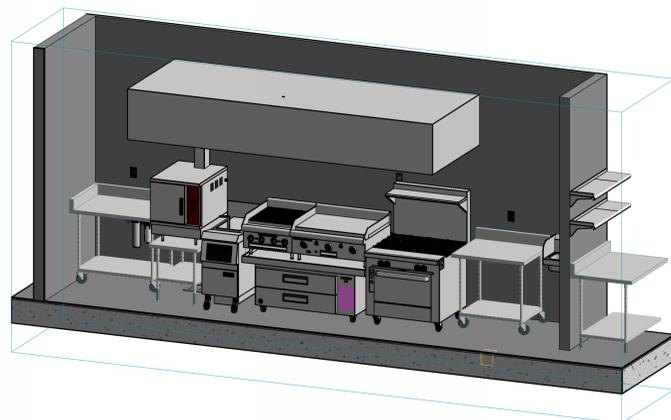

SHEET NAME:

**Equipment  
Elevations**

SCALE: As indicated

DRAWING SHEET NO.

**FS1.50**

ELEVATION DRAWINGS ARE FOR REFERENCE USE ONLY. FABRICATION AND MILLWORKS DRAWING ARE FOR REFERENCE ONLY AND GENERAL INTENT. SEE FINAL APPROVED MANUFACTURE DETAILS DRAWINGS.



**Singer  
Equipment  
Company**

180 Heller Place,  
Bellmawr, NJ  
08030

856-559-4200

COPYRIGHT, THESE DOCUMENTS IN PART OR IN WHOLE, AND THE DESIGN THEY REPRESENT, ARE THE SOLE PROPERTY OF SINGER EQUIPMENT COMPANY. THESE DOCUMENTS ARE INTENDED FOR THE PROJECT ON SITE INDICATED. ANY USE, REPRODUCTION, MODIFICATION OR ADOPTION WITHOUT THE EXPRESS WRITTEN CONSENT OF SINGER EQUIPMENT COMPANY IS STRICTLY PROHIBITED.

JOB NAME:

**Sanctuary  
Golf**

ADDRESS:

25191 Chamber of  
Commerce Dr  
Bonita Springs  
FL 34135


PROJECT #: ---

DRAWN BY: JL


CHECKED BY: XXX

**SUBMITTALS & REVISIONS**


REV	DATE	NAME	DESCRIPTION
07-22-25			Design development
07-25-25			Design development
08-04-25			Full Set
1	08-19-25	JL	Revisions per owner

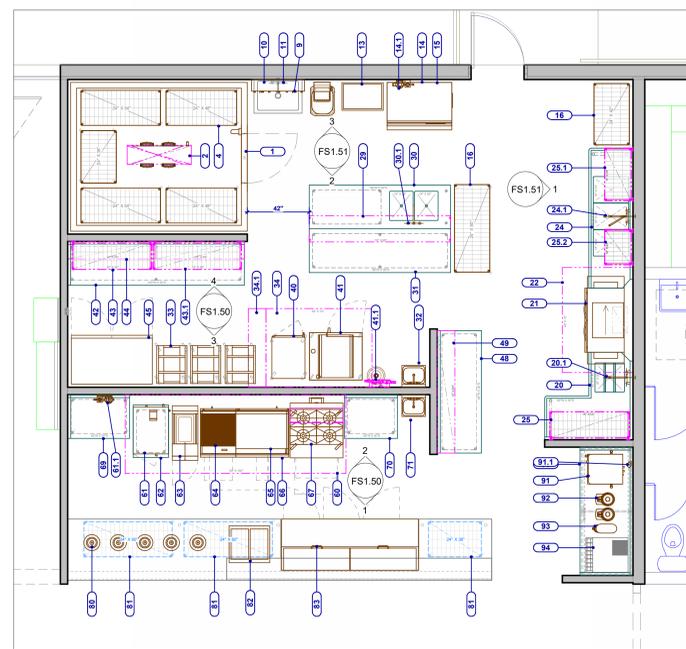


Ⓐ Floor 1 - Layout View Elev. 2  
1/4" = 1'-0"

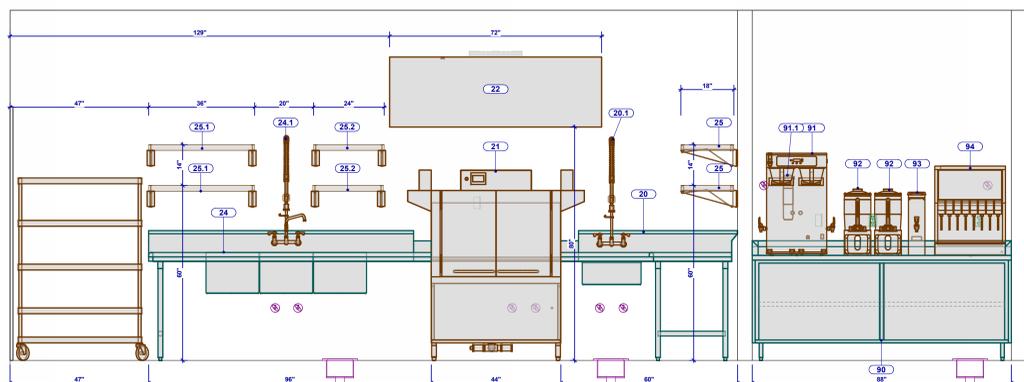




① Dishroom, Beverage Counter  
1/2" = 1'-0"

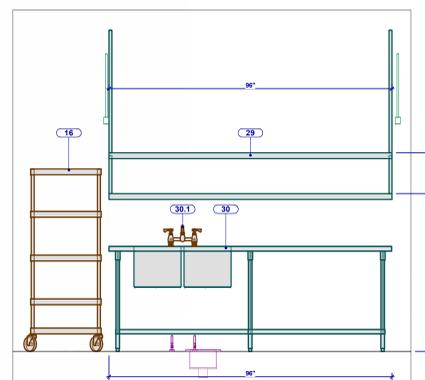

② Prep Island  
1/2" = 1'-0"

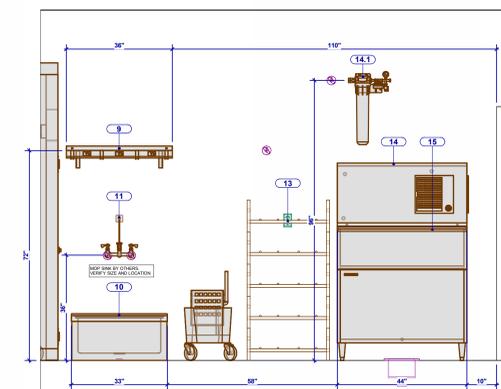

③ Mop Sink, Ice  
1/2" = 1'-0"

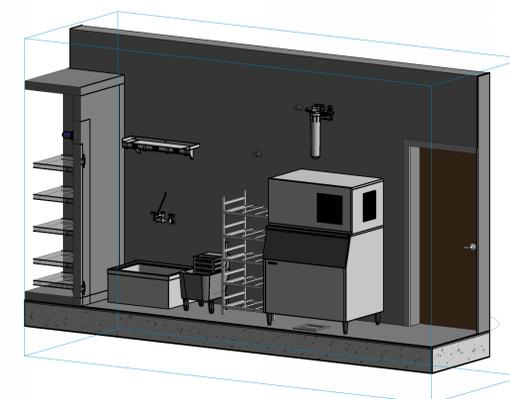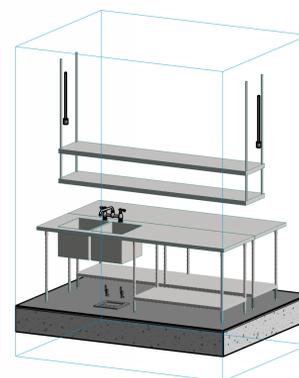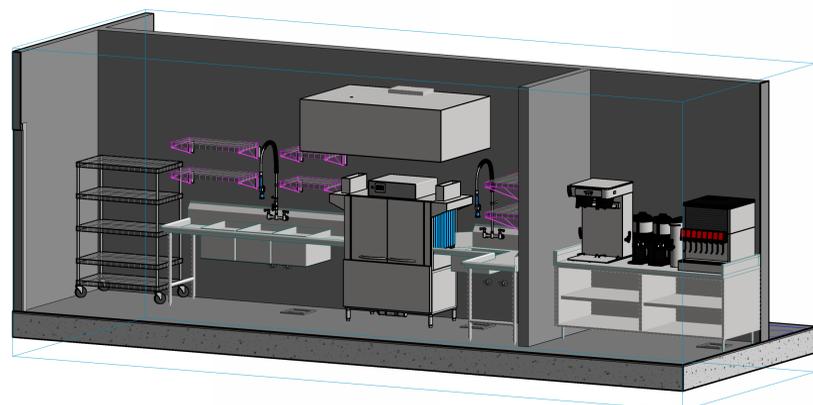

SHEET NAME:

**Equipment  
Elevations**

SCALE: As indicated

DRAWING SHEET NO.

**FS1.51**

