

PROJECT GLAMMERS

633 TAMiami TRAIL N, SUITE #201
NAPLES, FLORIDA

REVISIONS

NO.	DATE	DESCRIPTION

DRAWING SET

CONSTRUCTION
DOCUMENTS
7/14/2026

PROJECT MANAGER: RTM
DRAWN / CHECKED: GAB/ RTM

PROJECT NUMBER
26-42

SHEET TITLE
NOTE &
DIMENSION
PLAN

SHEET NUMBER

A4.0

GENERAL NOTES


- COORDINATION OF CONSTRUCTION, INCLUDING VERIFICATION OF DIMENSIONS AND FIELD CONDITIONS, IS THE RESPONSIBILITY OF THE CONTRACTOR. ANY DISCREPANCIES SHALL BE BROUGHT TO THE ATTENTION OF THE DESIGN FIRM PRIOR TO CONSTRUCTION.
- ALL ELECTRICAL SYSTEMS, EQUIPMENT, HEATING, VENTILATING, AIR CONDITIONING, PLUMBING FIXTURES AND OTHER SYSTEMS TO BE AT OR ABOVE DESIGNED FLOOR ELEVATION. NO EQUIPMENT OR SYSTEMS LISTED ABOVE ARE TO BE INSTALLED BELOW DESIGNED FLOOD ELEVATION.

GENERAL DIM. NOTES

- COORDINATION OF CONSTRUCTION, INCLUDING VERIFICATION OF DIMENSIONS AND FIELD CONDITIONS, IS THE RESPONSIBILITY OF THE CONTRACTOR. ANY DISCREPANCIES SHALL BE BROUGHT TO THE ATTENTION OF THE DESIGN FIRM PRIOR TO CONSTRUCTION.

2ND FLOOR KEY PLAN

SCALE: NOT TO SCALE

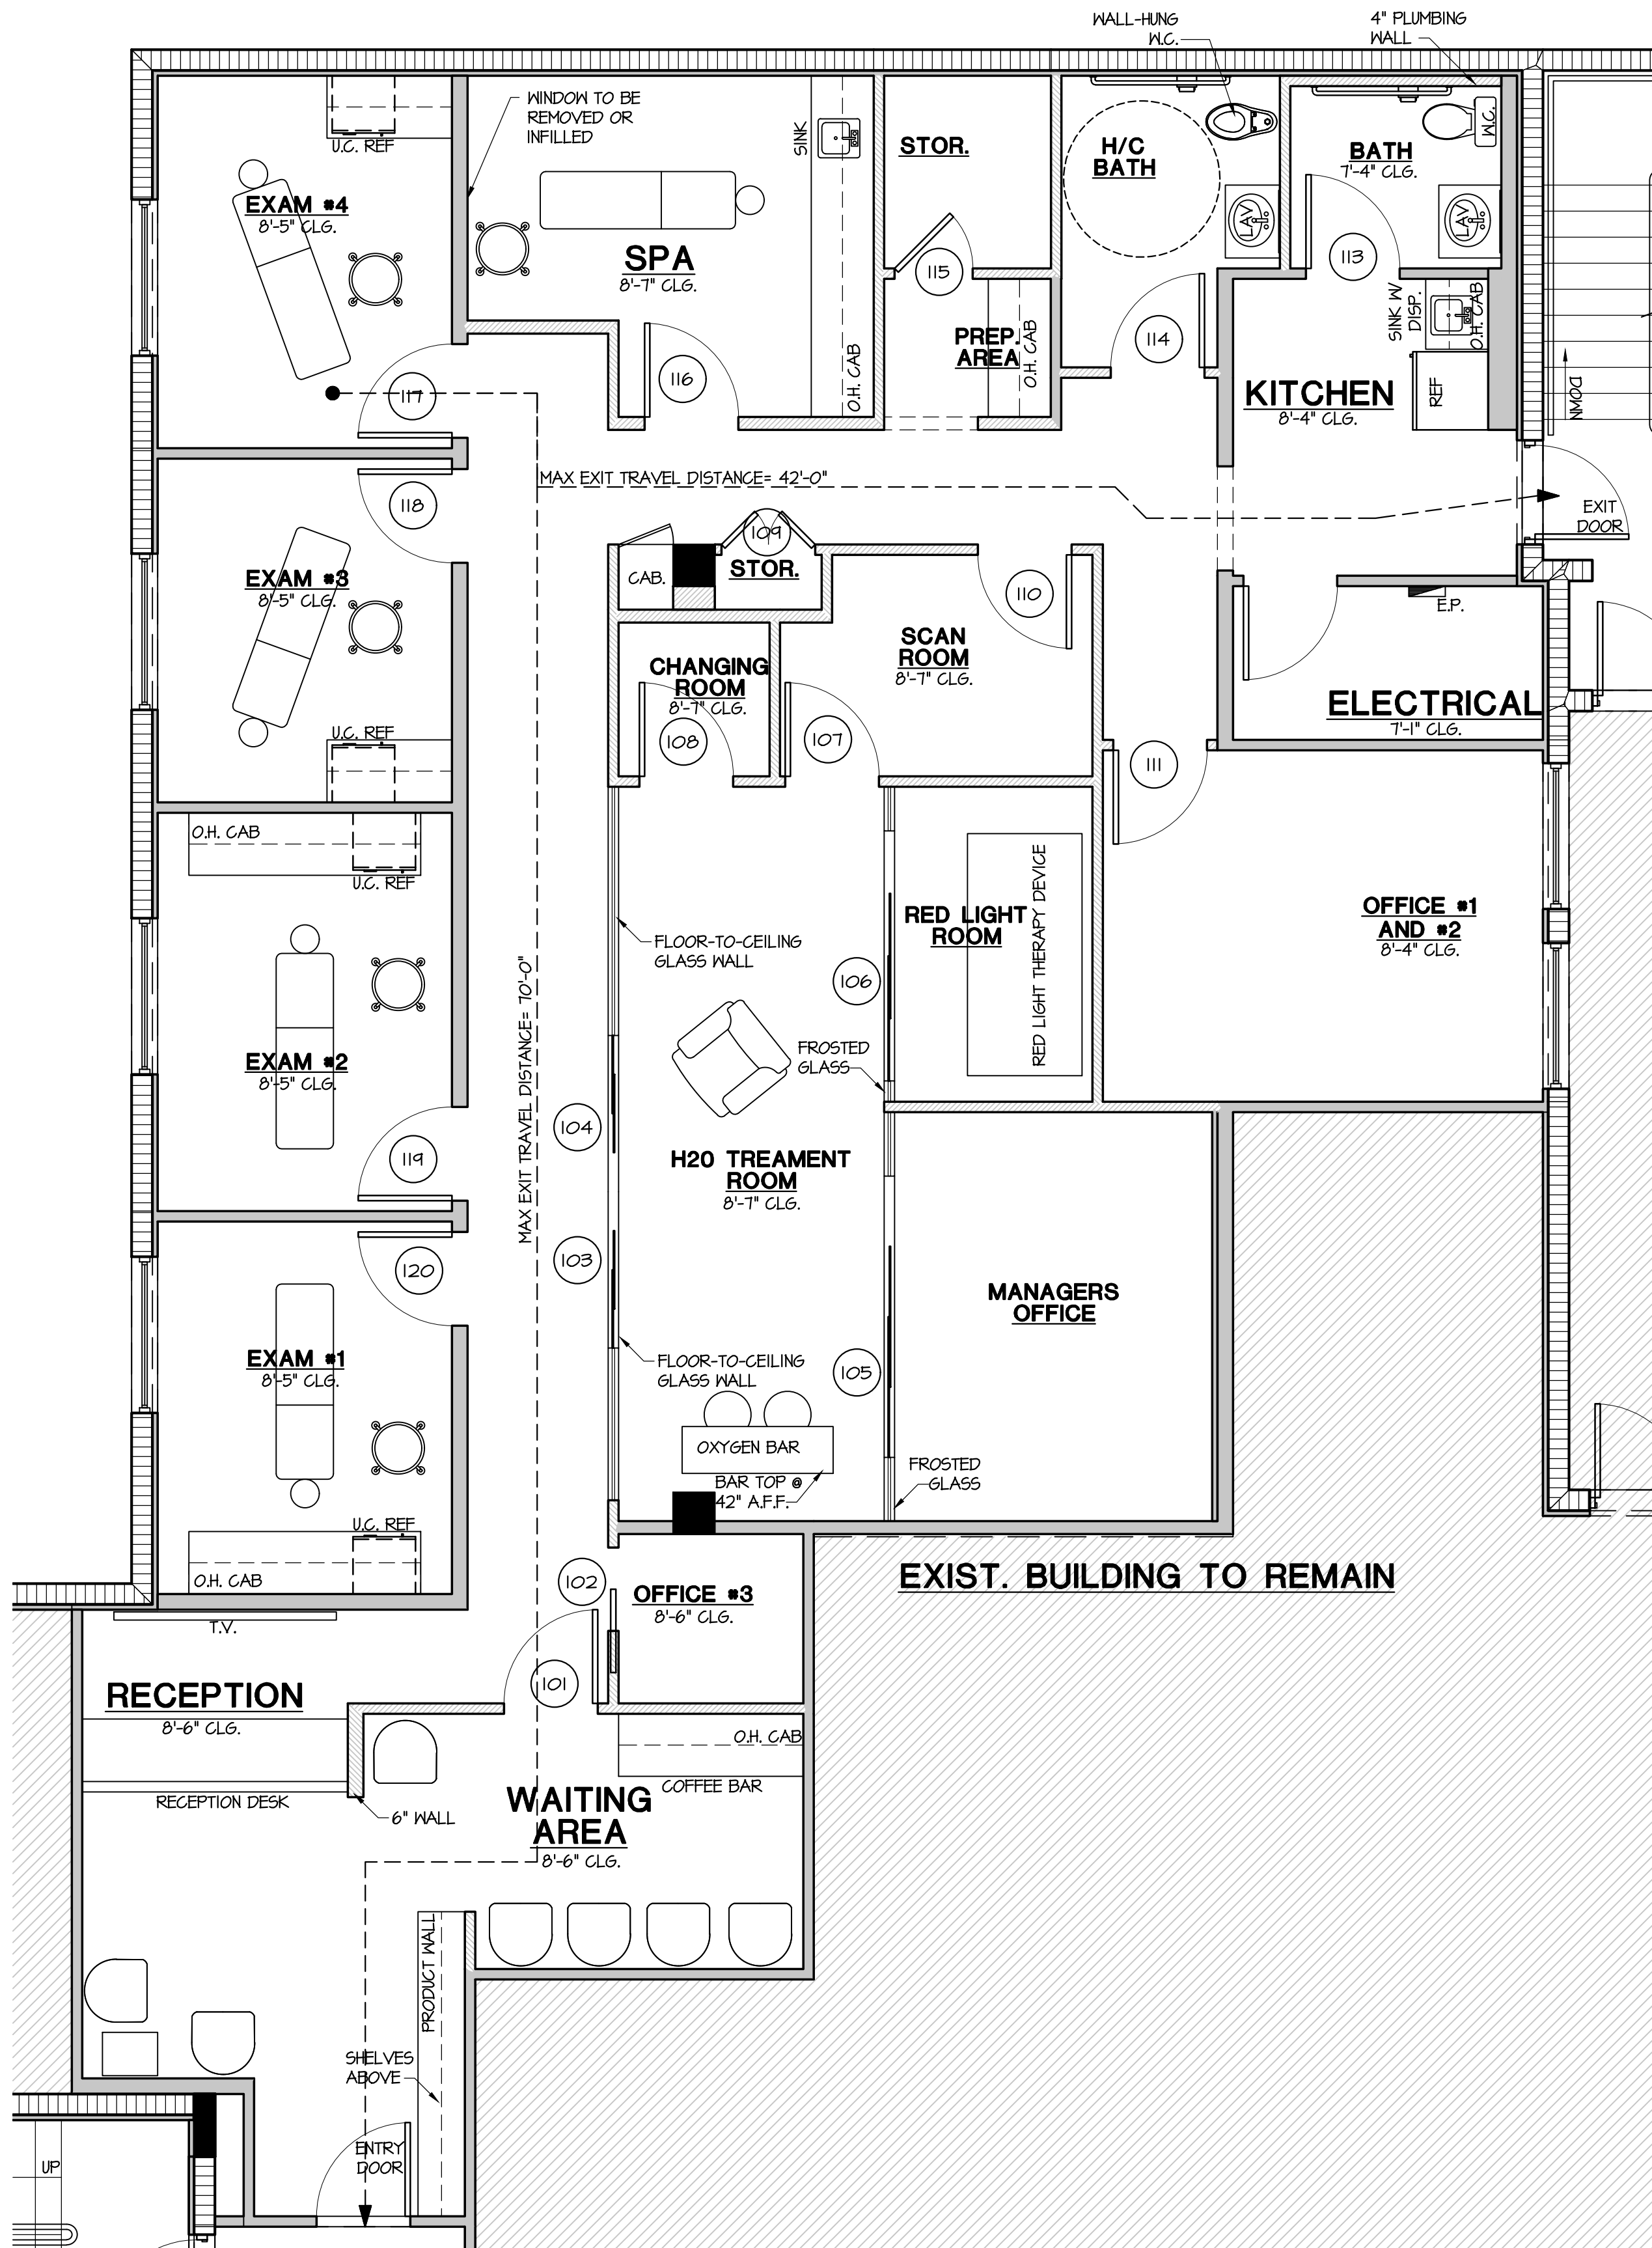

WALL
LEGEND

EXISTING STUD WALL

EXISTING CMU WALL

NEW STUD WALL

FIRE SPRINKLER
NOTE


THIS BUILDING IS EQUIPPED WITH AN EXISTING NFPA 13 FIRE SPRINKLER SYSTEM. THE MODIFICATIONS TO THIS SYSTEM WILL IMPACT LESS THAN 50 HEADS. ALL MODIFICATIONS TO THIS SYSTEM WILL BE UNDER A SEPARATE PERMIT, PULLED BY A LICENSED FIRE SPRINKLER CONTRACTOR DEPICTING ALL REQUIRED MODIFICATIONS AND ADDITIONS TO THE EXISTING SYSTEM.

FIRE ALARM
NOTE

THIS BUILDING IS EQUIPPED WITH AN EXISTING FIRE ALARM SYSTEM. THE MODIFICATIONS FOR THIS SYSTEM WILL BE LESS THAN \$5,000 AND WILL BE UNDER A SEPARATE PERMIT PULLED BY A LICENSED FIRE ALARM CONTRACTOR DEPICTING ALL REQUIRED MODIFICATIONS AND ADDITIONS TO THE EXISTING SYSTEM TO PROVIDE COVERAGE IN ACCORDANCE WITH NFPA 72.

NOTE PLAN

SCALE: 1/4" = 1'-0"

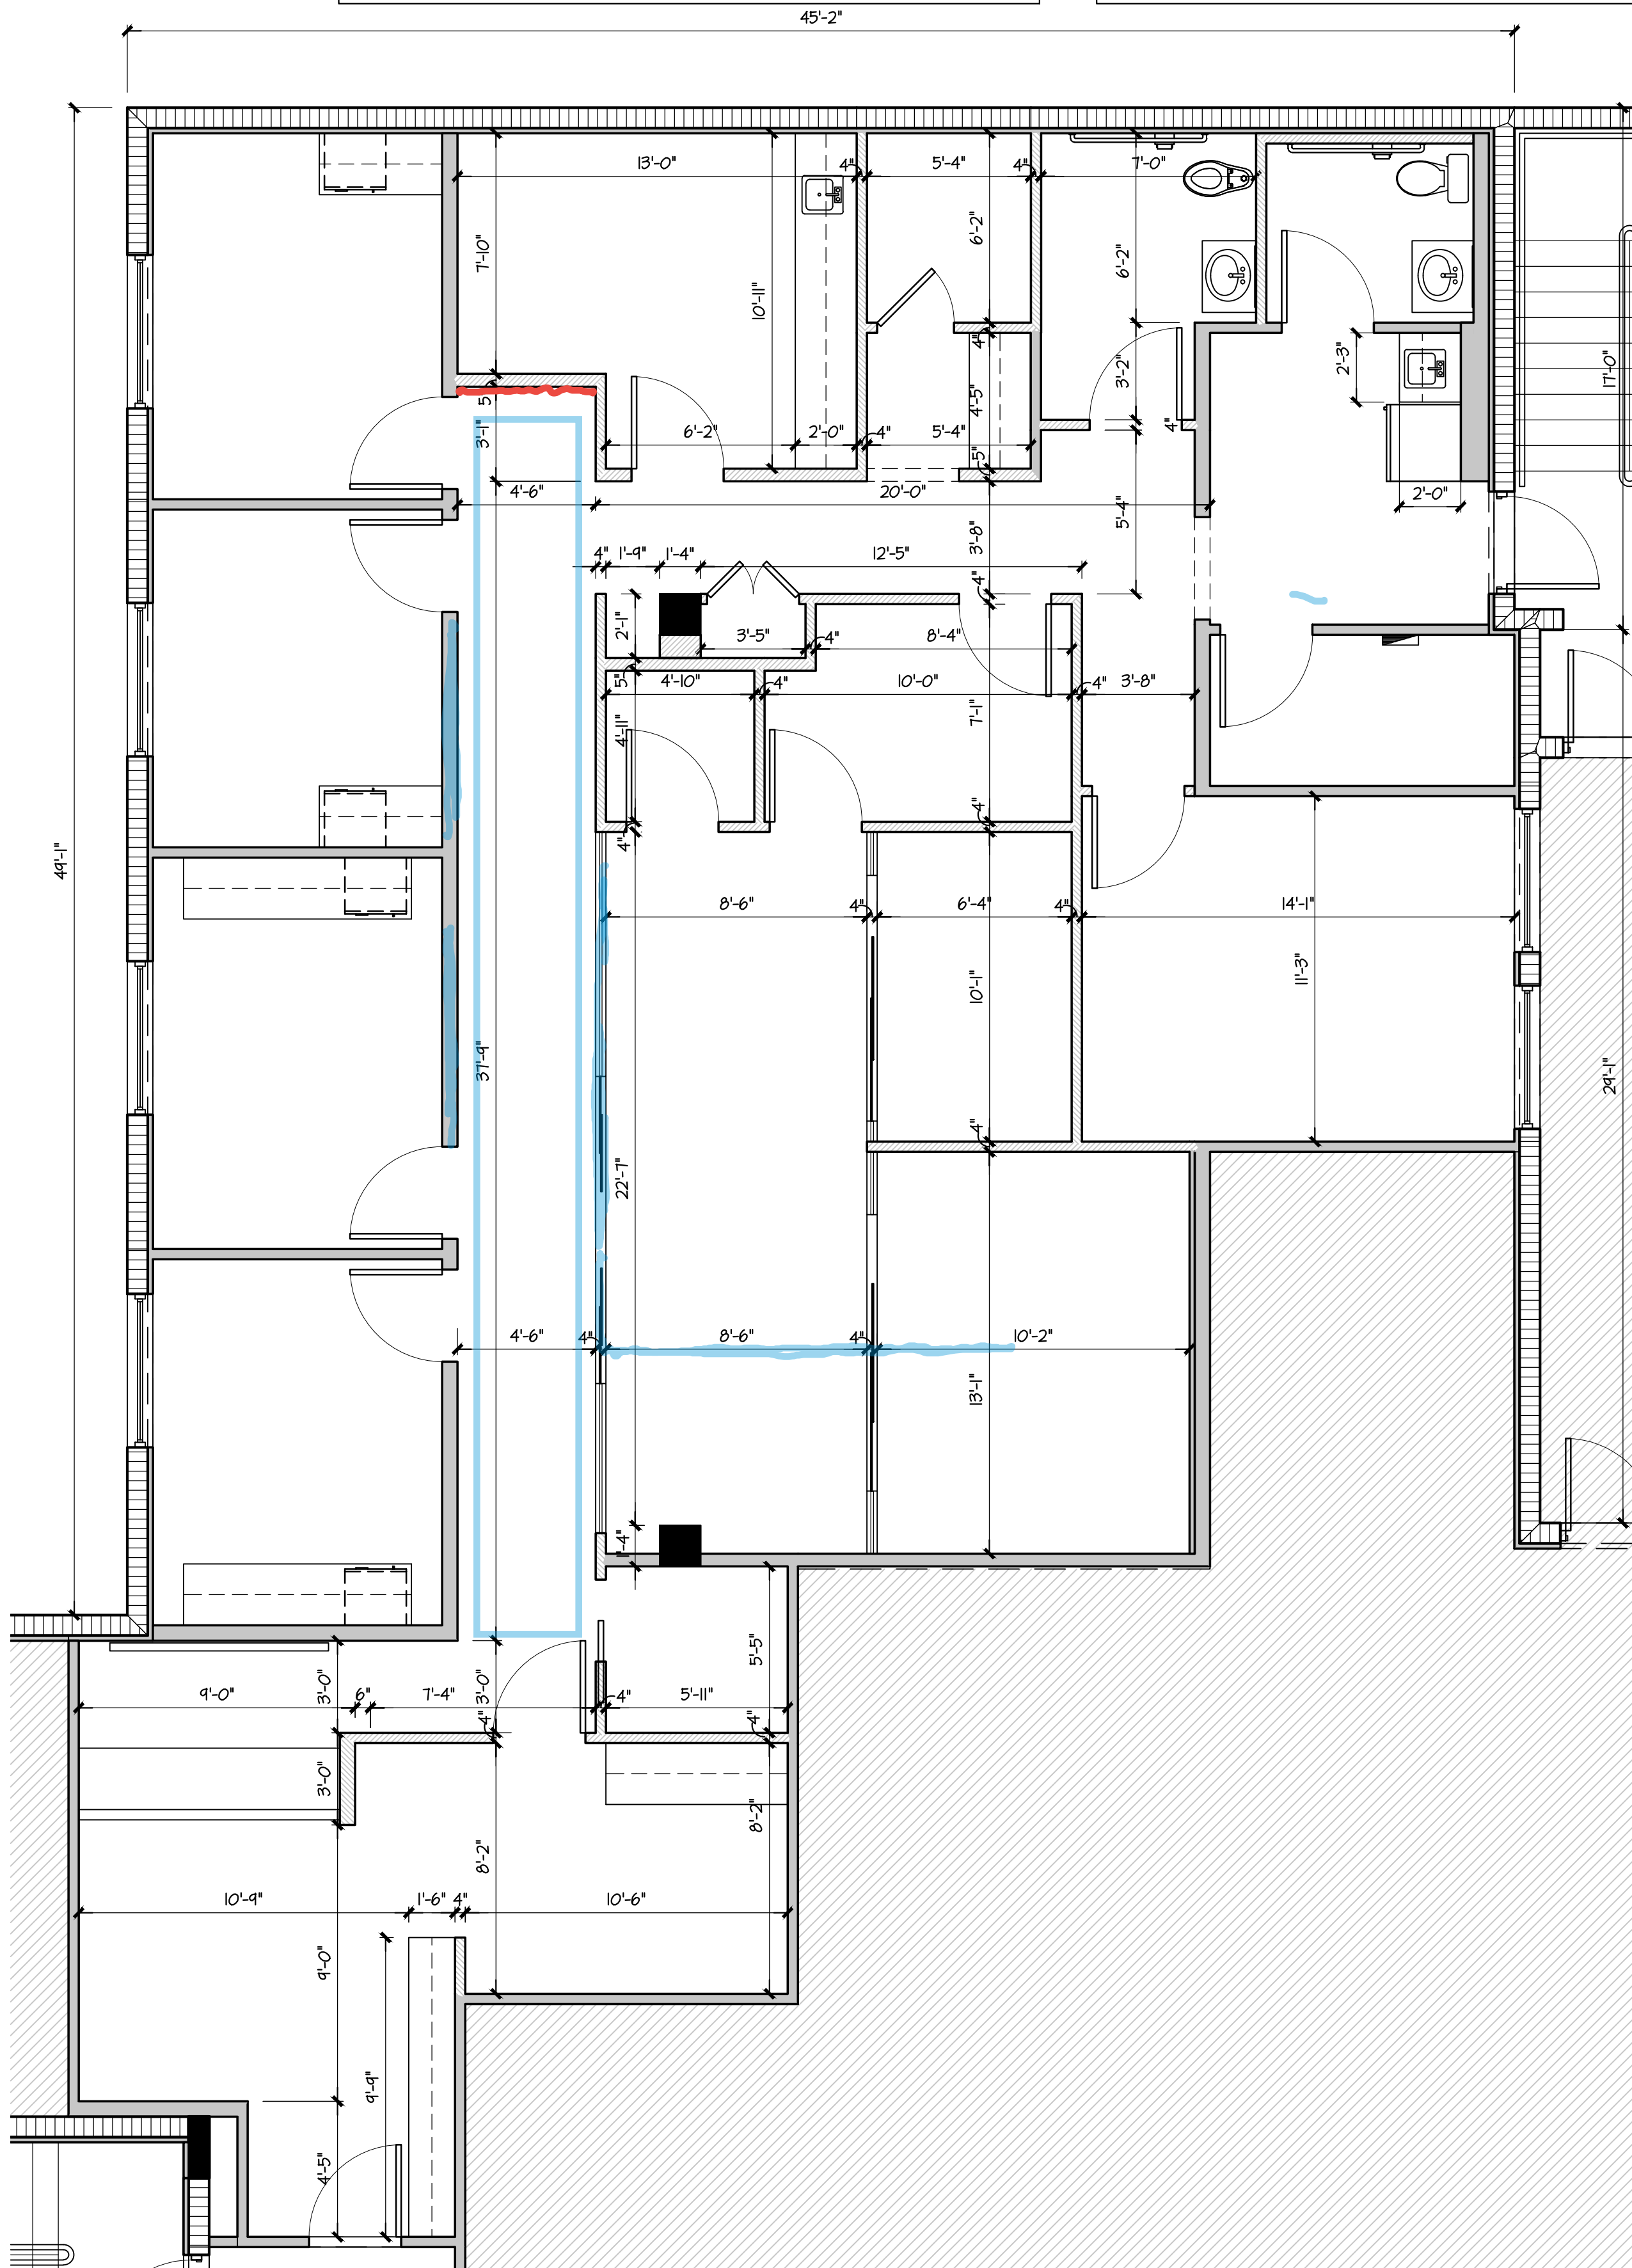

DIMENSION PLAN

SCALE: 1/4" = 1'-0"