



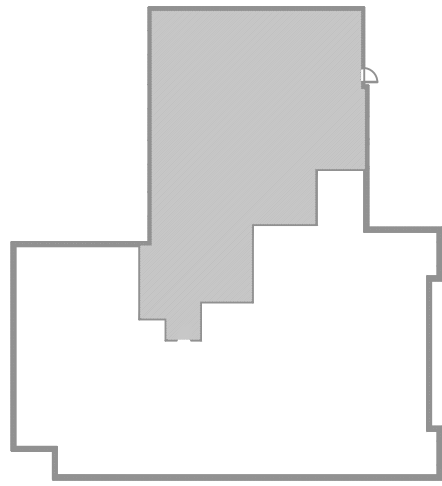

2ND FLOOR KEY PLAN

SCALE: NOT TO SCALE

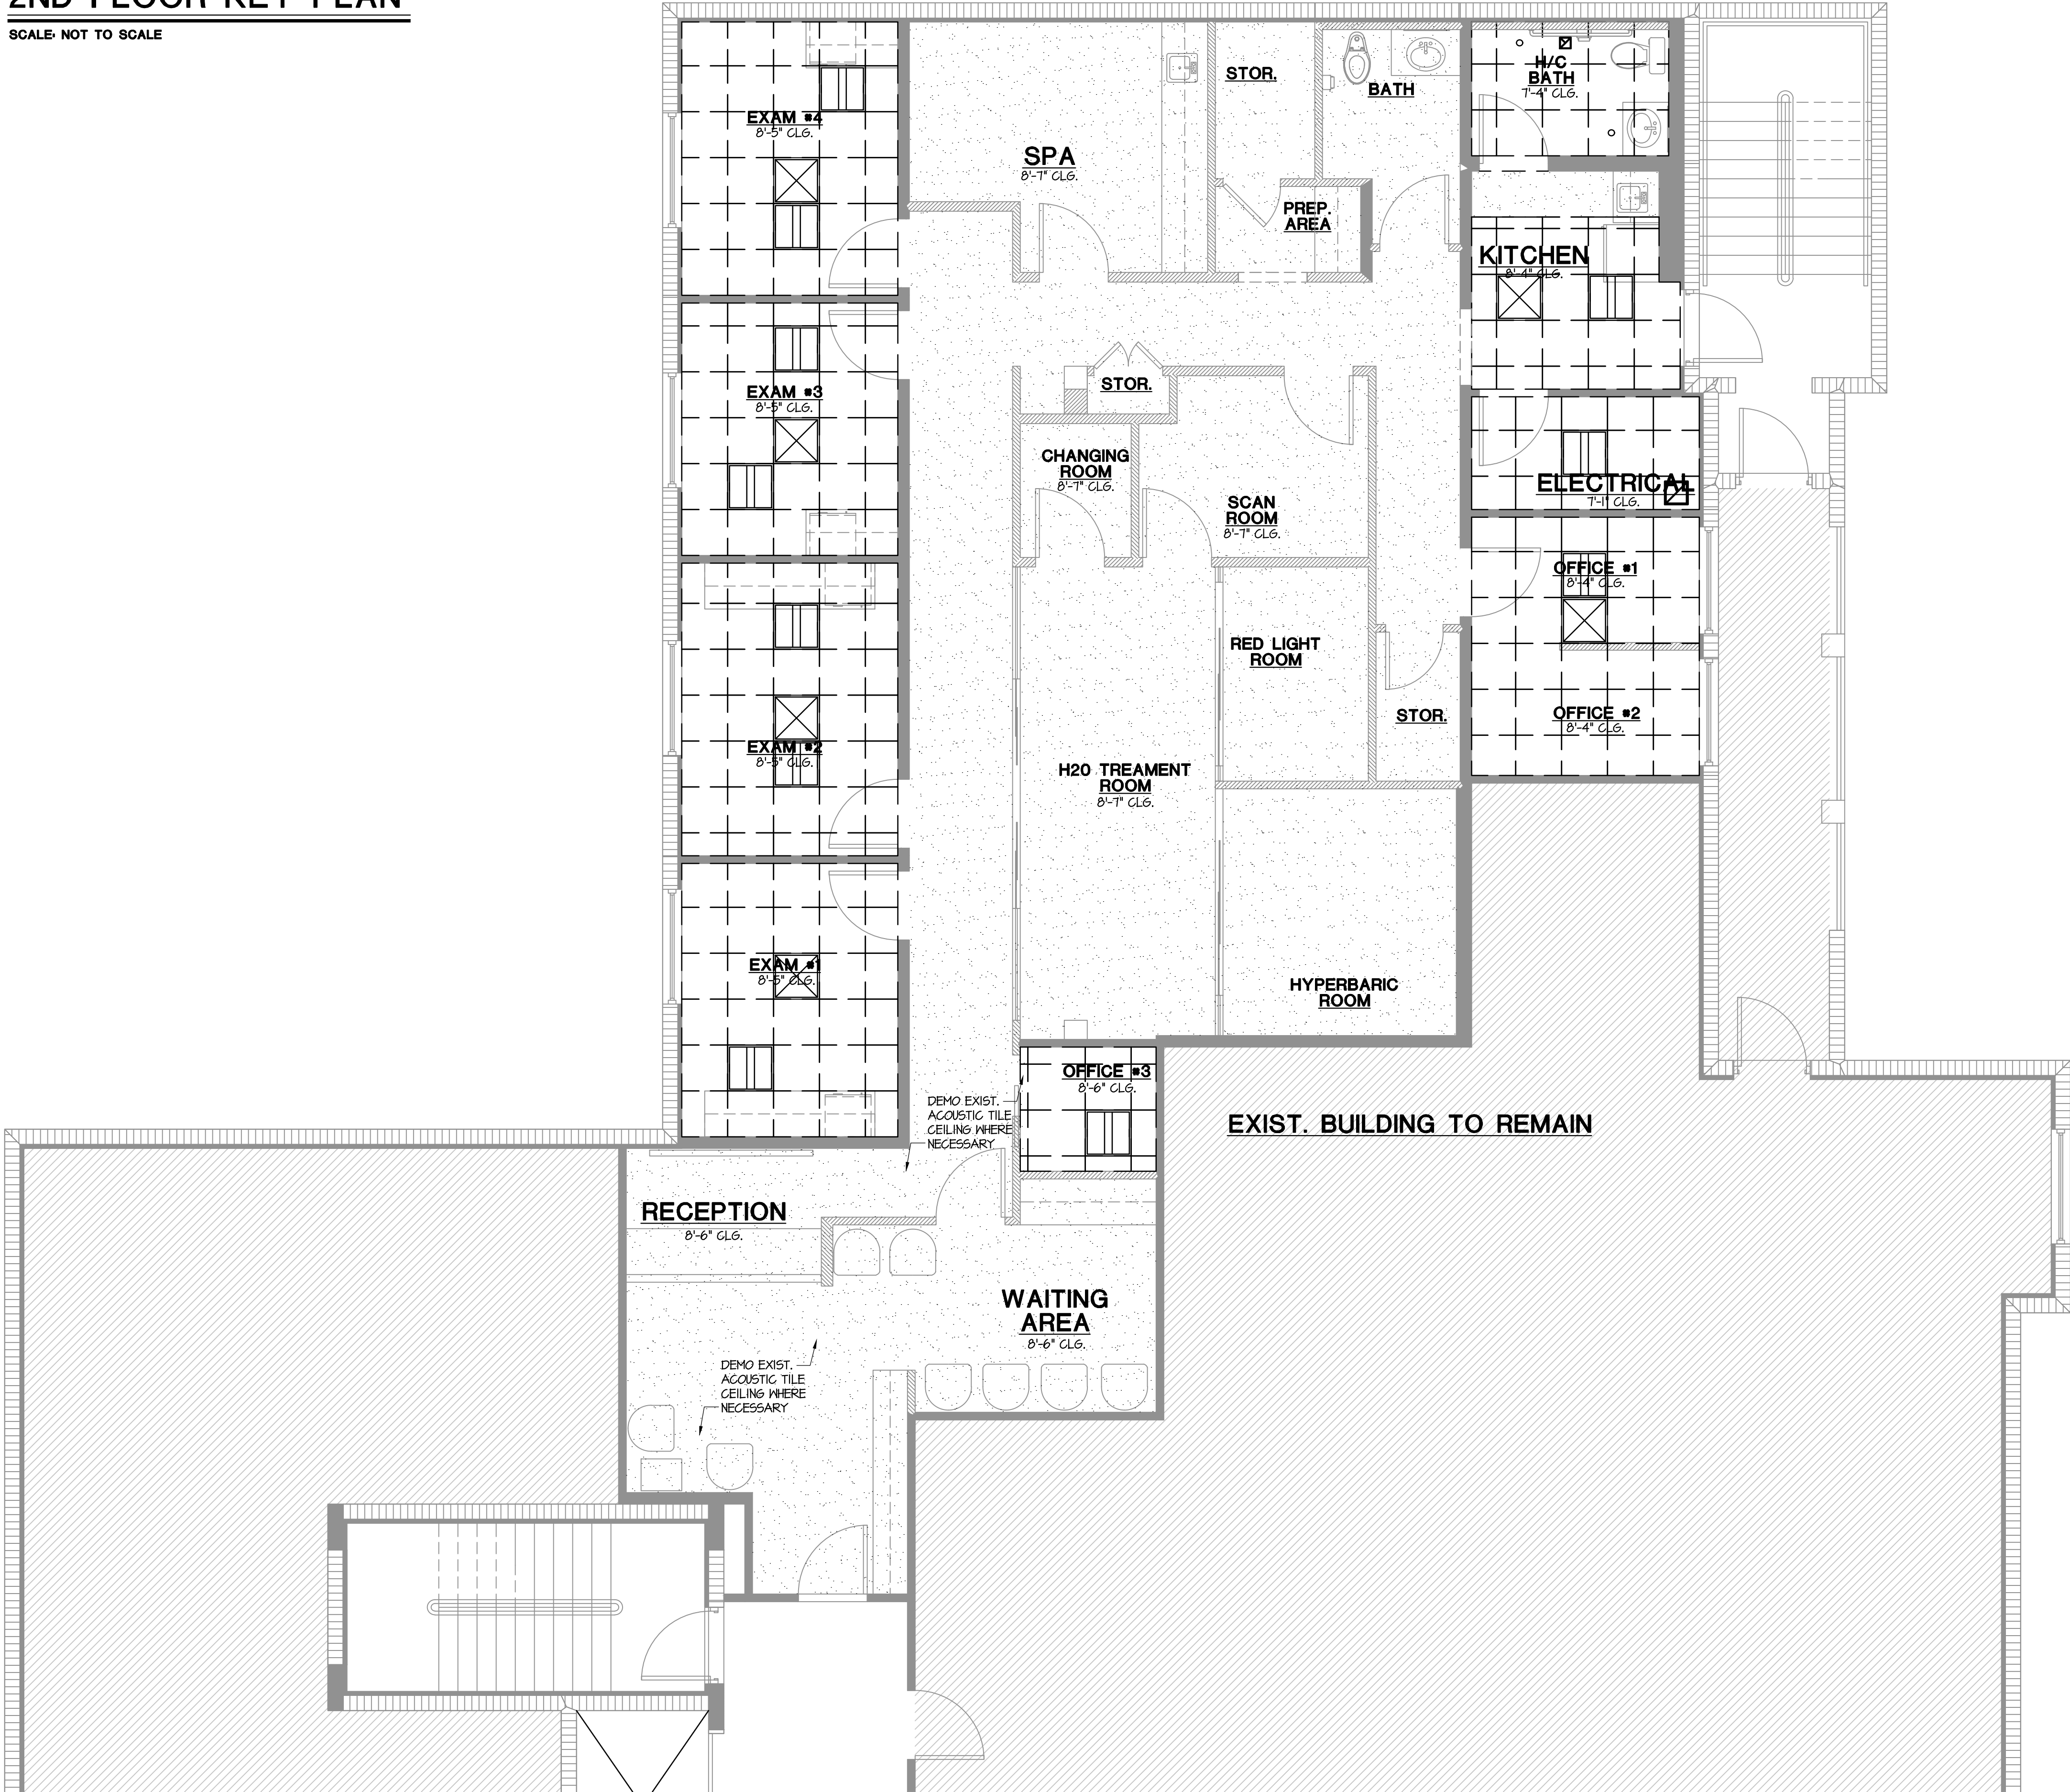

FIRE ALARM SYMBOLS

|                                                |  |
|------------------------------------------------|--|
| WALL MOUNTED EMERGENCY LIGHT W/ BATTERY BACKUP |  |
| FIRE ALARM                                     |  |
| SPEAKER/STROBE                                 |  |
| EMERGENCY EXIT SIGN & LIGHT                    |  |
| FIRE SPRINKLER                                 |  |

CEILING LEGEND

|  |                                    |
|--|------------------------------------|
|  | ACT-1                              |
|  | GNB-1 PAINTED GYPSUM CEILING BOARD |
|  | LED DOWN LIGHT                     |
|  | RETURN DIFFUSER                    |
|  | EXHAUST FAN                        |

MECH. LEGEND

|  |                                     |
|--|-------------------------------------|
|  | SUPPLY DIFFUSER                     |
|  | RETURN AIR DUCT                     |
|  | 2X2 LED CENTER BASKET TROFFER LIGHT |

REFLECTED CEILING PLAN

SCALE: 1/4" = 1'-0"



633 TAMAMI TRAIL N, SUITE 300  
NAPLES, FL 34102  
239 594 9778  
www.jmdg-architecture.com

THE DRAWING INFORMATION AND DESIGN CONCEPT ON THIS PRINTED COPY OR ELECTRONIC FILE MEDIUM IS THE EXCLUSIVE COPYRIGHT PROTECTED PROPERTY AND CREATION OF JMDG RESIDENTIAL AND SHALL NOT BE REPRODUCED IN WHOLE OR IN PART WITHOUT THE EXPRESSED WRITTEN CONSENT OF JMDG  
© 2026 JMDG RESIDENTIAL

PROJECT GLAMMERS

633 TAMAMI TRAIL N, SUITE #201  
NAPLES, FLORIDA

REVISIONS

| NO. | DATE | DESCRIPTION |
|-----|------|-------------|
|     |      |             |
|     |      |             |
|     |      |             |
|     |      |             |
|     |      |             |

DRAWING SET

CONSTRUCTION DOCUMENTS  
06/17/2026

PROJECT MANAGER: RTM  
DRAWN / CHECKED: GAB/ RTM

PROJECT NUMBER  
26-42

SHEET TITLE  
PROPOSED REFLECTED CEILING PLAN

SHEET NUMBER

A7.0