


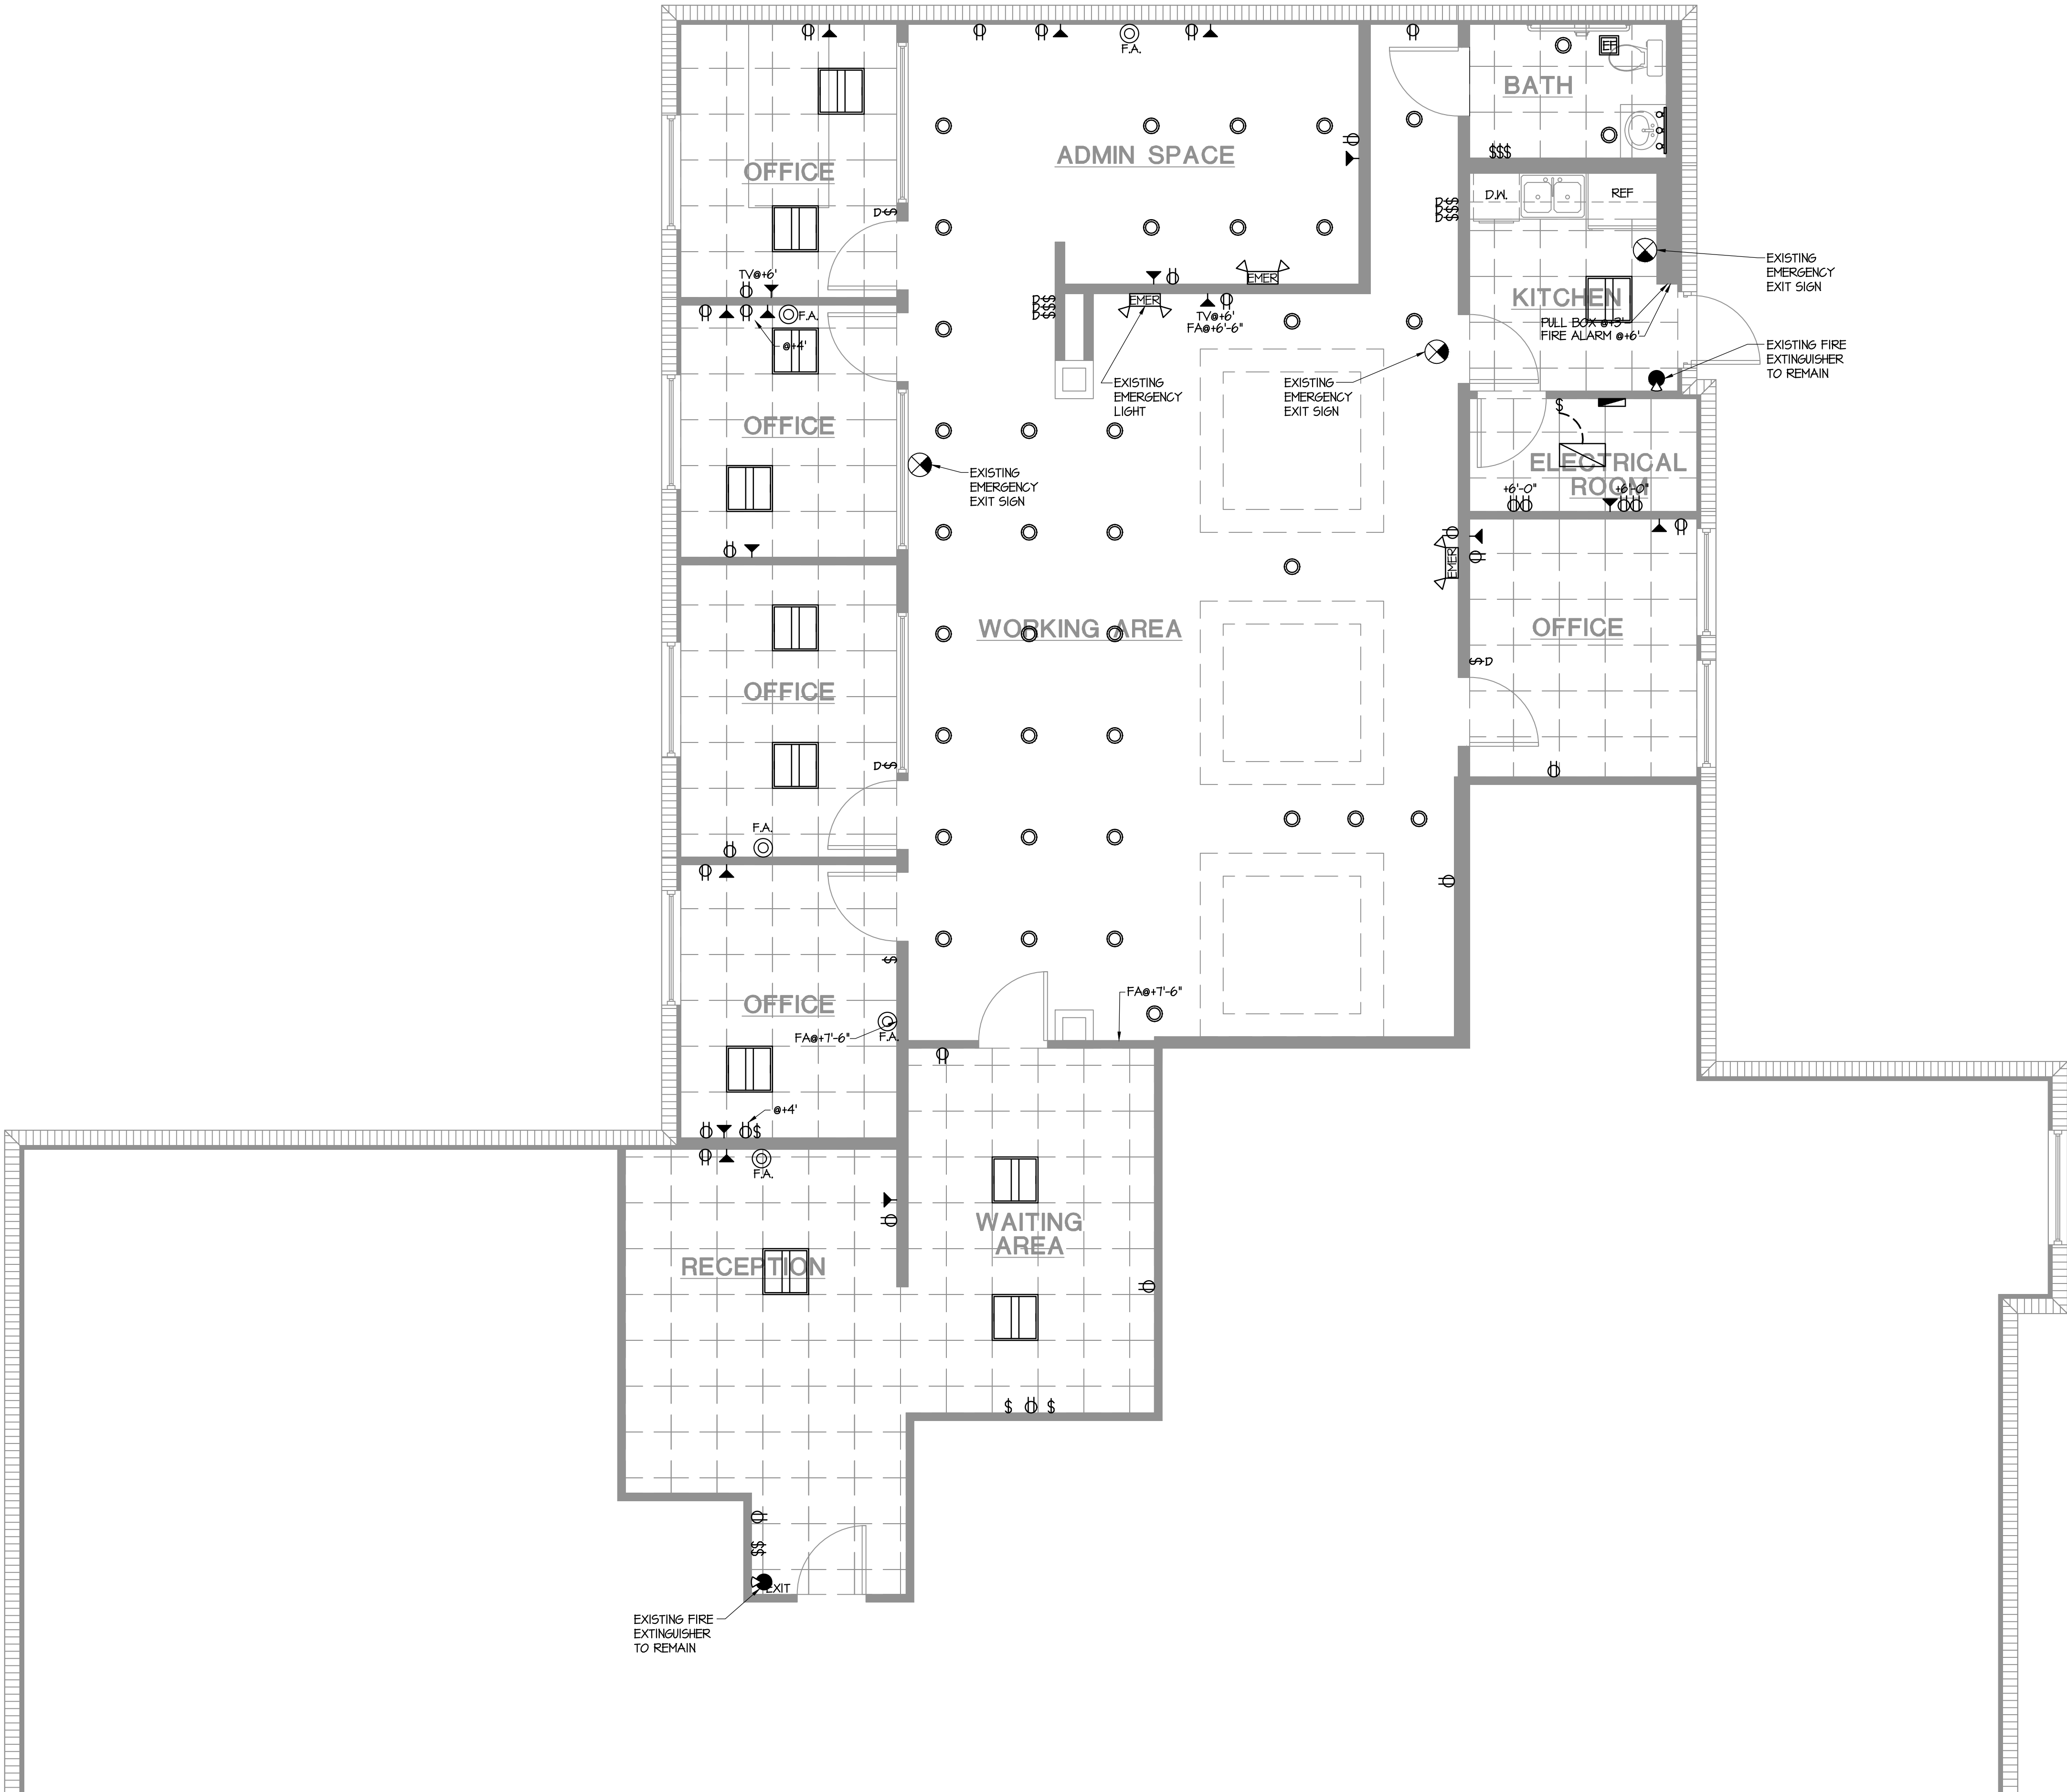

GENERAL ELEC. NOTES

- PER 2020 NATIONAL ELECTRIC CODE 210.12 ARC FAULT CIRCUITS SHALL BE LOCATED IN ALL LIVING AREAS.
- PRE-WIRE FOR SECURITY SYSTEM AND INTERCOM SYSTEM.
- INSTALL RG-6 COAXIAL CABLE AND CAT-6 TWISTED PAIR WIRE THROUGHOUT THE ENTIRE HOUSE. (SEE BUILDER FOR DETAILS)
- SEE SMOKE DETECTOR AND POOL ALARM NOTES.
- ELECTRIC SHALL BE IN ACCORDANCE TO MEET OR EXCEED -NEC 2020-
- CONTRACTOR TO SUPPLY SEVERAL OUTLETS IN SOFFIT OF ROOF OVERHANG AROUND THE HOUSE FOR HOLIDAY LIGHTING. COORDINATE WITH HOME OWNER.
- SMOKE DETECTORS SHALL BE INSTALLED PER NFPA 72 CHAPTER 24.5.1. SMOKE DETECTORS AND ALARMS POWERED BY HOUSE ELECTRIC W/ BATTERY BACK-UP AND INTERCONNECTED WILL BE INSTALLED PER R314.5 IN EACH SLEEPING ROOM AND IN HALL OR AREA IMMEDIATELY OUTSIDE EACH ROOM AND AT HIGHEST POINT OF EACH STORY OF RESIDENCE.
- ELECTRICAL CONTRACTOR AND OR SECURITY SYSTEM CONTRACTOR SHALL BE RESPONSIBLE TO ENSURE THAT ALL DOORS AND WINDOWS PROVIDING DIRECT ACCESS FROM THE HOME TO THE POOL WILL BE EQUIPPED WITH AN EXIT ALARM THAT HAS A MINIMUM SOUND PRESSURE RATING OF 85 DECIBELS AT 10 FEET, PER THE REQUIREMENTS DESCRIBED IN FLORIDA STATUTES SECTION 515.21-515.31, THE RESIDENTIAL SWIMMING POOL SAFETY ACT.
- DWELLINGS WITH FOSSIL-FUEL-BURNING APPLIANCES, FIREPLACE OR AN ATTACHED GARAGE SHALL HAVE APPROVED OPERATIONAL CARBON MONOXIDE ALARM INSTALLED WITHIN 10 FEET OF EACH ROOM USED FOR SLEEPING PURPOSES IN ACCORDANCE WITH NFPA 720 AND RE15.
- ALL LIGHTS TO BE LED IF APPLICABLE
- ALL ELECTRICAL SYSTEMS, EQUIPMENT, HEATING, VENTILATING, AIR CONDITIONING, PLUMBING FIXTURES AND OTHER SYSTEMS TO BE AT OR ABOVE DESIGNED FLOOR ELEVATION. NO EQUIPMENT OR SYSTEMS LISTED ABOVE ARE TO BE INSTALLED BELOW DESIGNED FLOOD ELEVATION.

ELECTRICAL LEGEND

	CEILING FAN
	UNDERCOUNTER LIGHT
	VANITY LIGHTING
	LED STRIP LIGHTING
	4\" RECESSED LIGHT
	EYE BALL RECESSED
	6\" RECESSED LIGHT
	6\" RECESSED LIGHT VAPOR RESISTANT
	HANGING LIGHT FIXTURE
	HANGING LIGHT VAPOR RESISTANT CEILING MOUNTED FIXTURE
	WALL MOUNTED SCONCE LIGHT
	EXTERIOR WALL MOUNTED LIGHT
	SPOT LIGHTS
	BROAN ULTRA SILENT EXHAUST FAN OR EQUAL
	TYP. SWITCH
	DIMMER SWITCH
	3-WAY SWITCH
	4-WAY SWITCH
	AIR SWITCH
	SINGLE 110 OUTLET
	UNDER COUNTER 110 OUTLET
	110 OUTLET
	HALF HOT DUPLEX 110 OUTLET
	220 OUTLET
	110 G.F.I.
	110 G.F.I. W.P. OUTLET
	A/C DISCONNECT
	PUSH BUTTON
	CABLE T.V.
	PHONE
	SMOKE DETECTOR
	CARBON MONOXIDE DETECTOR
	DOOR CHIME

EXISTING ELECTRICAL PLAN

SCALE: 1/4\"/>

JMDG
RESIDENTIAL

633 TAMiami TRAIL N, SUITE 300
NAPLES, FL 34102
239 594 9778
www.jmdg-architecture.com

THE DRAWING INFORMATION AND DESIGN CONCEPT ON THIS PRINTED COPY OR ELECTRONIC FILE MEDIUM IS THE EXCLUSIVE COPYRIGHT PROTECTED PROPERTY AND CREATION OF JMDG RESIDENTIAL AND SHALL NOT BE REPRODUCED IN WHOLE OR IN PART WITHOUT THE EXPRESSED WRITTEN CONSENT OF JMDG
© 2025 JMDG RESIDENTIAL

PROJECT GLAMMERS

633 TAMiami TRAIL N, SUITE #201
NAPLES, FLORIDA

REVISIONS

NO.	DATE	DESCRIPTION

DRAWING SET

CONSTRUCTION DOCUMENTS

06/17/2026

PROJECT MANAGER: RTM
DRAWN / CHECKED: GAB/ RTM

PROJECT NUMBER
26-42

SHEET TITLE
EXISTING ELECTRICAL PLAN

SHEET NUMBER
A8.0