
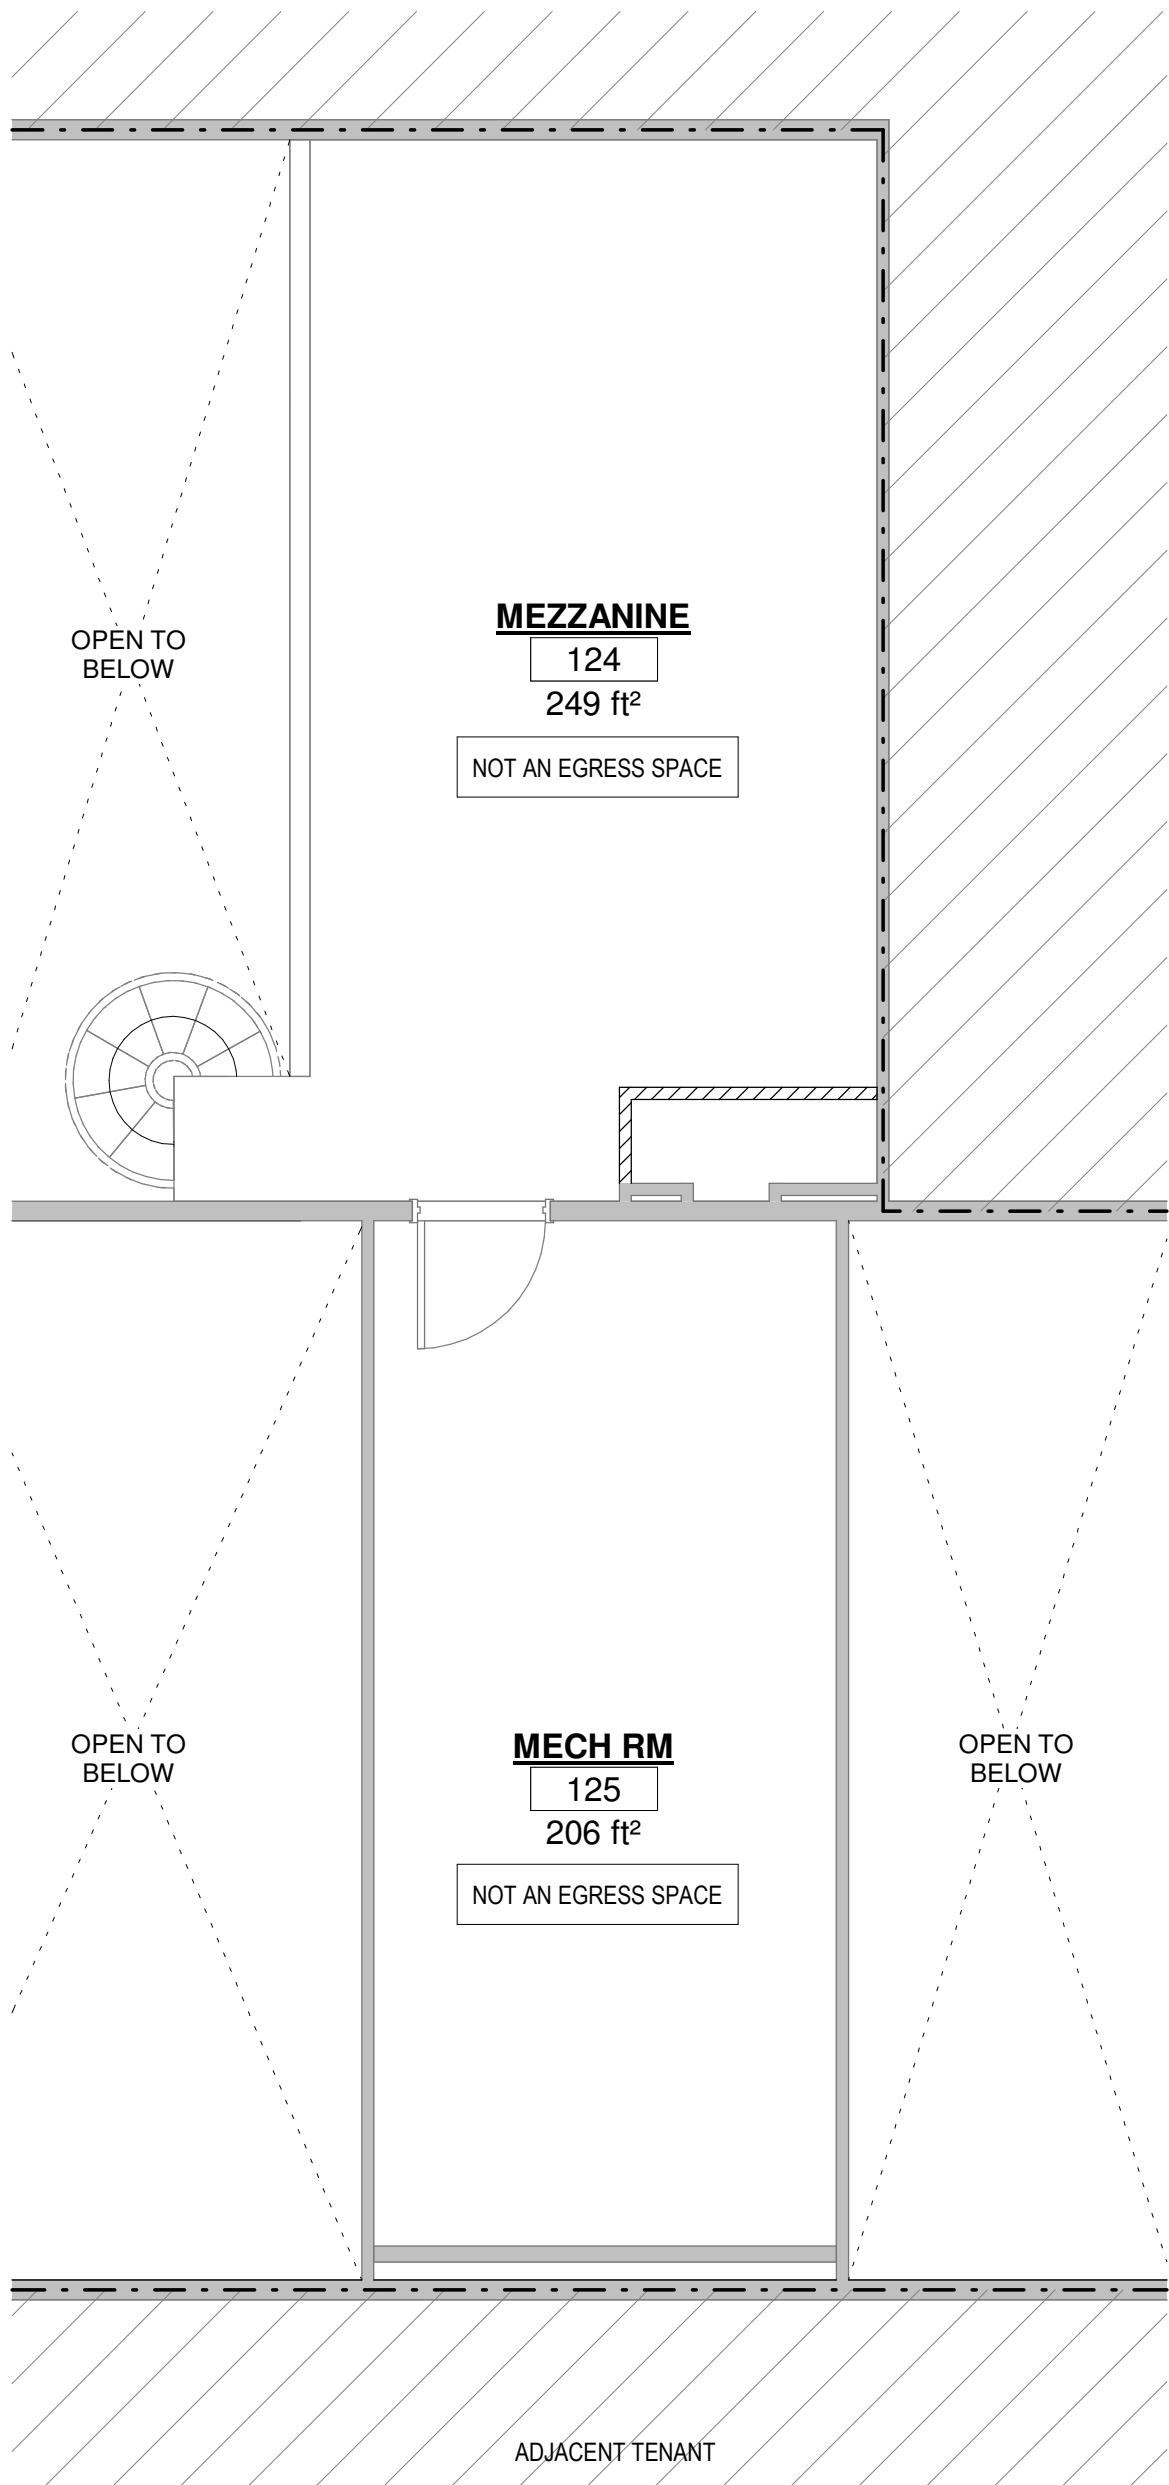


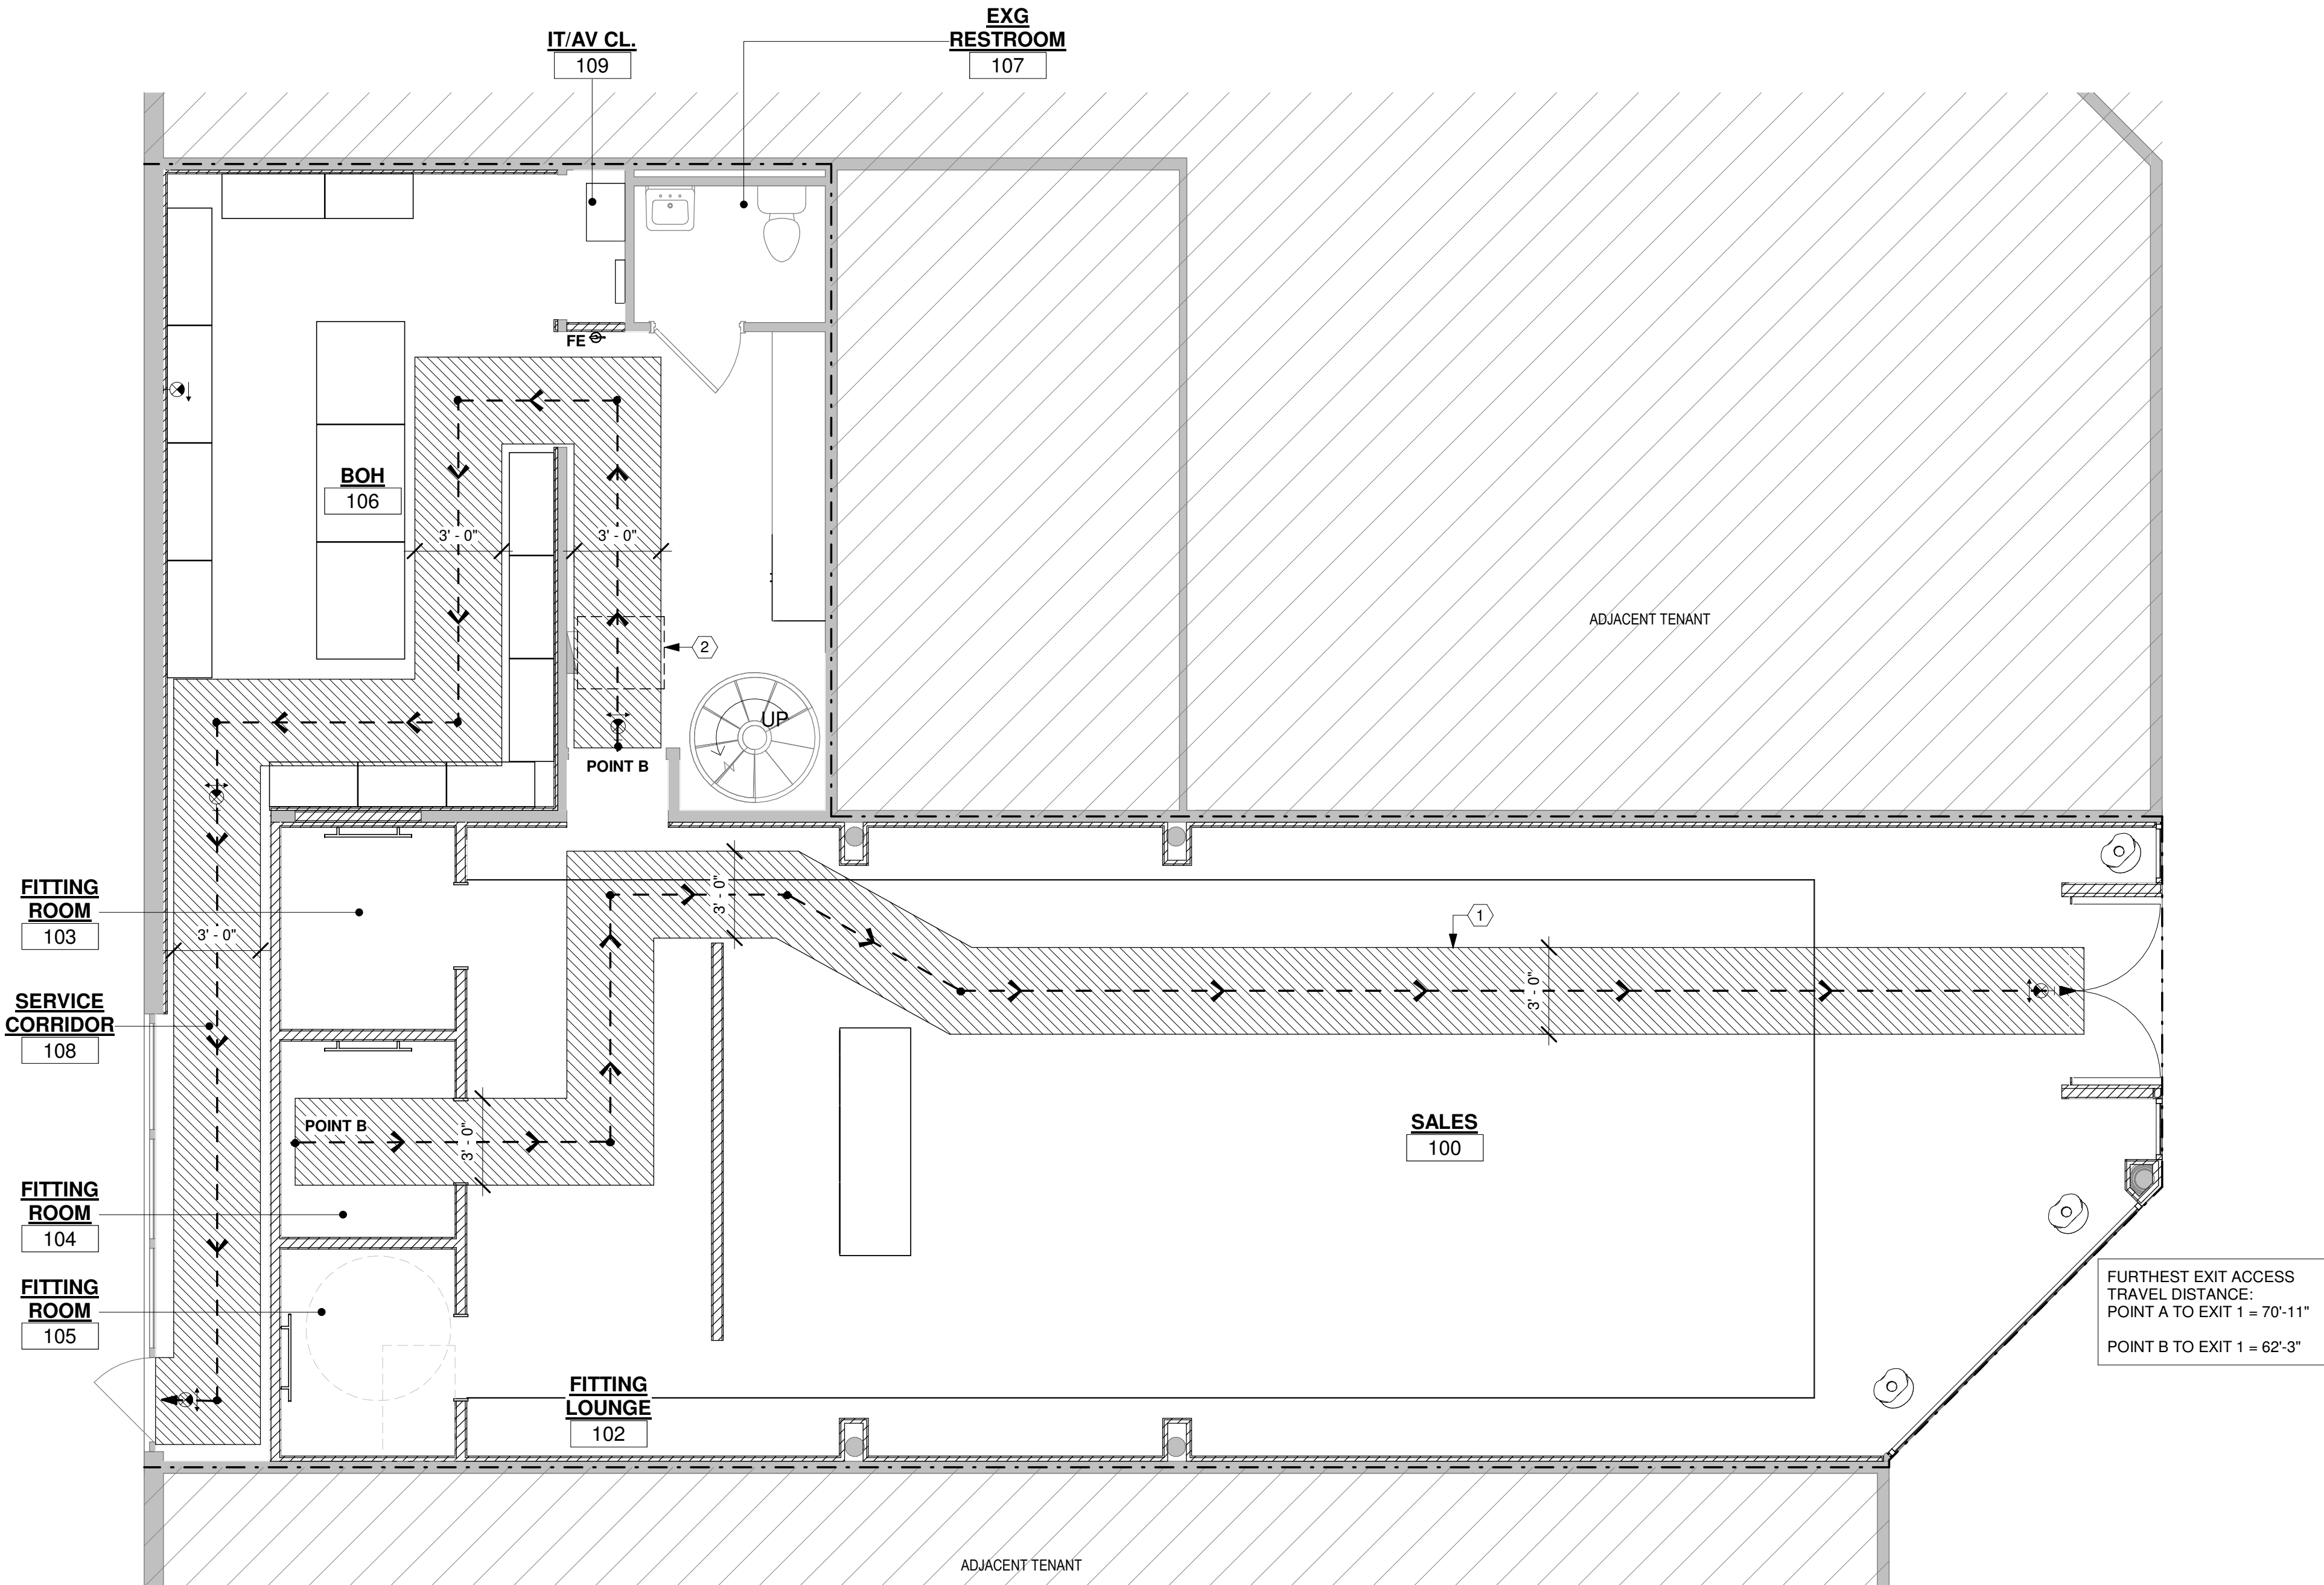

EGRESS PLAN EXIT ANALYSIS

CONSTRUCTION TYPE: II-B
BUILDING # OF STORIES: 1 STORIES
TENANT LEASED AREA: 1594 SF ON 1ST LEVEL, 467 SF ON MEZZANINE
OCCUPANCY GROUP: (M) MERCANTILE
SPRINKLER SYSTEM: FULLY SPRINKLERED

OF EXITS PER IBC 2024 TABLE 1006.2.1 OCCUPANCY 'M'
TOTAL SQUARE FOOTAGE IS 2061 SF
OCCUPANCY LOAD OF 49 OR LESS: **YES**
COMMON PATH OF EGRESS TRAVEL DISTANCE GREATER THAN 75FT: **NO**

CODE REQUIRED: 1 MAIN MEANS OF EGRESS
PROVIDED: 1

EXIT DOOR WAY CONFIGURATION:
COMPLIANT

PER IBC 2024 TABLE 1006.2.1 MAXIMUM COMMON PATH OF EGRESS TRAVEL
DISTANCE WITH SPRINKLER SYSTEM IN OCCUPANCY 'M' IS 75'-0\"/>

TRAVEL DISTANCE
POINT A TO EXIT 1 = 70'-11\"/>

EGRESS PLAN LEGEND

SYMBOL	DESCRIPTION
	LEASE LINE
	REMOTE POINT OF EXIT TRAVEL
	DIRECTION OF EGRESS
	EXISTING WALL
	NEW FULL HEIGHT (OR UP TO CEILING) PARTITION. REFER TO PARTITION TYPES FOR MORE INFORMATION
	EGRESS PATH. PROVIDE PAINTED FLOOR STRIPING IN WIDTH PER EGRESS REQUIREMENTS IN CAUTION YELLOW OR RED VINYL TILE THROUGH THE STOCKROOM FOR EXITING.
	ILLUMINATED EXIT SIGNAGE. REFER TO RCP FOR FULL SPEC AND LOCATIONS
	WALL MOUNTED TYPE 2-A 2BC FIRE EXTINGUISHER PER NFPA 10. FULLY RECESSED CABINET.

OCCUPANCY LOAD - TABLE 1004.5 IBC 2024

USE	AREA (GROSS)	LOAD FACTOR	TOTAL
BOH	634 ft²	300	3
SALES	1427 ft²	60	24
	2061 ft²		27

EGRESS PLAN KEY NOTES

- MAINTAIN 36" MIN. EGRESS PATH, FREE FROM OBSTRUCTIONS.
- CLEAR SPACE REQUIRED FOR ELECTRICAL PANEL.

2 MEZZANINE EGRESS PLAN
SCALE: 1/4" = 1'-0"

1 EGRESS PLAN
SCALE: 1/4" = 1'-0"

ISSUE FOR BID



45 WEST 21st STREET, SUITE 403
NEW YORK, NY 10010

IN ASSOCIATION WITH THE ARCHITECT:
R H SWEERS II, PROPRIETOR
R H SWEERS ARCHITECT

ALL DRAWINGS AND WRITTEN MATERIAL APPEARING HEREIN
CONSTITUTE ORIGINAL AND UNPUBLISHED WORK OF THE
ARCHITECT AND MAY NOT BE DUPLICATED, USED OR DISCLOSED
WITHOUT WRITTEN
CONSENT OF THE ARCHITECT. THIS DOCUMENT IS INTENDED
SOLELY FOR THE CONSTRUCTION OF THE PROJECT NAMED HEREIN
AND SHALL NOT BE USED BY ANY OTHER CONSTRUCTION WITHOUT
WRITTEN CONSENT OF THE ARCHITECT.

THIS DRAWING WAS PREPARED UNDER MY SUPERVISION AND I
DISCLAIM ANY RESPONSIBILITY FOR THE EXISTING BUILDING
CONSTRUCTION ELEMENTS, SITE CONDITIONS, OR ANY DOCUMENTS
WHICH DO NOT BEAR MY SEAL.

SEAL

DRAWINGS ISSUED

No.	Rev	Date	Description
1		06.18.26	LL REVIEW SET
2		06.24.26	ISSUE FOR PERMIT
3		07.02.26	ISSUE FOR BID
5	2	08.27.26	BID ADDENDUM #2

POINT A

PROJECT NAME:
TWP NAPLES

TWP

PROJECT ADDRESS:
WATERSIDE SHOPS
5455 TAMIAMI TRL N
NAPLES, FL 34108

DRAWING TITLE:
EGRESS PLAN

SCALE: AS SHOWN

Project No. 26TWP05

Scale: 1/4" = 1'-0"

Date: 08-20-2026

Drawn By: 212

Checked By: 212

DRAWING NO:



G-001

DEMOLITION NOTES	POWER & COMMUNICATION NOTES	REFLECTED CEILING NOTES	FINISH NOTES	ISSUE FOR BID
1. SEE ALL DRAWINGS FOR ADDITIONAL NOTES AND SPECIFICATIONS.	1. SEE ENGINEER'S DRAWING FOR ALL CIRCUITING AND RELATED WORK.	1. GC TO PROVIDE APPROPRIATE SIZED CUTOUT ABOVE CEILING WHERE PARTITION WALLS EXTEND TO SLAB ABOVE, AS REQUIRED FOR CIRCULATION OF RETURN AIR TO HVAC SYSTEM. FURNISH AND INSTALL FIRE DAMPERS AS REQUIRED TO MAINTAIN THE INTEGRITY OF RATED WALLS.	1. SAMPLES OF ALL FINISHES SPECIFIED SHALL BE SUBMITTED TO THE ARCHITECT FOR APPROVAL, IN TRIPPLICATE, PRIOR TO COMMENCEMENT OF THE WORK. CARPET, WALL COVERING, AND WOOD FINISH SAMPLES TO BE A MIN. 12" X 12". PAINT SAMPLES FOR GYPSUM BOARD. SURFACES TO BE PROVIDED ON 12"x12" PIECES OF GYPSUM BOARD.	
2. THE DEMOLITION CONTRACTOR IS RESPONSIBLE FOR FAMILIARIZING THEMSELVES WITH THE BUILDING RULES AND REGULATIONS BEFORE AND DURING THE COURSE OF THIS PROJECT. SHOULD A CONFLICT ARISE BETWEEN THE CONTRACT DOCUMENTS AND THE BUILDING RULES, THE CONTRACTOR IS TO NOTIFY THE ARCHITECT IMMEDIATELY. BUILDING RULES AND REGULATIONS SHALL GOVERN EXCEPT WHERE THEY ARE IN CONFLICT WITH APPLICABLE CODES AND ORDINANCES.	2. IF APPLICABLE, THE CONTRACTOR SHALL INSTALL LOCALLY APPROVED FIXTURES ONLY.	2. GENERAL CONTRACTOR SHALL REMOVE CEILING TILE(S) AS REQUIRED BY THE VOICE, DATA, AV, SECURITY AND SIGNAL CABLE VENDOR OR OTHER TRADES AUTHORIZED FOR INSTALLATION BY THE ARCHITECT. ALL CEILING TILES MUST BE REPLACED WHEN WORK IS COMPLETED.	2. ALL WALLS (NEW AND EXISTING) SHALL BE PROPERLY PREPARED (SPACKLED, SANDED, ETC.) FOR PAINTING AND/OR WALL COVERING AS PER FINISH PLAN AND MANUFACTURER'S SPECIFICATIONS.	
3. GENERAL CONTRACTOR TO COORDINATE ALL PHASES OF DEMOLITION FOR PROJECT AND NOTIFY THE ARCHITECT OF ANY DISCREPANCIES OR CONFLICTING CONDITIONS WHICH WOULD INTERFERE WITH THE SATISFACTORY COMPLETION OF THE WORK, PRIOR TO THE START OF DEMOLITION.	3. GENERAL CONTRACTOR SHALL VERIFY THE AVAILABLE ELECTRIC SERVICE IN THE TENANT'S SPACE AND ADVISE THE ARCHITECT OF THEIR FINDINGS PRIOR TO SUBMITTING A BID.	3. ALL THERMOSTATS, NEW AND EXISTING, TO BE INSTALLED AT 54" A.F.F. IN LOCATIONS APPROVED BY THE ARCHITECT, UNLESS OTHERWISE NOTED.	3. ALL PAINTS SHALL BE APPLIED IN ACCORDANCE WITH MANUFACTURER'S SPECIFICATIONS FOR THE PARTICULAR SURFACE.	
4. GENERAL CONTRACTOR TO PROVIDE TEMPORARY POWER AND LIGHTING THROUGHOUT COURSE OF JOB WHERE REQUIRED.	4. ELECTRICAL CONTRACTOR SHALL DISCONNECT, CONNECT, AND PROVIDE NECESSARY ELECTRIC RUNS IN ORDER TO CONFORM WITH NEW PLAN.	4. SEE ENGINEER'S DRAWINGS FOR THE LOCATION OF ALL SPRINKLER HEADS AND RELATED WORK. ARCHITECTURAL DRAWINGS INDICATE SPRINKLER HEADS FOR LOCATION ONLY, WHERE DISCREPANCIES OCCUR BETWEEN ARCHITECTURAL AND ENGINEERING DRAWINGS REGARDING LOCATIONS, ARCHITECTURAL DRAWINGS SHALL GOVERN.	4. ALL SURFACES WHICH ARE TO BE PAINTED SHALL RECEIVE (1) COAT OF PRIMER AND (2) COATS OF FINISH PAINT. (3) COATS TOTAL. NOTE THAT BOTH CONTRACTOR AND ITS PAINTING SUBCONTRACTOR TO INCLUDE IN SCOPE OF WORK PAINT TOUCH UP DUE TO ANY DAMAGE DONE DURING CONSTRUCTION AS CAUSED BY NO FAULT OF THE PAINTING SUBCONTRACTOR BUT WHICH MIGHT OF BEEN CAUSED BY OTHER TRADES, INCLUDING BUT NOT LIMITED TO CONSTRUCTION TRADES, VOICE/DATA AND SECURITY CONTRACTOR AND INCLUDING FURNITURE INSTALLERS AND MOVERS. CONTRACTOR AND PAINTING SUBCONTRACTOR TO INCLUDE PAINT TOUCHUP WITHIN THEIR SCOPE OF WORK WITHOUT EXCEPTION OR EXCLUSION FROM BIDS.	
5. FIRE AND SMOKE DETECTION SYSTEM (EXISTING) TO REMAIN IN OPERATION DURING DEMOLITION AND CONSTRUCTION INCLUDING ALL STROBES.	5. SWITCHES, DUPLEX OUTLETS, COVER PLATES AND FLOOR MOUNTED OUTLETS SHALL BE INSTALLED BY COMPETENT MECHANICS IN A FIRST CLASS MANNER.	5. ALL SPRINKLER HEADS AT DROPPED CEILINGS TO BE CONCEALED FLUSH TYPE WITH PREFINISHED WHITE CAP TO MATCH CEILING. WHERE INDICATED IN ACOUSTICAL TILE CEILINGS, SPRINKLER HEADS SHALL BE CENTERED IN TILES, UNLESS OTHERWISE NOTED.	5. ALL WALLS, GYPSUM BOARD CEILINGS AND SOFFITS TO BE PAINTED SHALL BE PAINTED WITH A LATEX BASE EGGSHELL FINISH PAINT UNLESS OTHERWISE NOTED. ALL DOORS, DOOR FRAMES, WINDOW FRAMES, AND CONVECTOR ENCLOSURES SHALL BE PAINTED WITH AN ALKYD BASE SEMIGLOSS FINISH PAINT UNLESS OTHERWISE NOTED.	
6. DO NOT REMOVE ANY BUILDING CLASS "I" FIRE PROTECTION SIGNALS OR EQUIPMENT, UNLESS OTHERWISE NOTED. PROTECT AS REQUIRED FOR DURATION OF THE JOB.	6. EXCEPT AS NOTED, ALL ELECTRICAL AND VOICE/DATA WALL OUTLETS ARE TO BE MOUNTED AT 15" A.F.F. REFER TO ELECTRICAL PLAN FOR ADDITIONAL INFORMATION.	6. INSTALL DIRECTIONAL ACOUSTICAL TILE WITH THE GRAIN IN ONE DIRECTION ONLY IN ANY SINGLE SPACE.	6. ALL CONVECTOR ENCLOSURES TO BE PAINTED SHALL HAVE THE GRILLES AND ACCESS PANELS REMOVED AND PAINTED SEPARATELY AND REINSTALLED WHEN THOROUGHLY DRY.	
7. SEE ENGINEERING DRAWINGS FOR THE REMOVAL OF EXISTING A/C UNITS, IN ADDITION CONSULT WITH BOTH THE BUILDING MANAGEMENT/LANDLORD AND THE ARCHITECT PRIOR TO ITS REMOVAL.	7. IF OUTLET DIMENSION CALLS FOR MORE THAN 24" A.F.F., OUTLETS (WITH EXCEPTION OF WALL TELEPHONE OUTLETS) SHALL BE MOUNTED HORIZONTALLY.	7. ALL EXHAUST FAN EQUIPMENT TO BE LOCATED OUTSIDE THE SPECIFIED ROOM AND DUCTED INTO THE SPACE TO THE CEILING REGISTER. ALL EXHAUST FANS TO BE CONTROLLED BY A (RED) PILOT LIGHT WALL MOUNTED SWITCH.	7. ALL DOORS AND FRAMES TO BE PAINTED THE SAME COLOR AND TYPE OF PAINT ON BOTH SIDES, UNLESS OTHERWISE NOTED.	
8. SEE ENGINEERING DRAWINGS AND NOTES FOR ADDITIONAL DEMOLITION REQUIREMENTS WHEN REFERRING TO HVAC, SPRINKLER, PLUMBING, ELECTRICAL, FIRE ALARM AND COMMUNICATION.	8. CENTERLINE-TO-CENTERLINE DIMENSIONS OF ANY OUTLET PAIR SHALL NOT EXCEED 6".	8. GC IS RESPONSIBLE TO BALANCE THE HVAC SYSTEM AFTER THE INSTALLATION IS COMPLETED AND SUBMIT A WRITTEN REPORT TO THE ARCHITECT'S AND ENGINEER'S OFFICE FOR REVIEW AND APPROVAL.	8. ALL WALLS, CEILINGS, SOFFITS AND SURFACES WHICH HAVE BEEN PAINTED WITH AN EGGSHELL FINISH AND MUST BE TOUCHED UP AS A PUNCH LIST ITEM SHALL BE REPAINTED ENTIRELY BETWEEN THE (2) CLOSEST BREAK POINTS.	
9. ANY AND ALL ELECTRICAL/DATA AND TELEPHONE DEVICES, WIRING, CABLES , CONDUITS, ETC. TO BE REMOVE SHALL BE REVIEWED BY BUILDING MANAGEMENT, CLIENT CONSULTING ENGINEER AND ANY OTHER CONSULTANT DEEMED NECESSARY PRIOR TO ANY WORK.	9. ALL BACK-TO-BACK OUTLETS IN ADJOINING ROOMS TO BE STAGGERED.	9. IF CEILING GRID REQUIRES CUT TILES, ANY CUT TILES THAT ARE VISUAL SHALL HAVE A FINISHED EDGE. CONTRACTOR MAY INCLUDE EITHER PREFABRICATED TILES TO THAT DIMENSION AND/OR FINISH THE CUT EDGE OF TILE, TO MATCH CEILING TILE.	9. ALL EXISTING GYPSUM BOARD CEILINGS, SOFFITS AND DRYWALL PARTITIONS THAT ARE PATCHED SHALL BE PAINTED IN THEIR ENTIRETY.	
10. ANY REMOVAL OF SUCH ELECTRICAL EQUIPMENT SHALL BE DONE IN SUCH A WAY AS TO ALLOW THE OPERATIONS OF ADJACENT FLOORS TO CONTINUE WITHOUT INTERRUPTION OF ANY SERVICE DURING DEMOLITION AND CONSTRUCTION. THE CONTRACTOR SHALL TAKE ALL PRECAUTIONS NEEDED IN ORDER TO COMPLY WITH THIS REQUIREMENT.	10. N/A	10. CONTRACTOR TO PROVIDE ATTIC STOCK OF ALL CEILING TILES AT END OF PROJECT FOR CLIENTS FUTURE USE.	10. GENERAL CONTRACTOR SHALL FLASH PATCH AND PREPARE ALL FLOORS AS REQUIRED TO RECEIVE SPECIFIED FLOORING MATERIAL.	
11. DEMOLITION CONTRACTOR TO CONSULT WITH BUILDING MANAGEMENT WHEN REMAINING CONDUITS AND CABLES THAT MAYBE ACTIVE. IF SERVICE IS DISRUPTED CONTRACTOR TO INCLUDE ALL REPAIRS AS REQUIRED TO ANY CABLES AND CONDUITS.	11. ALL NEW VOICE/DATA AND ELECTRICAL OUTLETS TO BE INSTALLED ON AN EXISTING WALL SHOULD BE FLUSH MOUNTED WITH THE FINISHED WALL SURFACE. CHOP OUT THE WALL AS REQUIRED TO RECESS THE JUNCTION BOX AND CONDUIT, AND PATCH THE WALL AS REQUIRED.	11. WE ALL REALIZE THAT AS CONSTRUCTION PROCEEDS AND AS PROJECT NEARS COMPLETION, CEILING TILES OFTEN GET DAMAGED AND/OR DIRTY BY OTHER TRADES, THE GC AND THEIR SUBCONTRACTORS ARE RESPONSIBLE TO REPLACE ANY AND ALL DAMAGED CEILING TILES AND GRIDS AND/OR DRYWALL CEILINGS AND SOFFITS AT THEIR OWN COST.	11. CARPET CONTRACTOR SHALL INSPECT THE SUBFLOOR PRIOR TO COMMENCEMENT OF WORK. THEY SHALL NOTIFY THE ARCHITECT AND/OR THE TENANT'S REPRESENTATIVE IN WRITING OF ANY CONDITIONS WHICH WILL PREVENT THEM FROM PRODUCING SATISFACTORY FINISH WORK.	
12. PRIOR TO DEMOLITION, GC TO REVIEW WITH VOICE/DATA CONSULTANT FOR THE REMOVAL OF ANY AND ALL VOICE/DATA CONDUIT, CABLES AND EQUIPMENT.	12. ALL EXISTING ELECTRICAL OUTLETS TO BE CAPPED SHALL HAVE THE ELECTRICAL DEVICE AND ALL THE WIRING REMOVED. PATCH HOLE AS REQUIRED.	12. AT END OF THE PROJECT, CONTRACTOR TO REALIGN ALL CEILING TILE AND GRIDS A SQUARE AND LEVEL INSTALLATION.	12. FLOORS MUST BE FREE OF DUST, OIL AND ALL FOREIGN MATTER. BUILDING MUST BE PREHEATED TO A MINIMUM OF 65°, 24 HOURS PRIOR TO INSTALLATION OF FLOOR COVERING. CRACKS 1/16" OR MORE, HOLES, AND OTHER UNEVENNESS MUST BE FILLED WITH A LATEX BASE FLOOR FILLER. HIGH SPOTS MUST BE LEVELED. FLOOR MUST BE SWEPT CLEAN, WET MOPPED WITH WARM WATER AND SWEPT AGAIN. IF SWEEPING LEAVES A RESIDUE, FLOORS SHALL BE VACUUMED.	
13. GENERAL CONTRACTOR IS RESPONSIBLE FOR DEMOLITION AND REMOVAL OF ALL DEBRIS AND DISCARDED MATERIALS AND/OR EQUIPMENT AS INDICATED WITHIN THE SPACE.	13. GENERAL CONTRACTOR SHALL REMOVE ALL UNUSED CONDUIT, CABLES AND VOICE/DATA WIRING COMPLETELY FROM AREAS IN SCOPE OF THIS CONTRACT.	13. CARPET CONTRACTOR SHALL ASSUME FULL RESPONSIBILITY FOR ANY UNACCEPTABLE FINISH WORK CAUSED BY SUBFLOOR CONDITIONS.	13. CARPET CONTRACTOR SHALL ASSUME FULL RESPONSIBILITY FOR ANY UNACCEPTABLE FINISH WORK CAUSED BY SUBFLOOR CONDITIONS.	
14. GENERAL CONTRACTOR TO COORDINATE WITH THE BUILDING MANAGEMENT AND CLIENT AS TO THE PROTECTION AND/OR STORAGE OF ANY ITEMS TO BE SAVED FROM DEMOLITION.	14. GENERAL CONTRACTOR SHALL BE RESPONSIBLE FOR ALL WORK NECESSARY TO COMPLETE CORE DRILLING AND ELECTRICAL HOOKUP, PATCHING, ETC., INCLUDING WORK IN LANDLORD'S OR OTHER TENANT'S SPACE. ALL CORE DRILLING SHALL BE ACCOMPLISHED DURING STATED BUILDING APPROVED WORKING HOURS. CONTRACTOR SHALL VERIFY AND CONFORM TO THOSE HOURS WHEN WORK IS REQUIRED.	14. MILLWORK SUBCONTRACTOR SHOULD INSPECT THE ALIGNMENT OF ALL GYPSUM BOARD CONSTRUCTION AND SHOULD NOTIFY THE ARCHITECT OF ANY CONDITION THAT WOULD PREVENT THEM FROM COMPLETING THEIR WORK.	14. GENERAL CONTRACTOR SHALL INSTALL NEW 4" FLAT VINYL WALL BASE ON ALL WALLS IN CARPETED AREAS, AND 4" VINYL COVE BASE IN ALL VINYL FLOOR TILE AREAS TYPICAL THROUGHOUT EXCEPT WHEN MARBLE OR CERAMIC TILE FLOORING IS SPECIFIED OR WHERE OTHERWISE NOTED. GC SHALL THOROUGHLY CLEAN ALL VINYL BASE AFTER INSTALLATION IS COMPLETED.	
15. GENERAL CONTRACTOR IS RESPONSIBLE TO PROTECT ALL EXISTING ITEMS TO REMAIN (I.E. PLUMBING FIXTURES, WINDOWS, CONVECTOR COVERS, ETC.) THROUGHOUT THE COURSE OF THE JOB.	15. SHOULD JOB CONDITIONS REQUIRE RELOCATION OF PLANNED VOICE/DATA OR ELECTRICAL OUTLETS FOR ANY REASON, THE CONTRACTOR SHALL NOTIFY THE ARCHITECT'S FIELD REPRESENTATIVE FOR APPROVAL OF ALTERNATE LOCATION PRIOR TO THE START OF ANY WORK.	15. ALL VINYL OR RUBBER BASE TO BE CONTINUOUS ROLL TYPE WITH SEAMING TO OCCUR ONLY ON INSIDE CORNERS OR AT LEAST 12" FROM WRAPPED OUTSIDE CORNER.	15. ALL VINYL OR RUBBER BASE TO BE CONTINUOUS ROLL TYPE WITH SEAMING TO OCCUR ONLY ON INSIDE CORNERS OR AT LEAST 12" FROM WRAPPED OUTSIDE CORNER.	
16. GENERAL CONTRACTOR MUST PROVIDE ALL REQUIRED PROTECTION TO ALL SURROUNDING AREAS THROUGHOUT COURSE OF THE DEMOLITION AND CONSTRUCTION.	16. N/A	16. CARPET CONTRACTOR TO PROVIDE AND INSTALL ALL NECESSARY VINYL REDUCING STRIPS AND/OR METAL SADDLES AS REQUIRED AT ALL CARPET/MATERIAL TRANSITION POINTS. COLOR SPECIFICATION BY ARCHITECT.	16. CARPET CONTRACTOR TO PROVIDE AND INSTALL ALL NECESSARY VINYL REDUCING STRIPS AND/OR METAL SADDLES AS REQUIRED AT ALL CARPET/MATERIAL TRANSITION POINTS. COLOR SPECIFICATION BY ARCHITECT.	
17. GENERAL CONTRACTOR IS RESPONSIBLE TO REPAIR AND/OR REPLACE ANY DAMAGE IN THE SURROUNDING AREAS CAUSED BY DEMOLITION AND CONSTRUCTION IN "AREA OF WORK" .	17. ANY EXISTING FIRE ALARM SOUNDERS, PULL BOXES AND/OR THERMOSTATS WHICH INTERFERE WITH NEW PARTITION WORK SHALL BE RELOCATED TO AN APPROVED LOCATION.	17. GENERAL CONTRACTOR TO PROVIDE AND INSTALL ALL METAL ANGLES AND/OR MARBLE REDUCING SADDLES PER DETAILS, IN ADDITION TO ANY FLOOR LEVELING AS MAY BE REQUIRED FOR SMOOTH TRANSITION AT ALL STONE OR TILE FLOORING/MATERIAL TRANSITION POINTS.	17. GENERAL CONTRACTOR TO PROVIDE AND INSTALL ALL METAL ANGLES AND/OR MARBLE REDUCING SADDLES PER DETAILS, IN ADDITION TO ANY FLOOR LEVELING AS MAY BE REQUIRED FOR SMOOTH TRANSITION AT ALL STONE OR TILE FLOORING/MATERIAL TRANSITION POINTS.	
18. ALL EXISTING WALLS, COLUMNS, & PERIMETER PIERS TO REMAIN IN "AREA OF WORK" ARE TO BE PATCHED AND REPAIRED TO RECEIVE NEW FINISHES.	18. GENERAL CONTRACTOR IS RESPONSIBLE FOR THE INSTALLATION AND HOOKUP OF ALL ELECTRIFIED RACEWAYS THROUGH THE SYSTEMS FURNITURE AS SPECIFIED. IT WILL BE THE GENERAL CONTRACTOR'S RESPONSIBILITY TO FAMILIARIZE THEMSELVES WITH THE SYSTEMS FURNITURE SPECIFIED AND ALL ELECTRICAL WORK RELATED TO THAT SYSTEM.	18. WHERE STONE, MARBLE, LIMESTONE AND HARD SURFACES FLOORING IS SPECIFIED, GC SHALL BE RESPONSIBLE FOR PROVIDING/APPLYING SEALANT AS SPECIFIED OR AS RECOMMENDED BY SUPPLIER, FOR A CLEAN, LASTING SURFACE.	18. WHERE STONE, MARBLE, LIMESTONE AND HARD SURFACES FLOORING IS SPECIFIED, GC SHALL BE RESPONSIBLE FOR PROVIDING/APPLYING SEALANT AS SPECIFIED OR AS RECOMMENDED BY SUPPLIER, FOR A CLEAN, LASTING SURFACE.	
19. GENERAL CONTRACTOR TO PATCH ALL SCAR JOINTS AS REQUIRED ON EXISTING CONSTRUCTION TO REMAIN.	19. DO NOT INSTALL VOICE/DATA AND ELECTRICAL FLOOR OUTLETS UNTIL CARPET IS INSTALLED.	19. FLOOR COVERING IN CLOSETS SHALL BE THE SAME AS THAT OF THE SPACE ONTO WHICH THE CLOSET OPENS UNLESS OTHERWISE NOTED.	19. FLOOR COVERING IN CLOSETS SHALL BE THE SAME AS THAT OF THE SPACE ONTO WHICH THE CLOSET OPENS UNLESS OTHERWISE NOTED.	
20. GENERAL CONTRACTOR IS TO COORDINATE WITH BUILDING MANAGEMENT THE USE OF ELEVATORS AND SERVICES, AND TO CONFORM TO ALL BUILDING REGULATIONS WITH REGARD TO DEMOLITION.	20. NO FLOOR OR WALL POWER OUTLETS SHALL BE CONNECTED TO LIGHTING CIRCUITS.	20. WHEN A GLUE DOWN INSTALLATION IS SPECIFIED, CARPETS SHALL BE LAID WITH TIGHT BUTT SEAMS LAID TRUE WITH AN APPROVED BRAND OF WATERPROOF QUICK RELEASE CEMENT IN ACCORDANCE WITH MANUFACTURER'S RECOMMENDATIONS.	20. WHEN A GLUE DOWN INSTALLATION IS SPECIFIED, CARPETS SHALL BE LAID WITH TIGHT BUTT SEAMS LAID TRUE WITH AN APPROVED BRAND OF WATERPROOF QUICK RELEASE CEMENT IN ACCORDANCE WITH MANUFACTURER'S RECOMMENDATIONS.	
21. IMMEDIATELY CLEAN AND REMOVE ALL DEBRIS FROM PUBLIC CORRIDORS AND LOBBIES AFTER DEMOLITION AND BEFORE COMMENCEMENT OF THE NORMAL WORK DAY.	21. PROVIDE TAMPERPROOF CIRCUIT BREAKER CLAMPS ON ALL DEDICATED CIRCUIT BREAKERS.	21. CROSS JOINTS NECESSARY DUE TO LENGTH OF ROLLS RECEIVED, SHALL BE PLACED TO AVOID OCCURRENCE AT CONSPICUOUS LOCATIONS NEAR DOOR OR AT DOORWAYS AND ENTRIES PERPENDICULAR TO DOORS OR ENTRIES. SEAMS OCCURRING PARALLEL TO DOORS SHALL BE CENTERED DIRECTLY UNDER THE DOOR. CONTRACTOR TO SUBMIT SEAMING DIAGRAM FOR ARCHITECT'S REVIEW.	21. CROSS JOINTS NECESSARY DUE TO LENGTH OF ROLLS RECEIVED, SHALL BE PLACED TO AVOID OCCURRENCE AT CONSPICUOUS LOCATIONS NEAR DOOR OR AT DOORWAYS AND ENTRIES PERPENDICULAR TO DOORS OR ENTRIES. SEAMS OCCURRING PARALLEL TO DOORS SHALL BE CENTERED DIRECTLY UNDER THE DOOR. CONTRACTOR TO SUBMIT SEAMING DIAGRAM FOR ARCHITECT'S REVIEW.	
22. ALL ABANDONED POKE THROUGHS IN THE SLAB SHALL BE PATCH AND FILLED PER STANDARD AS STATED IN THE BUILDING RULES AND REGULATIONS, AND PER ALL LOCAL CODES.	22. GENERAL CONTRACTOR SHALL REVISE AND UPDATE LABELS FOR ALL CIRCUIT BREAKERS AT ALL ELECTRICAL CLOSETS ON THE JOB.	22. SEAMS SHALL BE TRIMMED AND SEAMED IN ACCORDANCE WITH THE MANUFACTURERS' SPECIFICATIONS.	22. SEAMS SHALL BE TRIMMED AND SEAMED IN ACCORDANCE WITH THE MANUFACTURERS' SPECIFICATIONS.	
23. ALL MAJOR DEMOLITION AND NOISE CREATING WORK SHALL OCCUR WITHIN THE HOURS OF 6 PM TO 7 AM DURING THE WEEK. COORDINATE WITH CLIENT AND BUILDING MANAGEMENT.	23. VOICE/DATA FLOOR AND WALL OUTLET BOXES SHALL BE CAPABLE OF FULLY HOUSING THE VOICE/DATA COMPANY'S PREWIRE AMPHENOL CONNECTORS, BOTH FOR SINGLE LINE EXTENSIONS AND FOR CALL DIRECTORS.	23. SPOTS AND/OR SMEARS OF CARPET CEMENT SHALL PROMPTLY BE REMOVED WITH APPROVED SOLVENT.	23. SPOTS AND/OR SMEARS OF CARPET CEMENT SHALL PROMPTLY BE REMOVED WITH APPROVED SOLVENT.	
24. DEMOLITION CONTRACTOR TO REMOVE ANY AND ALL FLOORING, INCLUDING BUT NOT LIMITED TO CARPET, VCT, STONE OR ANY OTHER FLOORING IN THE SPECIFIED AREA, INCLUDING REMOVAL OF ANY AND ALL ADHESIVES, TACK STRIPS, PADDING AND PRIOR FLASHING IN ORDER TO ACHIEVE A SMOOTH AND LEVEL FLOOR.	24. WHERE EXPOSED CONDUIT OR SURFACE MOUNTED WIREMOLD CONDUIT HAS BEEN SPECIFIED, THE CONDUIT SHALL BE RUN IN CORNERS OR ON SIDE OF COLUMNS IN A NEAT AND ORDERLY WAY USING 90° CORNERS RUNNING PARALLEL TO WALLS, COLUMNS, BEAMS AND OTHER CONDUITS TO ABOVE HIGHEST POINT OF BASEBOARD CONVECTOR, AT WHICH POINT CONDUIT IS TO RUN HORIZONTALLY TO ACTUAL LOCATION OF OUTLET AS DIMENSIONED ON PLAN.	24. ALL EXCESS PIECES OF USABLE CARPET SHALL BE ROLLED, TAGGED, AND LEFT WITH THE OWNER FOR FUTURE USE.	24. ALL EXCESS PIECES OF USABLE CARPET SHALL BE ROLLED, TAGGED, AND LEFT WITH THE OWNER FOR FUTURE USE.	
25. DEMOLITION CONTRACTOR TO REMOVE ANY AND ALL DOORS, FRAMES AND HARDWARE IN THE EFFECTED AREAS AND CONSULT WITH BUILDING MANAGER FOR ANY DOORS/FRAMES OR HARDWARE THAT THE LANDLORD MIGHT WANT TO REUSE.	25. GC SHALL COORDINATE WITH THE ELECTRICAL AND MILLWORK CONTRACTORS TO PROVIDE CUTOUTS IN FIELD, AS REQUIRED, FOR EXTENSION OF ELECTRIC OUTLETS, CABLES, ETC. INTO CABINETWORK AS SPECIFIED.	25. CARPET CONTRACTOR SHALL COORDINATE WITH THE ELECTRICIANS REGARDING FLOOR OUTLETS FOR ELECTRICAL AND COMMUNICATION REQUIREMENTS. ALL CUTTING OF CARPET FOR FLOOR OUTLETS AND JUNCTION BOXES SHALL BE THE RESPONSIBILITY OF THE CARPET CONTRACTOR.	25. CARPET CONTRACTOR SHALL COORDINATE WITH THE ELECTRICIANS REGARDING FLOOR OUTLETS FOR ELECTRICAL AND COMMUNICATION REQUIREMENTS. ALL CUTTING OF CARPET FOR FLOOR OUTLETS AND JUNCTION BOXES SHALL BE THE RESPONSIBILITY OF THE CARPET CONTRACTOR.	
26. DEMOLITION CONTRACTOR TO REMOVE ALL CEILINGS AND GRIDS IN EFFECTED AREA AND CONSULT WITH ARCHITECT AS TO THE EXTENT OF REMOVAL OF BLACK IRON SUPPORTS IF THEY EXIST, TO SEE IF ANY CEILING MATERIALS CAN BE REUSED OR COMPLETELY REMOVED.	26. THE ELECTRICAL CONTRACTOR SHALL INCLUDE AND COORDINATE ELECTRICAL REQUIREMENTS FOR ALL HVAC EQUIPMENT, EXHAUST FANS, WATER HEATERS, AND SPECIAL EQUIPMENT, ETC.	26. GENERAL CONTRACTOR TO PROVIDE FIRE-RETARDANT BLOCKING FOR BLINDS ON EXTERIOR WINDOWS THROUGHOUT.	26. GENERAL CONTRACTOR TO PROVIDE FIRE-RETARDANT BLOCKING FOR BLINDS ON EXTERIOR WINDOWS THROUGHOUT.	
27. DEMOLITION CONTRACTOR TO REMOVE ANY OR ALL OUTLETS IN ANY EXISTING WALLS, CONVECTORS AND COLUMNS THEN PATCH AS REQUIRED, SO THAT NO VISIBLE ASPECTS OF THOSE DEVICES ARE SHOWN.	27. ALL ELECTRICAL WORK PERFORMED IN CONNECTION WITH THE INSTALLATION OF THE VOICE/DATA COMMUNICATIONS SYSTEM SHALL BE IN ACCORDANCE WITH THE BUILDING MANAGEMENT AND TELEPHONE COMPANY'S RECOMMENDATIONS AND REQUIREMENTS INCLUDING THE INSTALLATION OF REQUIRED CONDUIT FROM THE BUILDING TELEPHONE EQUIPMENT ROOM TO THE TENANT'S SPACE	27. IN AREAS WITH EXPOSED OPEN CEILINGS, GENERAL CONTRACTOR AND THEIR SUBCONTRACTORS ARE TO PAINT ANY AND ALL EXPOSED SPRINKLER PIPES, CEILING SLABS, BEAMS AND IF NEEDED PATCH CEILING SLAB SMOOTH TO RECEIVE NEW FINISHES. REFER TO FINISH PLAN FOR ADDITIONAL INFORMATION AND SPECIFICATIONS.	27. IN AREAS WITH EXPOSED OPEN CEILINGS, GENERAL CONTRACTOR AND THEIR SUBCONTRACTORS ARE TO PAINT ANY AND ALL EXPOSED SPRINKLER PIPES, CEILING SLABS, BEAMS AND IF NEEDED PATCH CEILING SLAB SMOOTH TO RECEIVE NEW FINISHES. REFER TO FINISH PLAN FOR ADDITIONAL INFORMATION AND SPECIFICATIONS.	
28. REMOVE AND CAP ALL ELECTRICAL AND DATA NOT BEING REUSED IN AREAS OF WORK. COORDINATE WITH ELECTRICAL DRAWINGS.	28. GENERAL CONTRACTOR TO PROVIDE 4" X 8" X 3/4" (FIRE RETARDANT BIRCH VENEER) PLYWOOD PANELS ON 3/4" FURRING AS INDICATED ON THE PLAN, FOR THE VOICE/DATA EQUIPMENT INSTALLATION, UNLESS OTHERWISE NOTED. QUANTITY TO BE DETERMINED BY AMOUNT OF EQUIPMENT AND GC ASSUME AND INCLUDE ANY AND ALL PLYWOOD PANELS AS NEEDED FOR PROPER INSTALLATION OF EQUIPMENT.	28. PAINTING OF ANY SURFACES NOT SPECIFICALLY MENTIONED TO BE PAINTED HEREIN OR ON DRAWINGS, BUT FOR WHICH PAINTING IS OBVIOUSLY NECESSARY TO COMPLETE THE PROJECT OR WORK WHICH COMES WITHIN THE INTENT OF THESE SPECIFICATIONS, SHALL BE INCLUDED AS THROUGH SPECIFIED AND INCLUDED IN SCOPE OF WORK OF CONTRACTOR WITHOUT EXCEPTIONS.	28. PAINTING OF ANY SURFACES NOT SPECIFICALLY MENTIONED TO BE PAINTED HEREIN OR ON DRAWINGS, BUT FOR WHICH PAINTING IS OBVIOUSLY NECESSARY TO COMPLETE THE PROJECT OR WORK WHICH COMES WITHIN THE INTENT OF THESE SPECIFICATIONS, SHALL BE INCLUDED AS THROUGH SPECIFIED AND INCLUDED IN SCOPE OF WORK OF CONTRACTOR WITHOUT EXCEPTIONS.	
29. REUSE OF MATERIAL: GENERAL CONTRACTOR TO REMOVE FROM SITE ALL ITEMS DEEMED NOT REUSABLE BY CLIENT.	COMPUTER CABLE INSTALLATION:			
30. DEMOLITION CONTRACTOR TO REMOVE ALL WIRES FROM UNDER FLOOR DUCT AND CELLS SHALL BE CLEAN AND CAP ALL HOLES.	1. THE GENERAL CONTRACTOR SHALL BE RESPONSIBLE FOR PURCHASING AND INSTALLATION OF ALL VOICE/DATA CABLES AS INDICATED ON THE PLANS. UNLESS OTHERWISE NOTED.			
31. DEMOLITION CONTRACTOR TO VISIT SITE AND UNDERSTAND THE SCOPE OF WORK. SEE ENGINEERING DRAWINGS FOR ANY ADDITIONAL INFORMATION.	2. ALLOW APPROPRIATE LENGTH OF SLACK ON BOTH ENDS OF EACH CABLE TERMINATION FOR CONNECTION TO SPECIFIED EQUIPMENT (MIN. 6").			
32. DEMOLITION CONTRACTOR MUST KEEP ALL DEBRIS REMOVED FROM SITE SEPARATE FROM THE BUILDING TRASH.	3. GC TO DETERMINE MOST ECONOMICAL ROUTE FOR ALL CABLE RUNS FROM ORIGINATION TO TERMINATION POINT AT SERVER RACKS.			

RESPONSIBILITY SCHEDULE												
ANNOTATIONS: O: OWNER; G: GENERAL CONTRACTOR; L: LANDLORD; M: OWNER MILLWORKER; V: OWNER VENDOR												
	DESCRIPTION	FURNISHED / SPECIFIED BY				INSTALLED BY				REMARKS		
01	PREPARATION	O	G	L	M	O	G	L	M	V		
	1. PERMIT AND CONSTRUCTION FEES		●				●				GC TO PICK UP AND PAY FEE FOR CONSTRUCTION PERMITS FROM BUILDING DEPARTMENT.	
	2. INSURANCE & SUBMITTALS		●				●				GC TO SUBMIT INSURANCE INFORMATION AND REQUIREMENTS TO OWNER AND LL AS REQUIRED. GC TO PROVIDE MATERIAL SAMPLES IN TRIPLICATE FOR ARCHITECT REVIEW AND APPROVAL. GC TO PROVIDE SUBMITTALS TO ARCHITECT FOR ALL ITEMS SPECIFIED IN DRAWINGS FOR CONSTRUCTION OF THE WORK.	
	3. DEFERRED SUBMITTALS AND FEES		●				●				DEFERRED SUBMITTALS REQUIRED FOR FIRE PROTECTION. GC TO FILE, PICK UP AND PAY FEES FROM THE BUILDING DEPARTMENT.	
	4. TEMPORARY LIGHTING & UTILITIES		●				●				GC TO PROVIDE AS NEEDED.	
	5. TEMPORARY BARRICADE			●					●		LL APPROVED VENDOR TO INSTALL BARRICADE. GC TO COORDINATE. BARRICADE TO REMAIN IN PLACE THROUGHOUT DURATION OF CONSTRUCTION.	
	6. SLAB		●				●				EXISTING CONCRETE SLAB TO REMAIN.	
	7. CARTING / MINIS		●				●				GC TO PROVIDE AND SCHEDULE CARTING AS REQUIRED.	
	8. DEMOLITION		●				●				REFER TO DEMOLITION SHEETS FOR MORE INFORMATION.	
	9. TRASH REMOVAL AT TURNOVER FOR MERCHANDISING TEAM	●				●						
	10. CLEANING		●				●				GC TO INCLUDE TWO CLEANINGS OF ALL AREAS/ROOMS. (1) CLEANING AT TURN OVER & (1) CLEANING (INCLUDING FIXTURES AND STOREFRONT GLAZING) PRIOR TO TENANT MERCHANDISING.	
	11. DIMENSION VERIFICATION, REVIEW AND APPROVAL OF FRAMING LAYOUT		●				●				GC TO CONFIRM ALL AS EXISTING DIMENSIONS AS RECORDED ON PLANS AND REPORT ALL DISCREPANCIES TO TWO ONE TWO DESIGN. APPROVAL OF FRAMING LAYOUT PRIOR TO CONSTRUCTION - ARCHITECT TO VERIFY.	
02	STOREFRONT	O	G	L	M	O	G	L	M	V		
	1. STOREFRONT SIGNAGE		●				●				GC TO PROVIDE ALL SIGNAGE PER PLANS AND ANY ASSOCIATED PERMIT & ASSOCIATED FEES. PROCURE THROUGH LL APPROVED VENDOR.	
	2. STOREFRONT ENTRY DOOR		●				●			●	REFER TO A701. STOREFRONT VENDOR TO SUBMIT SHOP DRAWINGS FOR APPROVAL. TO BE IMPACT RESISTANT HURRICANE GLAZING FPA NOTED.	
	3. METAL STOREFRONT GLAZING FRAMING SYSTEM AND CLEAR GLAZING		●				●			●	REFER TO A701. STOREFRONT VENDOR TO SUBMIT SHOP DRAWINGS FOR APPROVAL. TO BE IMPACT RESISTANT HURRICANE GLAZING FPA NOTED.	
	4. STOREFRONT FINISH MATERIAL SUBSTRATE		●							●	SUBSTRATE FOR METAL BY GC. GC SHALL INCLUDE SHOP DRAWINGS DIMENSIONS TO ARCHITECT FOR REVIEW. ALL FABRICATION AND INSTALLATION MATERIALS (ie. MORTAR, ADHESIVES, ANCHORS AND MECHANICAL FASTENERS) REQUIRED. TO BE BY GC. METAL FLASHING AND ANY REQUIRED WATERPROOFING TO BE PROVIDED BY GC.	
	5. STOREFRONT METAL REVEAL		●				●				METAL REVEAL BETWEEN STOREFRONT AND NEUTRAL PIER.	
03	STRUCTURAL	O	G	L	M	O	G	L	M	V		
	1. DUCT PENETRATION FRAMING (HEAVY GAUGE)		●				●				REFER TO MECHANICAL DRAWINGS AND DETAILS.	
	2. STOREFRONT FRAMING		●				●				ATTACHMENT FRAMING AS REQUIRED FOR NEW STOREFRONT AND STOREFRONT HEADER.	
04	INTERIOR PARTITIONS	O	G	L	M	O	G	L	M	V		
	1. ROUGH CARPENTRY AND METAL STUD FRAMING		●				●				INCLUDES PREP WORK FOR ALL MILLWORK INSTALL. GC TO COORDINATE LOCATIONS OF BLOCKING WITH MILLWORK SHOP DRAWINGS. ALL FRAMING STUDS, METAL STRAPPING, LATERAL BRACING, ETC AS SHOWN IN THE DRAWINGS TO BE PROVIDED AND INSTALLED BY GC. UNISTRUT SYSTEM SUPPORT FOR FULL-HEIGHT PARTITIONS.	
	2. 3/4" FR PLYWOOD BLOCKING (FOR FIXTURE / MILLWORK AND FINISHES ATTACHMENT)		●				●				ALL IN-WALL BLOCKING TO BE SUPPORTED BY NEW FRAMING. COORDINATE LOCATIONS WITH MILLWORK SHOP DRAWINGS.	
	3. GYP. BOARD FINISHES (INCLUDING TYPE X; CEMENT BOARD, GREEN BOARD, AND DURAROCK)		●				●				SEE PARTITION TYPES AND DETAILS FOR MORE INFORMATION.	
	4. FIRE STOPPING		●				●				ONLY AS NEEDED	
05	CEILING	O	G	L	M	O	G	L	M	V		
	2. SOUND SYSTEM / SPEAKERS		●				●				GC TO PROVIDE OPENING AND INSTALL SPEAKERS. ALL SPEAKERS ARE HOMERUNS. ALL SPEAKERS TO HAVE SHUT-OFF SYSTEM FOR ALARMS AS REQUIRED. GC TO PROVIDE AV/IT RACK IN BOH. SOUND HOOKED UP TO TABLET FOR MUSIC CONTROL. UBIGUITI UNFI IN-CEILING SPEAKER.	
	3. SECURITY SYSTEM (CCTV, BURGLAR ALARM, ACCESS CONTROL, SYSTEM)	●	●				●			●	NEW SYSTEM PROVIDED BY OWNERS VENDOR. ADT. GC TO PULL ALL SECURITY VENDOR PROVIDED WIRES TO ALL LOCATIONS. GC TO CONFIRM ALL DEVICE LOCATIONS WITH SECURITY VENDOR PRIOR TO STARTING WORK. OWNER VENDOR TO PROVIDE WIRE/CABLE TO GC & DO FINAL INSTALLATION OF DEVICES. INSTALL ACTUAL DEVICES. REFER TO RCP & POWER PLAN FOR LAYOUTS. GC TO PROVIDE OUTLET FOR ADT PANEL.	
	4. SUSPENDED GYP. BOARD ON HAT / FURRING TEE CHANNEL		●				●				REFER TO NEW WORK PLANS FOR MORE INFO.	
	5. SOFFIT / COVE FRAMING & GYP. BOARD		●				●				REFER TO NEW WORK PLANS FOR MORE INFO.	
			●				●					
06	LIGHTING	O	G	L	M	O	G	L	M	V		
	1. EXIT SIGNS AND EMERGENCY LIGHTING	●					●				PROVIDED BY OWNER'S VENDOR AND INSTALLED BY GC.	
	2. SALES AREA AND BOH CEILING LIGHTING	●					●				PROVIDED BY OWNER'S VENDOR AND INSTALLED BY GC.	
07	ELECTRICAL	O	G	L	M	O	G	L	M	V		
	1. ELECTRICAL WORK - AS SPECIFIED IN CONSTRUCTION SET		●				●				REFER TO NEW WORK PLANS FOR MORE INFO. GC TO PULL ELECTRICAL CONNECTIONS FROM EXISTING ELECTRICAL PANEL IN BACK OF HOUSE TO ALL POINTS OF ELECTRICAL CONNECTIONS THROUGHOUT STORE. CIRCUITS TO BE REALLOCATED TO ACCOMMODATE NEW WORK PLANS.	
	2. POS EQUIPMENT IN CASHWRAP	●				●					OWNER TO PROVIDE POS COMPONENTS AND ALL EQUIPMENT. GC TO COORDINATE AS REQUIRED. ALL ELECTRICAL CONNECTIONS BY GC	
	3. MILLWORK FIXTURE FINAL HOOK-UP		●				●				REFER TO MILLWORK SHOP DRAWINGS. REFER TO POWER PLANS FOR LOCATIONS OF DRIVERS AND J-BOXES FOR ALL MILLWORK.	
	4. GENERAL LIGHT CONTROL		●				●				TIME CLOCKS, RELAYS, OVERRIDES, CONTACTORS & LOCAL DIMMER SWITCHES SHOWN ON ENGINEERING PLANS ARE TO BE FAI BY GC AND WILL NOT BE CONSIDERED "LIGHTING CONTROL SYSTEM".	
08	MECHANICAL	O	G	L	M	O	G	L	M	V		
	1. MECHANICAL WORK - AS SPECIFIED IN CONSTRUCTION SET		●				●				REFER TO MECHANICAL PLANS FOR MORE INFO.	
	2. HVAC UNITS / EQUIPMENT		●				●				GC MUST PROVIDE COORDINATED HVAC SHOPS. IF GC DOES NOT PROVIDE GC SHALL BE RESPONSIBLE FOR ALL CONFLICTS NOT COORDINATED BETWEEN ARCHITECTURAL AND MEP SCOPE.	
	3. DUCTWORK / DIFFUSER		●				●				REFER TO MECHANICAL PLANS FOR MORE INFO.	
	4. TEMPERATURE CONTROLS AND SENSORS		●				●				REFER TO NEW WORK PLANS FOR MORE INFO. GC TO PROVIDE AND INSTALL REMOTE BUTTON TYPE TEMPERATURE SENSOR AS PER PLANS. T-STAT CONTROL TO BE LOCATED IN BACK OF HOUSE; SEE MECHANICAL DRAWINGS GC TO PROVIDE SPEC FOR SENSOR AND CONFIRM FINAL LOCATION WITH ARCHITECT.	
	5. TESTING & AIR BALANCE REPORT		●				●				AABC OR NEEB CERTIFIED.	
	6. AS-BUILT DRAWINGS		●				●				UPON COMPLETION OF PROJECT PROVIDE MECHANICAL AS-BUILT DRAWINGS.	
09	PLUMBING	O	G	L	M	O	G	L	M	V		

	DESCRIPTION	FURNISHED / SPECIFIED BY				INSTALLED BY					REMARKS
		O	G	L	M	O	G	L	M	V	
10	FIRE PROTECTION	O	G	L	M	O	G	L	M	V	
	1. FIRE EXTINGUISHERS		●				●				GC TO PROVIDE NEW FIRE EXTINGUISHERS AS PER DRAWINGS. COMPLY WITH ALL LOCAL CODES & LL REQUIREMENTS.
	2. FIRE ALARM WORK		●				●				NEW TENANT FIRE ALARM SYSTEM BID AND DESIGNED BY LANDLORD'S REQUIRED FIRE ALARM CONTRACTOR TO MEET ALL REQUIREMENTS AS LAID OUT BY OAKRIDGE AND LANDLORD. FIRE ALARM DEVICES ARE AN EXTENSION OF THE EXISTING FIRE ALARM SYSTEM OWNED AND OPERATED BY LL. LL WILL PROVIDE A JUNCTION BOX INSIDE THE REAR PORTION OF THE DEMISED PREMISES WITH WIRING CONNECTION POINTS TO LANDLORD'S FIRE ALARM SYSTEM FOR STROBES, SPEAKERS, AND MONITOR MODULES.
11	SPRINKLER	O	G	L	M	O	G	L	M	V	
	1. SPRINKLER WORK		●				●				MODIFY SPRINKLER SYSTEM IN ACCORDANCE WITH NFPA 13. SPRINKLER SHOP DRAWINGS, HYDRAULIC CALCULATIONS, LIFE SAFETY SYSTEMS, AND CUT SHEETS OF DEVICES SHALL BE PREPARED BY LANDLORD'S REQUIRED SPRINKLER CONTRACTOR AND (DEFERRED) SUBMITTED TO THE CITY OF VANCOUVER FOR REVIEW AND APPROVAL. PROVIDE A COPY OF THE APPROVED DRAWINGS TO LANDLORD PRIOR TO INITIATING WORK.
12	DOORS & HARDWARE	O	G	L	M	O	G	L	M	V	
	1. NEW INTERIOR DOORS AND HARDWARE		●				●				GC TO PROVIDE COORDINATED SHOP DRAWINGS FOR ARCHITECT REVIEW AND APPROVAL.
13	FIXTURES / FURNISHING	O	G	L	M	O	G	L	M	V	
	1. OWNER FURNISHINGS		●				●				REFER TO FIXTURE SCHEDULE. OWNER TO COORDINATE DELIVERIES WITH GC. GC TO DISPOSE OF ALL PACKING/CRATES AS NECESSARY.
	2. SALES FLOOR MILLWORK FIXTURES				●		●				REFER TO FIXTURE SCHEDULE. PROVIDED BY MILLWORKER & INSTALLED BY GC. GC TO FULLY COORDINATE CONSTRUCTION SCHEDULE WITH MILLWORKER FOR GC INSTALL OF ALL IN-WALL OUTRIGGER/BRAKETS PRIOR TO INSTALLATION OF GYPSUM BOARD. PROVIDE ADDITIONAL SUPPORT FRAMING & BLOCKING AS REQUIRED. REFER TO MILLWORK SHOP DRAWINGS FOR MORE INFORMATION. GC TO COORDINATE WITH ELECTRICAL REQUIREMENTS WIRING & LIGHTING. GC TO COORDINATE & RECEIVE SHIPMENT. SEE GENERAL NOTE 2.
	3. CASH WRAP				●		●				GC TO PULL POWER AND DATA AS REQUIRED FOR CASH WRAP FIXTURES. OWNER TO PROVIDE CASH WRAP EQUIPMENT. NEC RATED BOXES REQUIRED FOR INTERIOR OF CASH WRAP.
	4. BOH STORAGE FIXTURES		●				●		●		STORAGE FIXTURES TO BE PROVIDED BY OWNERS VENDOR. GC TO PROVIDE ANY REQUIRED BLOCKING OR SUPPORT. VENDOR TO INSTALL FINAL SHELVING.
	5. BOH OFFICE FIXTURES		●				●				EXISTING MILLWORK AT BOH TO REMAIN AS IS. OWNER TO PROVIDE EQUIPMENT. GC TO INSTALL AS REQUIRED.
14	FINISHES	O	G	L	M	O	G	L	M	V	
	1. TENANT CARPET FLOOR		●				●				MATERIAL PROVIDED BY OWNER'S VENDOR TO BE PURCHASED BY GC & INSTALLED BY GC. GC TO PROTECT NEW FINISHED FLOORING (MIN. MASONITE) REGARDLESS OF PHASING. INCLUDE UNDERLAYMENT AS REQUIRED. INFILL TO BE PROVIDED BY GC AS REQUIRED TO MEET LEVEL.
	2. WALL AND CEILING PAINT FINISHES		●				●				PRIME AND PROVIDE AS MANY COATS AS REQUIRED FOR OPAQUE LEVEL 5 FINISH.
	3. WALL PANELING		●				●				GC TO PREP WALL AS SPECIFIED, REFER TO FINISH PLAN & FINISH SCHEDULE FOR MORE INFORMATION.
	4. MALL FLOORING TILE/PAVERS		●				●				MALL FLOORING FINISH TO EXTEND INTO TENANT ENTRYWAY UP TO DOOR CLOSURE LINE
	5. SCHEDULED WALL BASE		●				●				INCLUDING SURFACE MOUNTED WALL BASE, VINYL BASE, ETC.
	6. METAL FLOORING TRANSITIONS		●				●				REFER TO FLOOR FINISH PLAN AND CORRESPONDING DETAILS
15	CONCRETE / MASONRY	O	G	L	M	O	G	L	M	V	
	1. CONCRETE PATCHING / LEVELING		●				●				ONLY AS REQUIRED TO PATCH NEW/EXISTING SLAB PENETRATIONS OR MAJOR IMPERFECTIONS FROM DEMOLITION FOR INSTALL OF NEW FLOOR FINISH
16	SECURITY / AV / TEL & DATA	O	G	L	M	O	G	L	M	V	
	1. TELE / DATA CABLING		●				●			●	OWNER VENDOR TO FURNISH AND INSTALL ALL CAT5E CABLES; PUNCH DOWN, TONE TEST, LABEL AT PATCH PANEL AND WALL OUTLET AND PROVIDE A MARKED UP NETWORK PLAN WITH ASSOCIATED OUTLET NUMBERS. FOR NUMBER OF CABLES REFER TO RCP, POWER & SIGNAL & INTERIOR ELEVATION DWGS.
	2. IT DATA RACK & PATCH PANEL		●	●			●				GC TO PROVIDE & INSTALL IT RACK (RECEIVE, ASSEMBLE & SET IN PLACE). REFER TO OWNERS EQUIPMENT LIST FOR REQUIRED INSTALL ITEMS. REFER TO POWER PLANS FOR ADDITIONAL INFORMATION.
	3. INTERNET		●				●				REFER TO NEW WORK PLANS FOR MORE INFO. GC TO PREP AREA PROVIDE SUPPORT SYSTEM FOR MOUNTING AND TO PROVIDE CONDUIT AND PULL STRINGS. FROM IT RACK TO INCOMING SOURCE OF INTERNET CABLE PROVIDER DEMARK.
	4. LOW VOLTAGE		●				●				REFER TO NEW WORK PLANS FOR MORE INFO.
	6. SOUND EQUIPMENT		●				●		●		NEW AUDIO SYSTEM SUPPLIED BY GC. GC TO INSTALL. GC TO SUPPLY BOSE DESIGNMAX DMSC SPEAKERS (OR APPROVED EQUAL). AUDIO WIRE/CABLE. GC TO PULL ALL WIRES/CABLES TO SPEAKER LOCATIONS PER FINAL APPROVED PLANS. ALL SPEAKERS REQUIRE TESTING PRIOR TO BEING TAPED-IN/MUDDERED OVER. ALL SPEAKERS ARE HOMERUNS. GC TO PROVIDE & INSTALL AV RACK AND DO FINAL TERMINATIONS OF SOUND EQUIPMENT WITHIN RACK. COORDINATE WITH OWNERS IT VENDOR. SEE OWNERS IT/AV LIST FOR ADDITIONAL INFORMATION. EQUIPMENT IS BEING INSTALLED BY OWNER'S VENDOR LOCATED INSIDE RACK.
	6. CCTV & BURGLAR		●				●		●		OWNER VENDOR PROVIDED WIRE. GC TO PULL CABLEING TO FINAL LOCATIONS PER APPROVED PLANS., TERMINATED BY GC.
17	SPECIALTY / MISCELLANEOUS	O	G	L	M	O	G	L	M	V	
	1. ACCESS PANEL(S)		●				●				BOTH CEILING & WALL ACCESS PANELS TO BE PROVIDED & INSTALLED BY GC - REFER TO RCP, POWER PLAN, AND INTERIOR ELEVATION DWGS.
GENERAL NOTES											
1. THE 'RESPONSIBILITY SCHEDULE' IS INTENDED TO BE USED AS A GUIDE ONLY, AND IS NOT ALL-INCLUSIVE. ALL PERSONS BIDDING WORK OR CONTRACTED WORK ARE TO REVIEW THESE DOCUMENTS, THE LANDLORD CRITERIA, AND THE EXECUTED LEASE AGREEMENT IN THEIR ENTIRETY. NOTIFY THE OWNER, PM, OR ARCHITECT IN WRITING OF ANY CONFLICTS PRIOR TO SUBMITTING BID.											
2. IT IS THE RESPONSIBILITY OF THE GENERAL CONTRACTOR TO RECEIVE, OFFLOAD, UNCRATE, DISPOSE OF CRATING OR PROTECTION, ASSEMBLE, AND INSTALL ALL OWNER FURNISHED ITEMS, INCLUDING BUT NOT LIMITED TO, MILLWORK, SIGNAGE, STONE, ETC. ALL DELIVERIES TO BE SCHEDULED BY GC DURING TIMES APPROVED BY THE AUTHORITIES HAVING JURISDICTION. NO EXTRA COSTS TO AMIRI SHALL BE ACCEPTED DUE TO SCHEDULING DELIVERIES DURING NIGHT TIME OR OVERTIME.											
3. GENERAL CONTRACTOR IS RESPONSIBLE TO PROTECT AND COVER ALL FINISHES ON WALLS, FLOORS AND FIXTURES / FURNITURE AFTER INSTALLATION AS REQUIRED REGARDLESS OF PHASING & SEQUENCING											
4. PLEASE CONTACT TWO ONE TWO DESIGN WITH ANY DISCREPANCIES WITH RESPONSIBILITY SCHEDULE.											
5. ALL ITEMS NOTED WITHIN THIS SET OF DOCUMENTS SHALL BE THE RESPONSIBILITY OF THE GENERAL CONTRACTOR TO FURNISH AND INSTALL UNLESS OTHERWISE NOTED OR EXISTING.											
OWNER VENDORS						LANDLORD APPROVED VENDORS - AS APPLICABLE TO PROJECT SCOPE					
MILLWORK CONTRACTOR		SECURITY (BURGLAR / CCTV) VENDOR				<div><div><div>FIRE ALARM</div><div>JOHNSON CONTROLS</div><div>JASON FITZPATRICK</div><div>P: 941-204-3482</div><div>JASON.A1.FITZPATRICK@JCI.COM</div></div><div><div>FIRE SPRINKLER</div><div>WAYNE AUTOMATIC FIRE SPRINKLER</div><div>P: 239-433-3030</div></div><div><div>BARRICADE CONSTRUCTION</div><div>COASTAL MAINTENANCE AND RESTORATION</div><div>P: 239-260-1833</div></div><div><div>TRASH REMOVAL</div><div>EAGLE</div><div>P: 239-598-0013</div></div></div>					
IT/AV											

<div>TWO ONE TWO</div> <div>45 WEST 21st STREET, SUITE 403 NEW YORK, NY 10010</div>			
IN ASSOCIATION WITH THE ARCHITECT: R H SWEERS II, PROPRIETOR R H SWEERS ARCHITECT			
<p>ALL DRAWINGS AND WRITTEN MATERIAL APPEARING HEREIN CONSTITUTE ORIGINAL AND UNPUBLISHED WORK OF THE ARCHITECT AND MAY NOT BE DUPLICATED, USED OR DISCLOSED WITHOUT WRITTEN</p> <p>CONSENT OF THE ARCHITECT. THIS DOCUMENT IS INTENDED SOLELY FOR THE CONSTRUCTION OF THE PROJECT NAMED HEREIN AND SHALL NOT BE USED BY ANY OTHER CONSTRUCTION WITHOUT WRITTEN CONSENT OF THE ARCHITECT.</p> <p>THIS DRAWING WAS PREPARED UNDER MY SUPERVISION AND I DISCLAIM ANY RESPONSIBILITY FOR THE EXISTING BUILDING CONSTRUCTION ELEMENTS, SITE CONDITIONS, OR ANY DOCUMENTS WHICH DO NOT BEAR MY SEAL.</p>			
SEAL			
DRAWINGS ISSUED			
No.	Rev	Date	Description
1		06.18.26	LL REVIEW SET
3		07.02.26	ISSUE FOR BID
5	2	08.27.26	BID ADDENDUM #2
PROJECT NAME:			
TWP NAPLES			
TWP			
PROJECT ADDRESS:			
WATERSIDE SHOPS			
5455 TAMIAMI TRL N			
NAPLES, FL 34108			
DRAWING TITLE:			
RESPONSIBILITY			
SCHEDULE			
SCALE: AS SHOWN			
Project No.	26TWP05		
Scale:	1/4" = 1'-0"		
Date:	08-20-2026		
Drawn By:	212		
Checked BY:	212		
DRAWING NO:			
G-006			

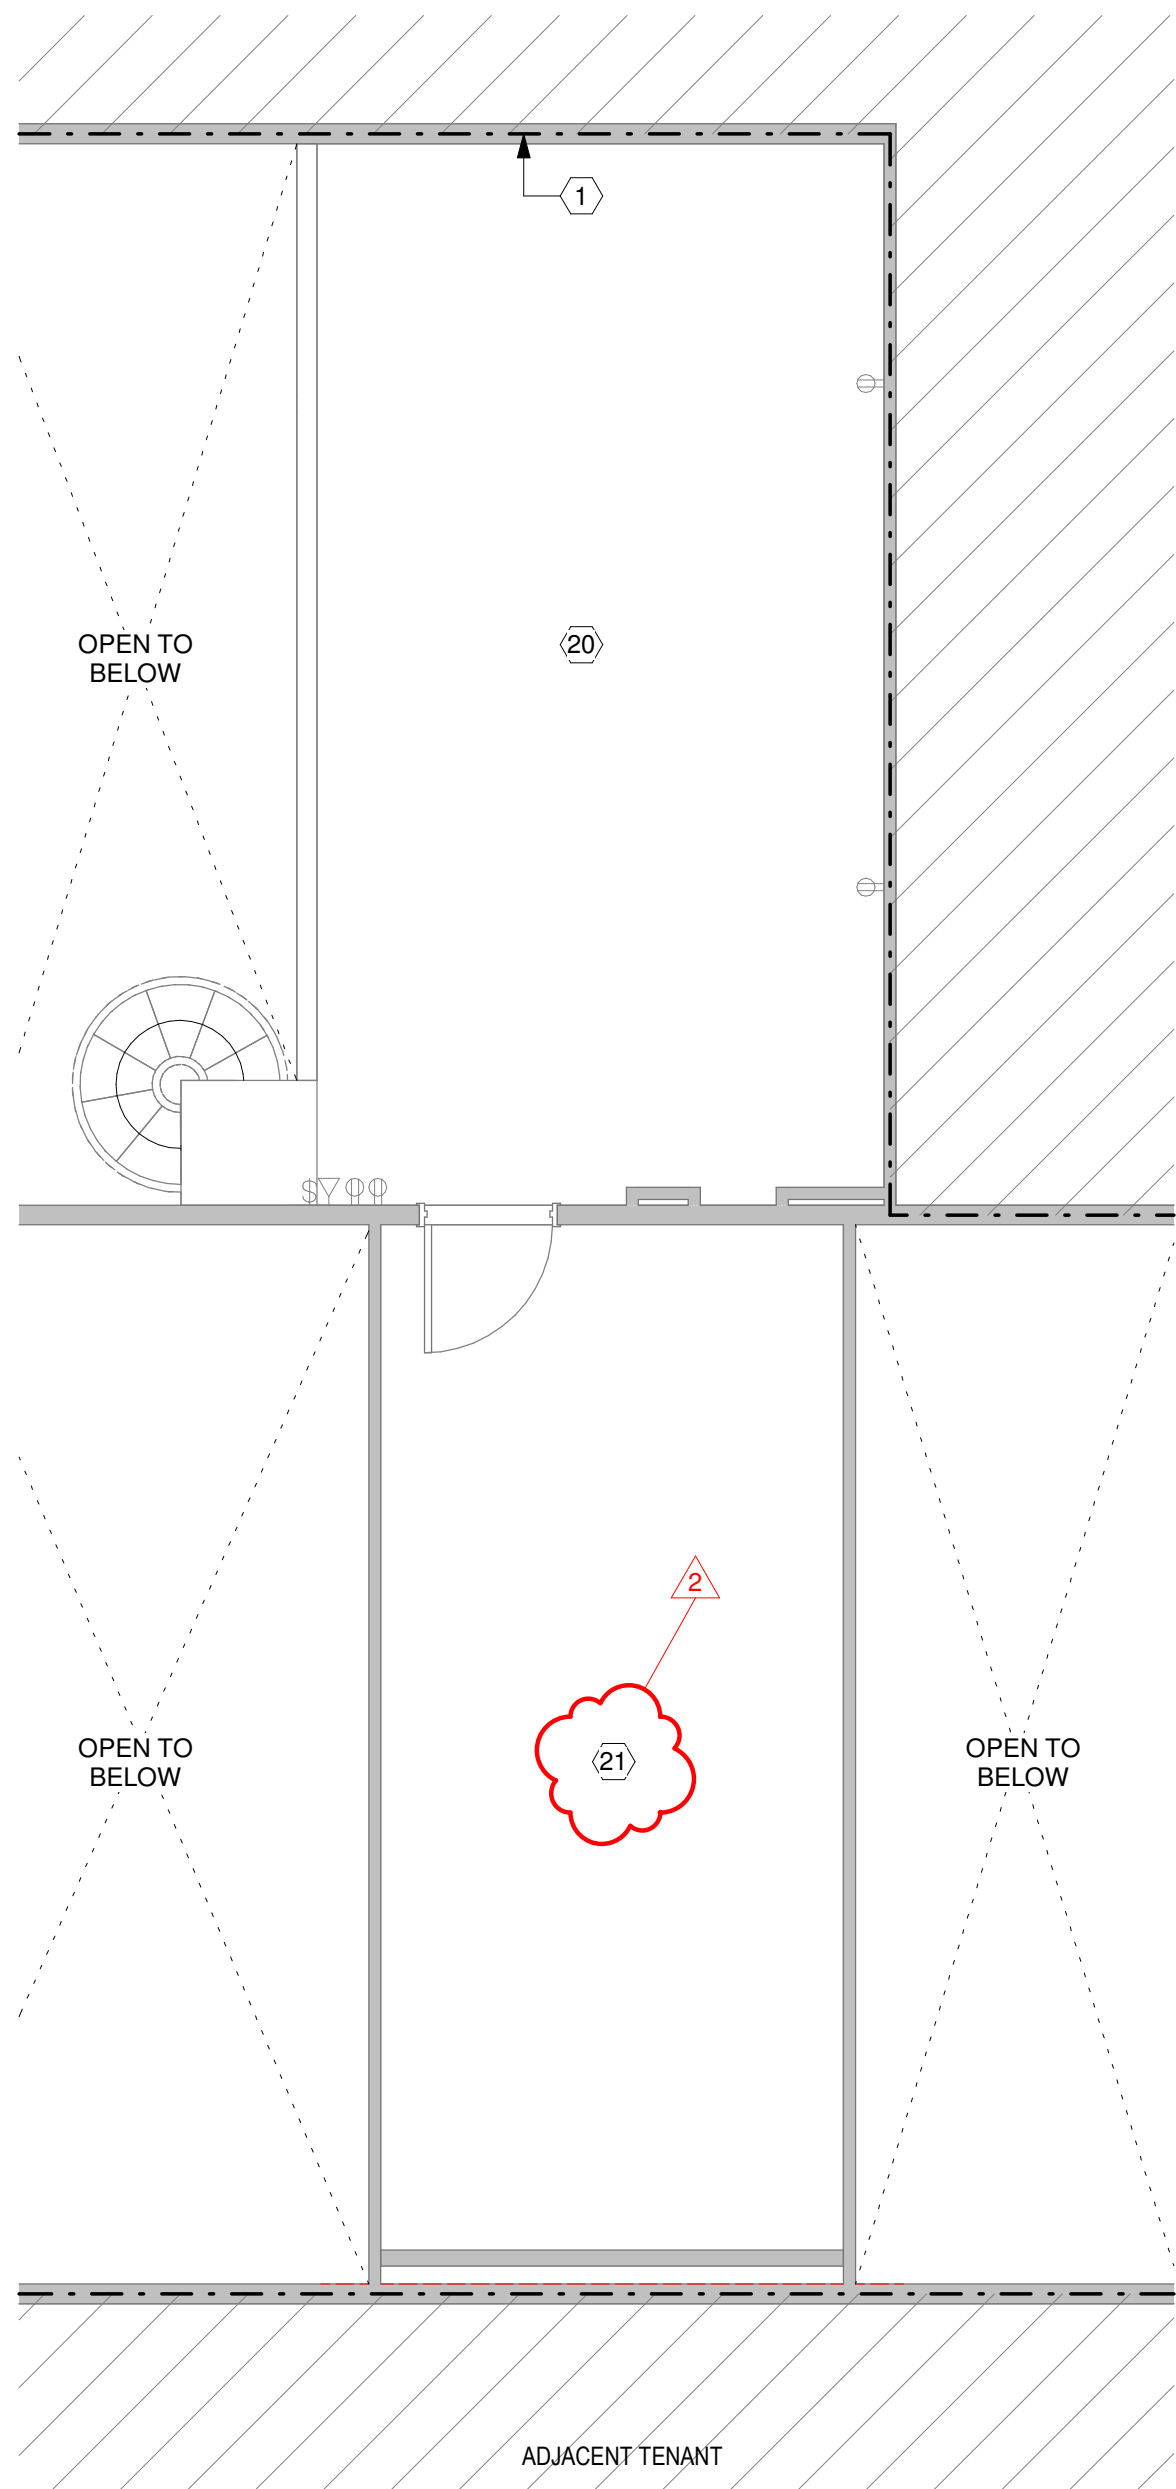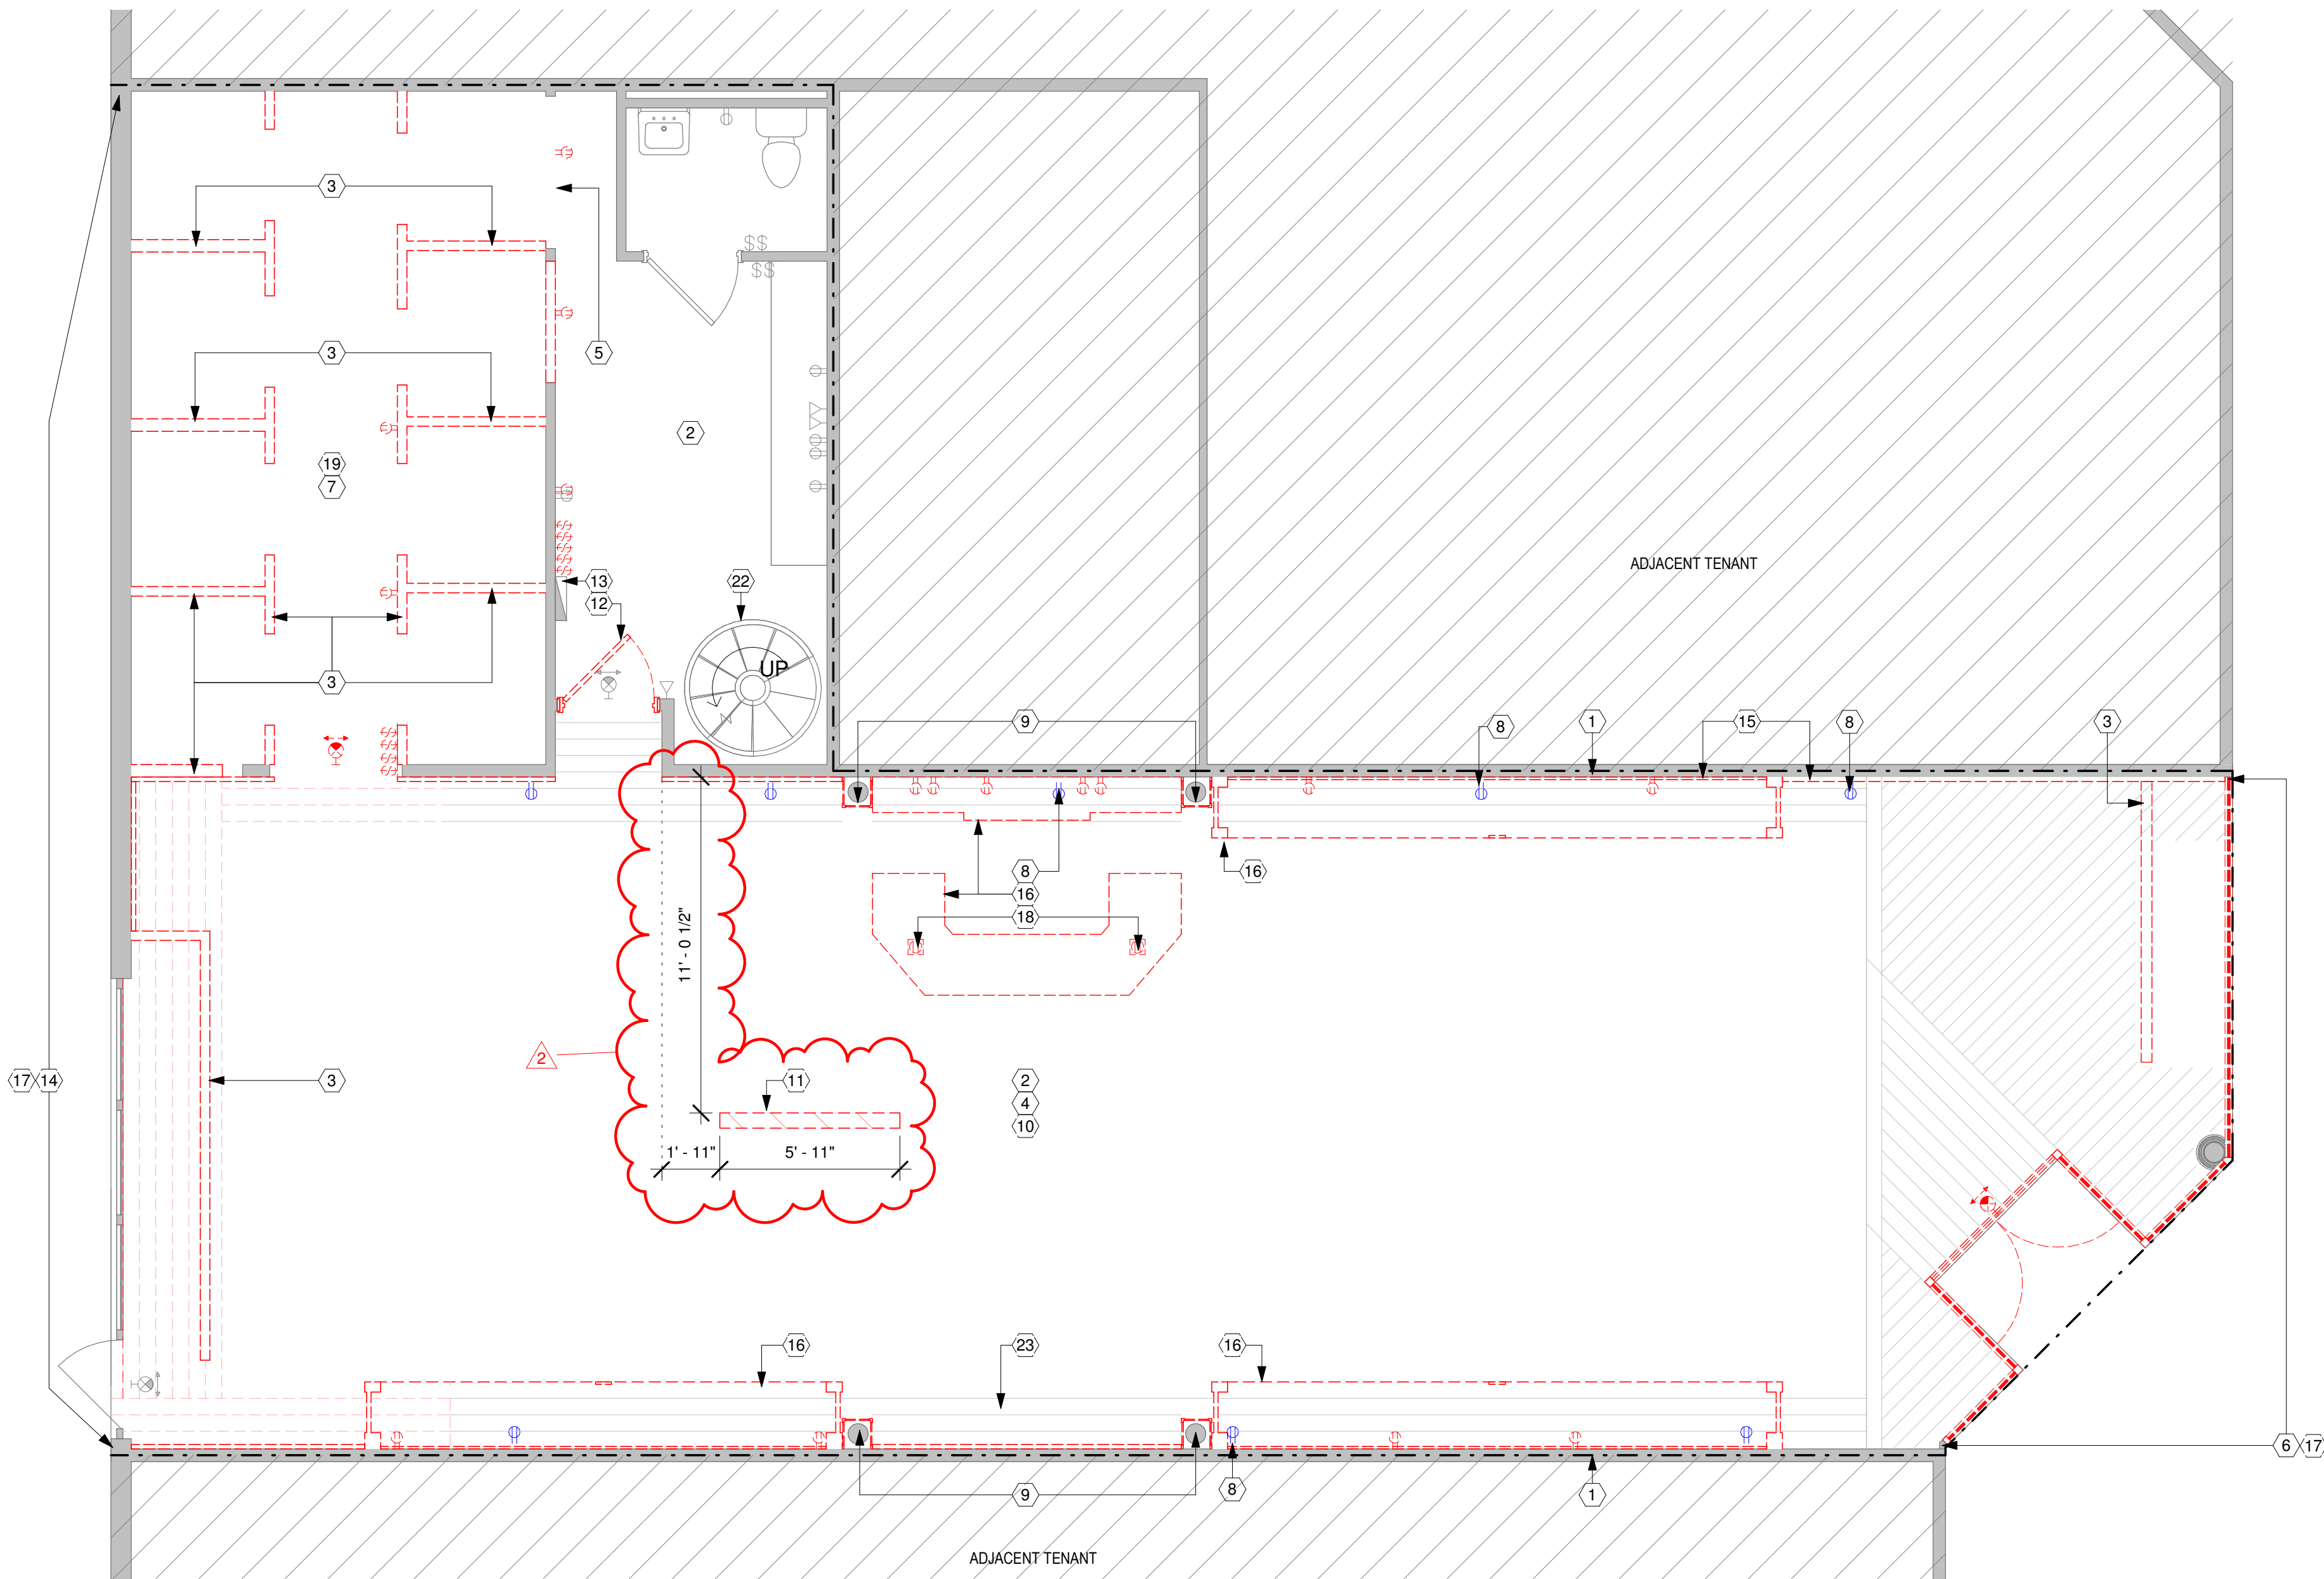

2 MEZZANINE DEMOLITION PLAN
SCALE: 1/4" = 1'-0"

1 DEMOLITION PLAN
SCALE: 1/4" = 1'-0"

LANDLORD BARRICADE NOTES

TENANT CONTRACTOR SHALL PROVIDE A FULL HEIGHT CONTINUOUS DUCT-PROOF BARRIER AT THE STOREFRONT. LANDLORD AT LANDLORD'S DISCRETION, WILL PROVIDE A FULL HEIGHT TEMPORARY FLAT STOREFRONT BARRICADE AT MALL LEASE LINE. GC RESPONSIBLE FOR RELOCATING BARRICADE MAX 3'-0" BEYOND THE LEASE LINE, PROVIDING AND INSTALLING END PANELS TO MATCH. A LL APPROVED CONTINUOUS DUSTPROOF BARRIER (FROM BOTTOM OF BARRICADE TO LL BULKHEAD) AND INSTALLING GRAPHICS. GC SHALL NOT DRILL OR OTHERWISE ANCHOR DIRECTLY INTO ENCLOSED MALL FLOOR AND SHALL PROVIDE SUFFICIENT PROTECTION OF THE ENCLOSED MALL FLOOR TO PREVENT ANY DAMAGE DURING STOREFRONT CONSTRUCTION. GC IS RESPONSIBLE FOR REMOVAL AND DISPOSAL OF THE BARRICADE TO A LOCATION DESIGNATED BY LL.

NO DOORS ALLOWED IN BARRICADE - REMOVABLE PANEL ONLY. CONSTRUCTION ACCESS TO SPACE THROUGH REAR SERVICE EXIT ONLY. ACCESS NOT ALLOWED THROUGH THE TEMPORARY STOREFRONT BARRICADES

LANDLORD DEMOLITION NOTES

ANYTHING UNUSED INCLUDING, BUT NOT LIMITED TO ALL ABANDONED AND/OR UNUSED DUCTWORK, PIPING, EQUIPMENT, ELECTRICAL, ETC SHALL BE REMOVED FROM SITE. DO NOT ABANDON ANYTHING IN PLACE.

ALL DEMOLITION AND DEBRIS REMOVAL IS TO TAKE PLACE DURING NON-MALL HOURS.

CONTRACTOR TO HAUL AWAY DEBRIS DAILY THROUGH REAR SERVICE EXIT ONLY.

DURING DEMOLITION, FIRE SPRINKLER SYSTEM MUST BE BLANKED OFF PRIOR TO COMMENCING DEMOLITION.

PROTECT ALL MALL FINISHES FROM DAMAGE FOR DURATION OF PROJECT. REPAIR ANY DAMAGE IN COORDINATION WITH MALL FIELD REP. AS REQUIRED. TYPICAL ALL PIERS AND BULKHEADS (TYPICAL).

IF REMOVAL OF NEUTRAL PIER(S) OR OTHER LL FINISHES IS REQUIRED, COORDINATE WITH LL FIELD REP PRIOR TO BEGINNING WORK.

ALL EXISTING FINISHES TO BE REMOVED BACK TO DEMISING WALLS AND BASE BUILDING STRUCTURE UNLESS OTHERWISE ACCEPTED BY LL.

COORDINATE ALL MEP DEMOLITION AND ANY REQUIRED CORING/TRENCHING WITH LANDLORD FIELD REP. TRENCHING IS NOT PERMITTED FOR TENANTS NOT LOCATED ON GRADE.

REMOVE ALL ABANDONED UTILITY LINES BACK TO MAIN (TYP).

TENANT RESPONSIBLE TO PROVIDE AND MAINTAIN FLOOR PROTECTION OF MALL TILE UNDER BARRICADE THROUGH PROJECT DURATION.

TENANT IS RESPONSIBLE FOR INSTALLING AND MAINTAINING SOUND INSULATION IN BARRICADE THROUGH PROJECT DURATION.

ANY ADJUSTMENTS TO THE WORK ARISING FROM FIELD CONDITIONS NOT APPARENT ON DRAWINGS AND OTHER BUILDING DOCUMENTS SHALL RECEIVE WRITTEN APPROVAL OF LANDLORD PRIOR TO START OF CONSTRUCTION.

TENANT AND GC TO CONFIRM ALL REUSED SYSTEMS, EQUIPMENT, FINISHES, ETC. ARE IN GOOD WORKING ORDER AND MEET ALL CURRENT CODES AND TENANT CRITERIA MANUAL REQUIREMENTS. IT IS THE TENANT'S RESPONSIBILITY TO REPLACE ALL ITEMS DUE TO CURRENT OR FUTURE CONDITIONS AND/OR QUALITY.

DEMOLITION PLAN LEGEND

SYMBOL	DESCRIPTION
	EXISTING TO BE REMOVED. REFER TO KEY NOTES FOR SCOPE.
	EXISTING TO REMAIN
	LEASE LINE
	AREA NOT IN CONTRACT
	DEMO FINISH
	RELOCATED

DEMOLITION PLAN KEY NOTES (#)

- EXISTING DEMISING WALLS TO REMAIN. PATCH AND REPAIR WHERE ADJACENT WALLS (OR MILLWORK) ARE REMOVED. REMOVE ANY APPLIED MATERIAL WALL FINISHES AND PREP FOR NEW AS REQUIRED. GC TO PROVIDE VISQUEEN BARRIER TO SEAL WALL OPENINGS THROUGHOUT, INCLUDING BACKSIDE OF STOREFRONT, AS REQUIRED DURING DEMOLITION AND CONSTRUCTION.
- REMOVE PREVIOUS TENANT IT EQUIPMENT AND SECURITY EQUIPMENT. DATA CABLING/LOW VOLTAGE (AND ASSOCIATED CONDUIT) TO REMAIN U.O.N. MAINTAIN PRIMARY STORE STUB-INS FOR CABLE/DATA AND TELEPHONE. RELOCATE TO ADJACENT WALL POWER AND PANELING AS REQUIRED. REFER TO MEP, LOW VOLTAGE, AND SECURITY DRAWINGS FOR MORE INFORMATION.
- REMOVE EXISTING NON-LOAD BEARING PARTITION IN ITS ENTIRETY, INCLUDING ASSOCIATED POWER/DATA, MOULDING, AND DECORATIVE FEATURES.
- REMOVE ALL PREVIOUS TENANT FINISHES, MILLWORK CLADDING & BUILT-INS THROUGHOUT INCLUDING ASSOCIATED UTILITIES.
- PORTION OF EXISTING PARTITION TO BE REMOVED AS INDICATED.
- STOREFRONT TO BE DEMOLISHED IN ITS ENTIRETY INCLUDING FRAMING, GLAZING, DOORS, DECORATIVE ELEMENTS, AND AWNINGS. SEE STOREFRONT DRAWINGS FOR NEW STOREFRONT. GC TO PATCH AND REPAIR DAMAGED TILING, EXTERIOR CEILING, AND ADJACENT NEUTRAL PIERS AS REQUIRED.
- EXISTING FURNITURE AND WALL MOUNTED FIXTURES IN FITTING ROOM INCLUDING CURTAINS, MIRRORS, HANGBARS, AND TRACKS TO BE REMOVED. PATCH AND REPAIR CEILING AND REMAINING WALLS AS REQUIRED TO RECEIVE NEW FIXTURES, INCLUDING BLOCKING, AND FINISHES. REFER TO FINISH PLAN AND FIXTURE PLAN FOR MORE INFORMATION.
- POWER/DATA RECEPTACLE TO BE PUSHED BACK TO BE FLUSH WITH NEW WALL AS INDICATED. GC TO NOTIFY ARCHITECT OF FIELD DISCREPANCIES. OUTLET FOR CONVENIENCE AND TO SIT BELOW 2FT.
- EXISTING STRUCTURAL COLUMN TO REMAIN. PROTECT DURING ALL PHASES OF DEMOLITION & CONSTRUCTION.
- REMOVE PREVIOUS TENANT'S CARPET THROUGHOUT INCLUDING TRANSITION STRIPS. PATCH AND REPAIR EXISTING SUBFLOORING AS REQUIRED TO MAINTAIN FLUSH ALIGNMENT TO EXTERIOR. AREAS OF NEW SUBFLOORING TO MATCH EXISTING. PREP TO RECEIVE NEW CARPET FINISH THROUGHOUT SALES AREA.
- POWER/TRENCHING REQUIRED FOR FLOOR OUTLETS. SEE ELECTRICAL PLAN AND DRAWINGS FOR MORE INFORMATION AND LOCATIONS. COORDINATE ALL CORING/TRENCHING WITH LANDLORD FIELD REP. ALL FLOOR SLAB PENETRATIONS MUST BE SEALED, MADE WATER TIGHT AND FIRE PROOF TO MATCH MALL REQUIREMENTS AND DETAILS.
- REMOVE EXISTING DOOR. OPENING TO REMAIN. PATCH, REPAIR, AND PREP TO RECEIVE NEW FINISH.
- EXISTING ELECTRICAL PANEL TO REMAIN.
- DEMO AWNINGS, SIGNAGE, CLADDING, AND DECORATIVE ELEMENTS AT BACK STOREFRONT DISPLAY FACING PARKING LOT. PATCH AND REPAIR WALL FROM DAMAGE BY REMOVAL AS REQUIRED. COORDINATE WITH LANDLORD ON FINISH SPECS.
- GC TO STRIP BACK MILLWORK PANELING, STANDARDS, AND WALL FURR-OUTS TO DEMISING WALL. GC TO REPAIR DEMISING WALL TO LIKE NEW CONDITION INCLUDING PROVIDING NEW TYPE 'X' GYP AS REQUIRED TO FLUSH OUT WALL. REFER TO FINISH PLAN FOR REQUIRED FINISH LEVEL.
- EXISTING BUILT-IN MILLWORK AND ALL ASSOCIATED LIGHTING AND POWER TO BE REMOVED IN ITS ENTIRETY.
- STOREFRONT BARRICADE (BY LANDLORD) TO REMAIN IN PLACE FOR DURATION OF DEMOLITION AND CONSTRUCTION.
- EXISTING FLOOR POWER BOXES TO BE REMOVED IN THEIR ENTIRETY.
- EXISTING LIGHTING IN FITTING ROOMS TO BE REMOVED.
- REMOVE PREVIOUS TENANT'S EXISTING SHELVING AND HANGING UNITS. REFER TO MECHANICAL DWGS FOR EXTENT OF DEMO REQUIRED.
- EXISTING SPIRAL STAIRCASE TO REMAIN - USED ONLY TO ACCESS MECHANICAL.
- EXISTING WOOD FLOOR TO BE PROTECTED IN PLACE TO BE SANDED AND REFINISHED. SEE FINISH PLANS FOR MORE INFORMATION AND EXTENT.



45 WEST 21st STREET, SUITE 403
NEW YORK, NY 10010

IN ASSOCIATION WITH THE ARCHITECT:
R H SWEERS II, PROPRIETOR
R H SWEERS ARCHITECT

ALL DRAWINGS AND WRITTEN MATERIAL APPEARING HEREIN CONSTITUTE ORIGINAL AND UNPUBLISHED WORK OF THE ARCHITECT AND MAY NOT BE DUPLICATED, USED OR DISCLOSED WITHOUT WRITTEN CONSENT OF THE ARCHITECT. THIS DOCUMENT IS INTENDED SOLELY FOR THE CONSTRUCTION OF THE PROJECT NAMED HEREIN AND SHALL NOT BE USED BY ANY OTHER CONSTRUCTION WITHOUT WRITTEN CONSENT OF THE ARCHITECT.

THIS DRAWING WAS PREPARED UNDER MY SUPERVISION AND I DISCLAIM ANY RESPONSIBILITY FOR THE EXISTING BUILDING CONSTRUCTION ELEMENTS, SITE CONDITIONS, OR ANY DOCUMENTS WHICH DO NOT BEAR MY SEAL.

SEAL

ISSUE FOR BID

DRAWINGS ISSUED

No.	Rev	Date	Description
1		06.18.26	LL REVIEW SET
2		06.24.26	ISSUE FOR PERMIT
3		07.02.26	ISSUE FOR BID
5	2	08.27.26	BID ADDENDUM #2

PROJECT NAME:

TWP NAPLES

TWP

PROJECT ADDRESS:

WATERSIDE SHOPS
5455 TAMIAMI TRL N
NAPLES, FL 34108



DRAWING TITLE:

DEMOLITION PLAN

SCALE: AS SHOWN

Project No.	26TWP05
Scale:	1/4" = 1'-0"
Date:	08-20-2026
Drawn By:	212
Checked By:	212
DRAWING NO:	

D-101

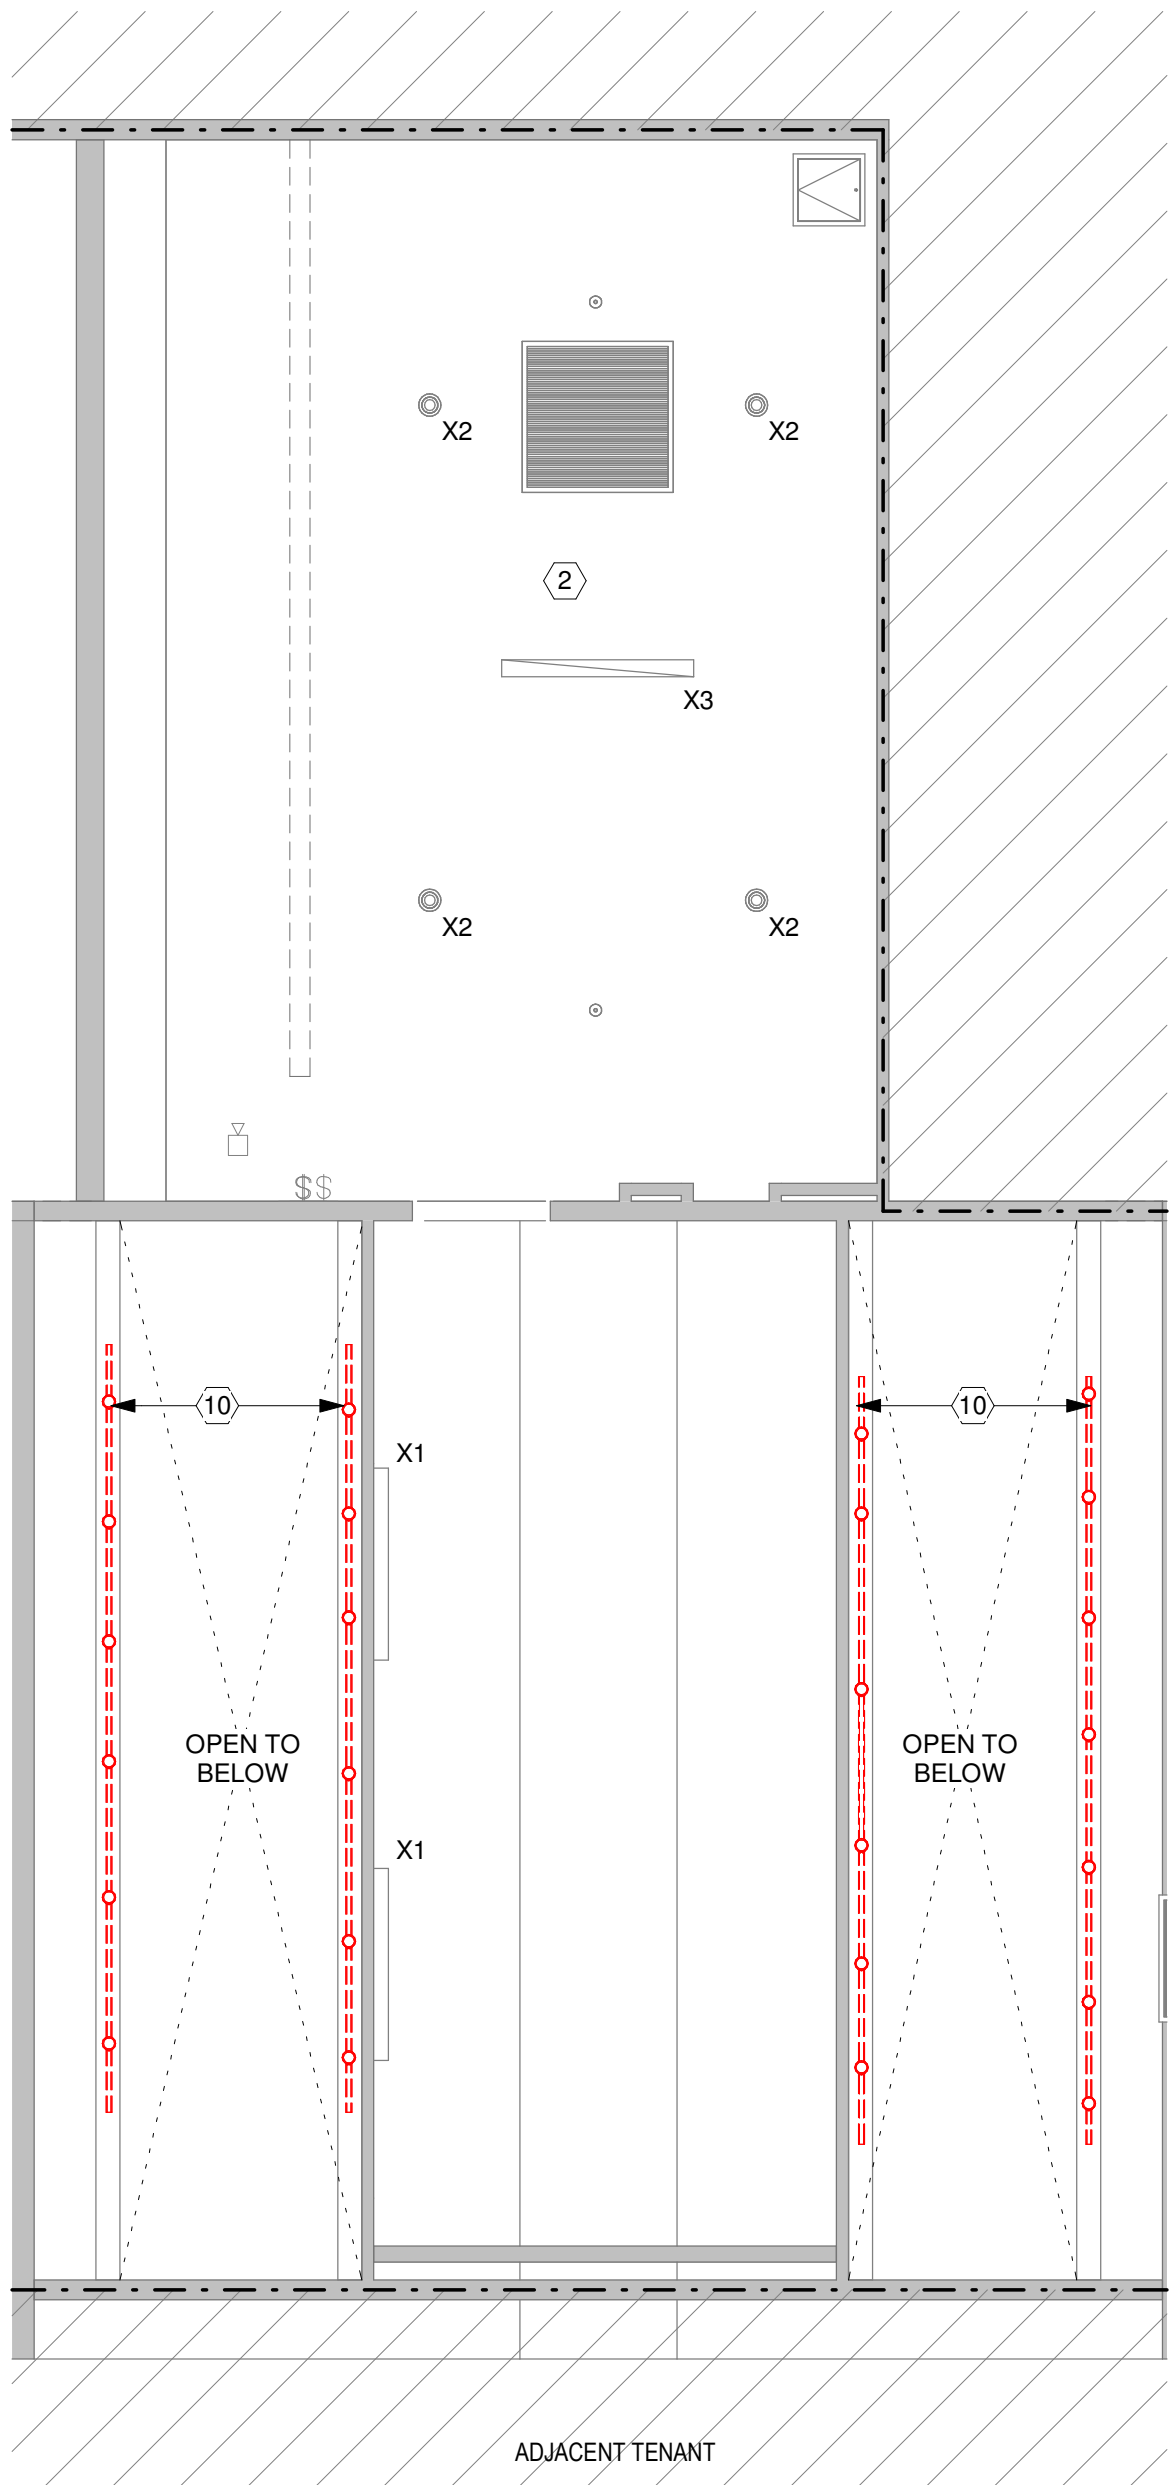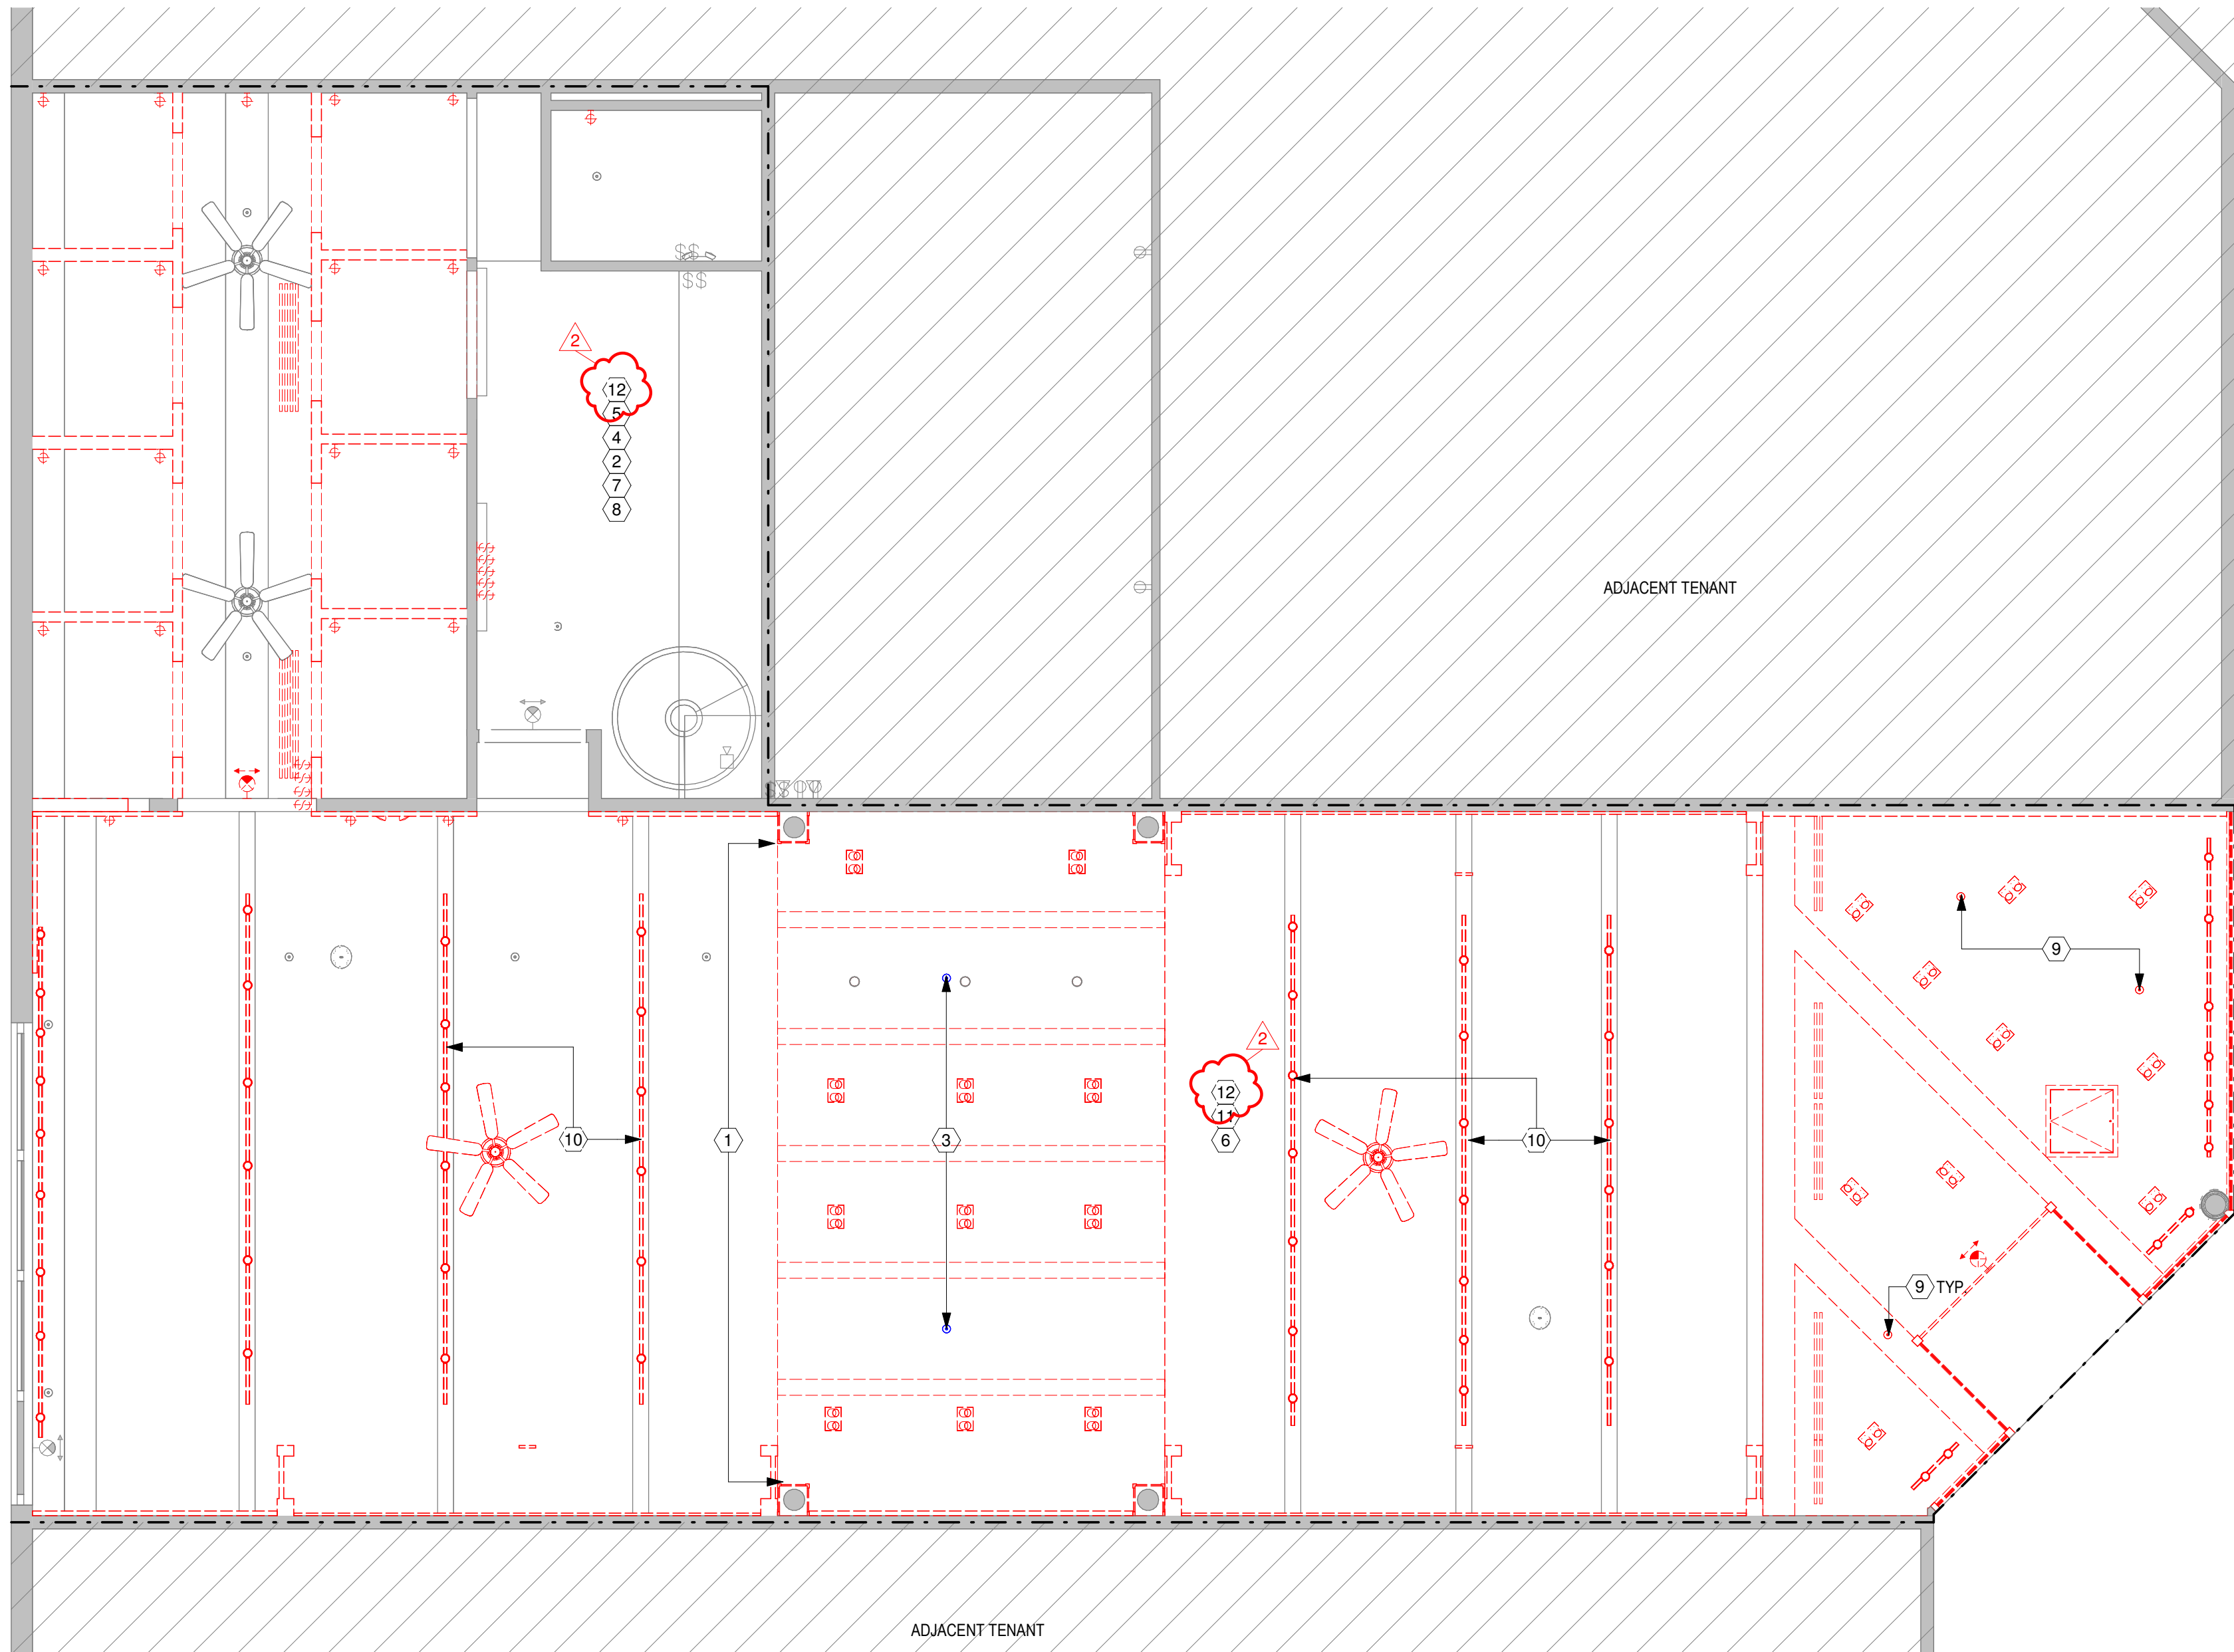

2 MEZZANINE DEMOLITION REFLECTED CEILING PLAN
SCALE: 1/4" = 1'-0"

1 DEMOLITION REFLECTED CEILING PLAN - SALES AREA
SCALE: 1/4" = 1'-0"

LANDLORD BARRICADE NOTES

TENANT CONTRACTOR SHALL PROVIDE A FULL HEIGHT CONTINUOUS DUCT-PROOF BARRIER AT THE STOREFRONT. LANDLORD AT LANDLORD'S DISCRETION, WILL PROVIDE A FULL HEIGHT TEMPORARY FLAT STOREFRONT BARRICADE AT MALL LEASE LINE. GC RESPONSIBLE FOR RELOCATING BARRICADE MAX 3'-0" BEYOND THE LEASE LINE, PROVIDING AND INSTALLING END PANELS TO MATCH A LL APPROVED CONTINUOUS DUSTPROOF BARRIER (FROM BOTTOM OF BARRICADE TO LL BULKHEAD) AND INSTALLING GRAPHICS. GC SHALL NOT DRILL OR OTHERWISE ANCHOR DIRECTLY INTO ENCLOSED MALL FLOOR AND SHALL PROVIDE SUFFICIENT PROTECTION OF THE ENCLOSED MALL FLOOR TO PREVENT ANY DAMAGE DURING STOREFRONT CONSTRUCTION. GC IS RESPONSIBLE FOR REMOVAL AND DISPOSAL OF THE BARRICADE TO A LOCATION DESIGNATED BY LL.

NO DOORS ALLOWED IN BARRICADE - REMOVABLE PANEL ONLY. CONSTRUCTION ACCESS TO SPACE THROUGH REAR SERVICE EXIT ONLY. ACCESS NOT ALLOWED THROUGH THE TEMPORARY STOREFRONT BARRICADES

LANDLORD DEMOLITION NOTES

ANYTHING UNUSED INCLUDING, BUT NOT LIMITED TO ALL ABANDONED AND/OR UNUSED DUCTWORK, PIPING, EQUIPMENT, ELECTRICAL, ETC SHALL BE REMOVED FROM SITE. DO NOT ABANDON ANYTHING IN PLACE.

ALL DEMOLITION AND DEBRIS REMOVAL IS TO TAKE PLACE DURING NON-MALL HOURS.

CONTRACTOR TO HAUL AWAY DEBRIS DAILY THROUGH REAR SERVICE EXIT ONLY.

DURING DEMOLITION, FIRE SPRINKLER SYSTEM MUST BE BLANKED OFF PRIOR TO COMMENCING DEMOLITION.

PROTECT ALL MALL FINISHES FROM DAMAGE FOR DURATION OF PROJECT. REPAIR ANY DAMAGE IN COORDINATION WITH MALL FIELD REP. AS REQUIRED. TYPICAL ALL PIERS AND BULKHEADS (TYPICAL).

IF REMOVAL OF NEUTRAL PIER(S) OR OTHER LL FINISHES IS REQUIRED, COORDINATE WITH LL FIELD REP PRIOR TO BEGINNING WORK.

ALL EXISTING FINISHES TO BE REMOVED BACK TO DEMISING WALLS AND BASE BUILDING STRUCTURE UNLESS OTHERWISE ACCEPTED BY LL.

COORDINATE ALL MEP DEMOLITION AND ANY REQUIRED CORING/TRENCHING WITH LANDLORD FIELD REP. TRENCHING IS NOT PERMITTED FOR TENANTS NOT LOCATED ON GRADE.

REMOVE ALL ABANDONED UTILITY LINES BACK TO MAIN (TYP).

TENANT RESPONSIBLE TO PROVIDE AND MAINTAIN FLOOR PROTECTION OF MALL TILE UNDER BARRICADE THROUGH PROJECT DURATION.

TENANT IS RESPONSIBLE FOR INSTALLING AND MAINTAINING SOUND INSULATION IN BARRICADE THROUGH PROJECT DURATION.

ANY ADJUSTMENTS TO THE WORK ARISING FROM FIELD CONDITIONS NOT APPARENT ON DRAWINGS AND OTHER BUILDING DOCUMENTS SHALL RECEIVE WRITTEN APPROVAL OF LANDLORD PRIOR TO START OF CONSTRUCTION.

TENANT AND GC TO CONFIRM ALL REUSED SYSTEMS, EQUIPMENT, FINISHES, ETC. ARE IN GOOD WORKING ORDER AND MEET ALL CURRENT CODES AND TENANT CRITERIA MANUAL REQUIREMENTS. IT IS THE TENANT'S RESPONSIBILITY TO REPLACE ALL ITEMS DUE TO CURRENT OR FUTURE CONDITIONS AND/OR QUALITY.

DEMOLITION PLAN LEGEND

SYMBOL	DESCRIPTION
	EXISTING TO BE REMOVED. REFER TO KEY NOTES FOR SCOPE.
	EXISTING TO REMAIN
	LEASE LINE
	AREA NOT IN CONTRACT
	DEMO FINISH
	RELOCATED

DEMOLITION PLAN KEY NOTES (#)

- PORTION OF CEILING TO BE DEMOLISHED INCLUDING ALL LOW VOLTAGE DEVICES, LIGHTING, AND DIFFUSERS, ASSOCIATED POWER/WIRING/CABLING (INCLUDING CONDUIT). TIE BACK TO SOURCE. MAINTAIN EXISTING FRAMING.
- EXISTING BOH LIGHTING, FIRE PROTECTION DEVICES, ELECTRICAL DEVICES, AND LOW VOLTAGE TO REMAIN.
- EXISTING SPRINKLER TO BE RELOCATED. SEE RCP FOR RELOCATION INFORMATION. COORDINATE WITH NEW CONSTRUCTION AND FIRE PROTECTION DRAWINGS.
- EXISTING ELECTRICAL, PLUMBING, AND LIGHTING IN STORAGE AREA TO REMAIN U.O.N. PROTECT IN PLACE AS REQUIRED.
- EXISTING SPRINKLER HEADS AND ASSOCIATED PIPING TO REMAIN AND GC TO PROTECT IN PLACE U.O.N. COORDINATE WITH NEW CONSTRUCTION AND FIRE PROTECTION DRAWINGS.
- ALL EXISTING PREVIOUS TENANT ASSOCIATED DUCTWORK TO BE REMOVED THROUGHOUT. GC TO TEMPORARY SEAL-OFF MAIN RETURN AIR AND ANY SHARED ADJACENT TENANT WALL OPENINGS TO PREVENT DEBRIS FROM MIGRATING.
- EXISTING EMERGENCY LIGHTS AND EXIT SIGNS TO REMAIN OR BE REUSED.
- EXISTING ELECTRICAL PANEL, FIRE ALARM POWER SUPPLY, AND LIGHTING PANELS TO REMAIN. PROTECT IN PLACE DURING CONSTRUCTION.
- SPRINKLER HEAD TO BE REMOVED AND ASSOCIATED PIPING TO BE REROUTED AS REQUIRED. REFER TO FIRE PROTECTION DRAWINGS FOR MORE INFORMATION.
- TRACK LIGHTING TO BE REMOVED.
- EXISTING HVAC UNIT AND ASSOCIATED DUCTWORK TO BE REMOVED AND REPLACED. SEE MECHANICAL DRAWINGS FOR MORE INFORMATION INCLUDING GRILLES AND RETURN'S.
- DURING DEMOLITION, FIRE SPRINKLER SYSTEM MUST BE BLANKED OFF PRIOR TO COMMENCING DEMOLITION.

ISSUE FOR BID

SEAL

DRAWINGS ISSUED

No.	Rev	Date	Description
1		06.18.26	LL REVIEW SET
2		06.24.26	ISSUE FOR PERMIT
3		07.02.26	ISSUE FOR BID
5	2	08.27.26	BID ADDENDUM #2

PROJECT NAME:
TWP NAPLES

TWP

PROJECT ADDRESS:
WATERSIDE SHOPS
5455 TAMIAMI TRL N
NAPLES, FL 34108

DRAWING TITLE:
DEMOLITION
REFLECTED CEILING
PLAN

SCALE: AS SHOWN

Project No.	26TWP05
Scale:	1/4" = 1'-0"
Date:	08-20-2026
Drawn By:	212
Checked BY:	212

DRAWING NO:

D-201



45 WEST 21st STREET, SUITE 403
NEW YORK, NY 10010

IN ASSOCIATION WITH THE ARCHITECT:
R H SWEERS II, PROPRIETOR
R H SWEERS ARCHITECT

ALL DRAWINGS AND WRITTEN MATERIAL APPEARING HEREIN
CONSTITUTE ORIGINAL AND UNPUBLISHED WORK OF THE
ARCHITECT AND MAY NOT BE DUPLICATED, USED OR DISCLOSED
WITHOUT WRITTEN
CONSENT OF THE ARCHITECT. THIS DOCUMENT IS INTENDED
SOLELY FOR THE CONSTRUCTION OF THE PROJECT NAMED HEREIN
AND SHALL NOT BE USED BY ANY OTHER CONSTRUCTION WITHOUT
WRITTEN CONSENT OF THE ARCHITECT.
THIS DRAWING WAS PREPARED UNDER MY SUPERVISION AND I
DISCLAIM ANY RESPONSIBILITY FOR THE EXISTING BUILDING
CONSTRUCTION ELEMENTS, SITE CONDITIONS, OR ANY DOCUMENTS
WHICH DO NOT BEAR MY SEAL.

SEAL

ISSUE FOR BID

DRAWINGS ISSUED

No.	Rev	Date	Description
1		06.18.26	LL REVIEW SET
2		06.24.26	ISSUE FOR PERMIT
3		07.02.26	ISSUE FOR BID
5	2	08.27.26	BID ADDENDUM #2

PROJECT NAME:

TWP NAPLES

TWP

PROJECT ADDRESS:

WATERSIDE SHOPS
5455 TAMIAMI TRL N
NAPLES, FL 34108

DRAWING TITLE:

CONSTRUCTION PLAN

SCALE: AS SHOWN

Project No. 26TWP05

Scale: 1/4" = 1'-0"



Date: 08-20-2026

Drawn By: 212

Checked By: 212

DRAWING NO:

A-101

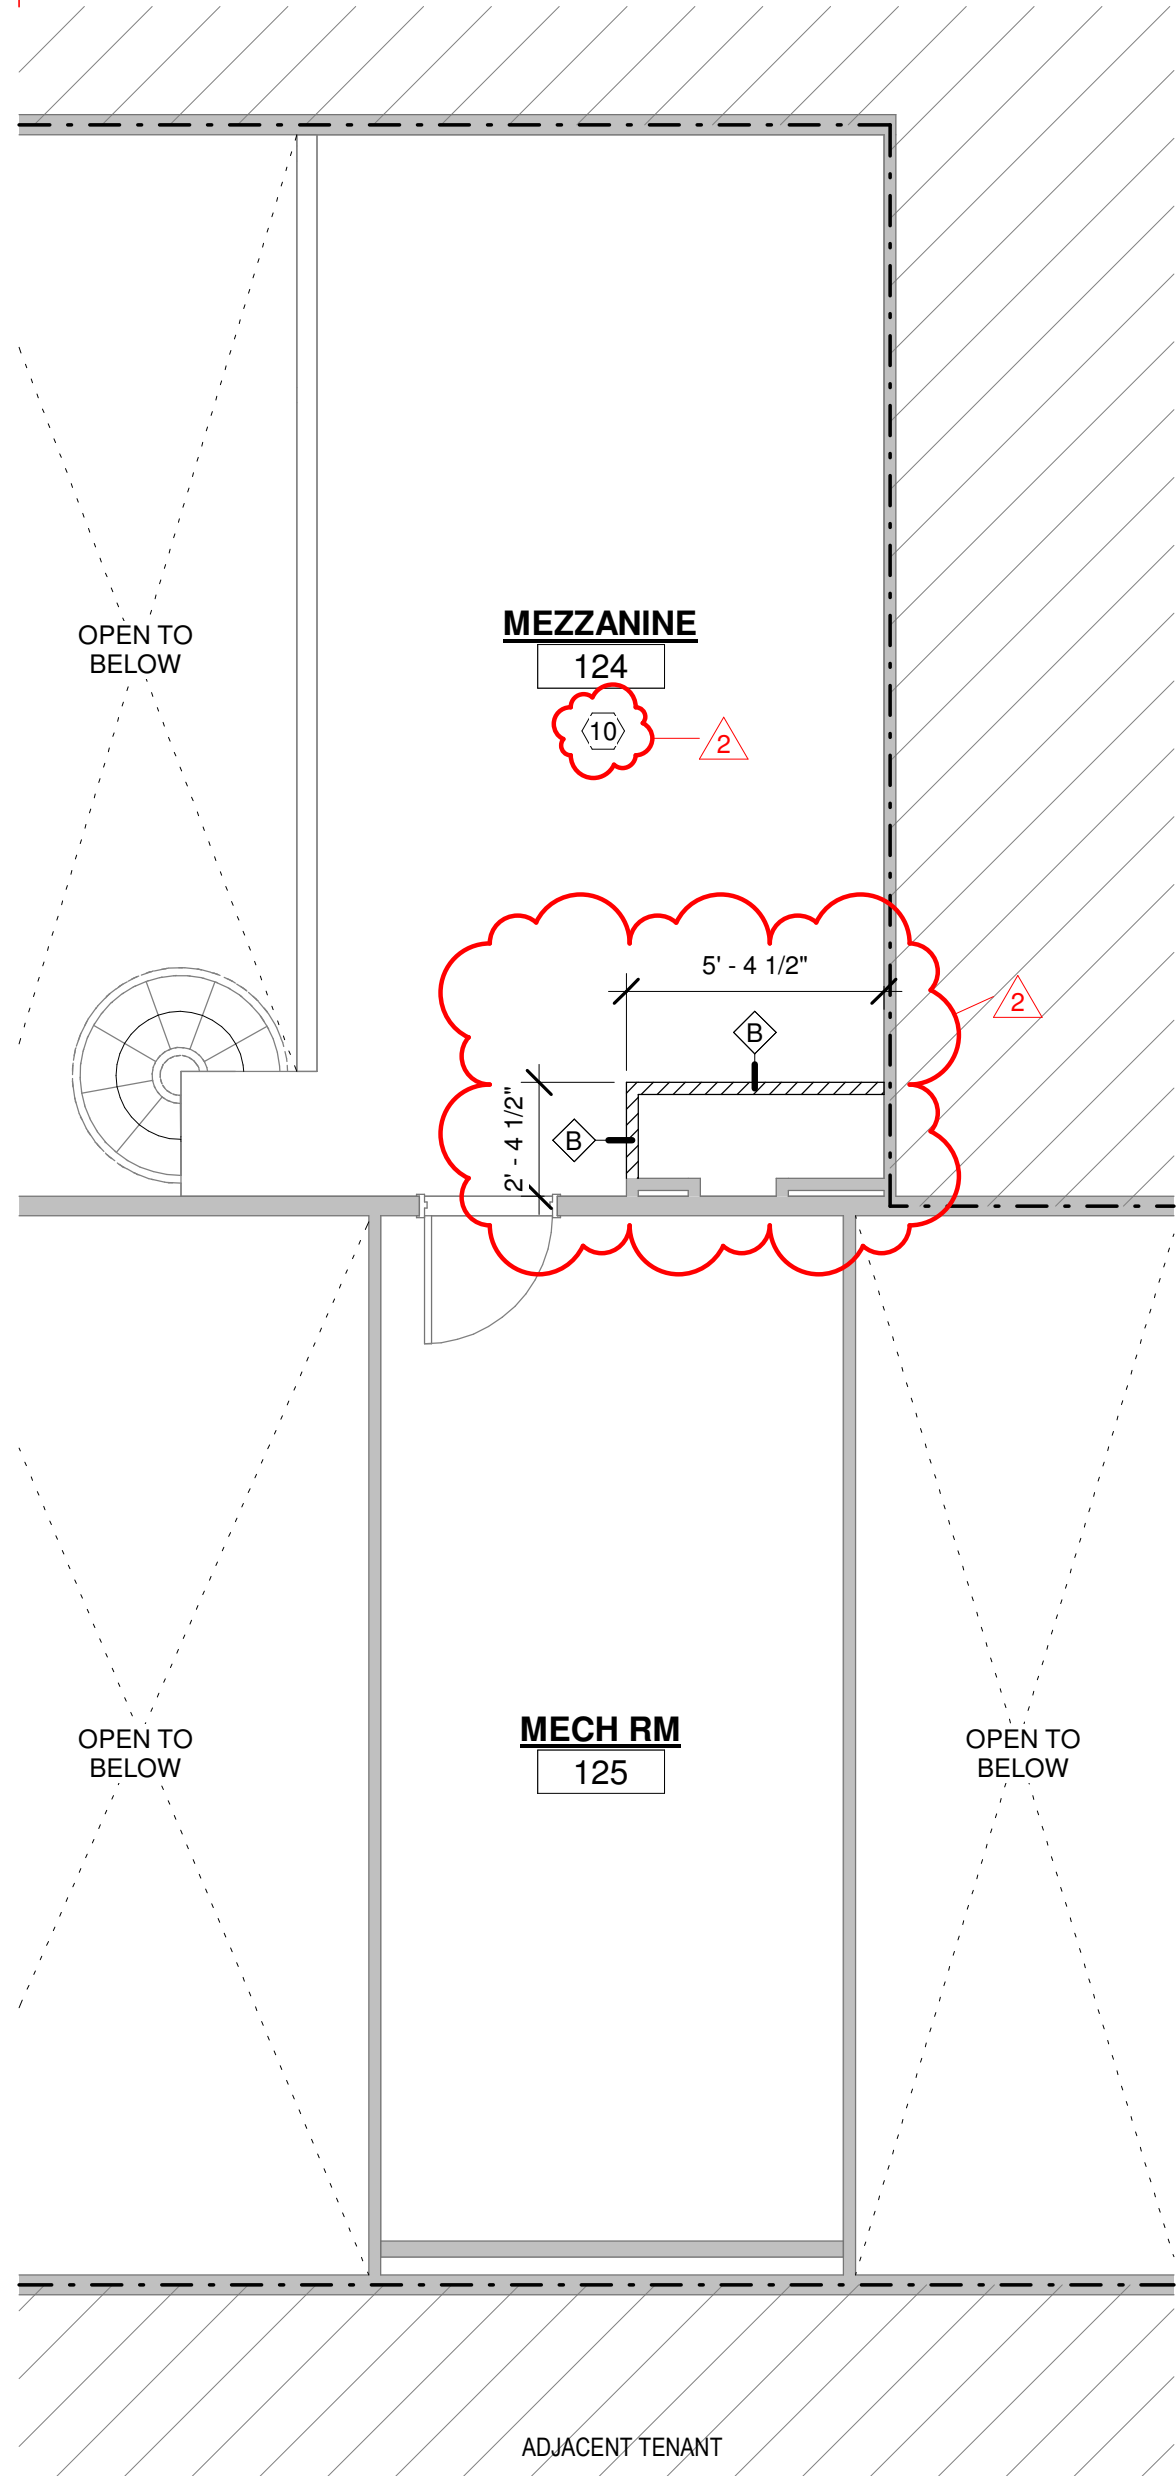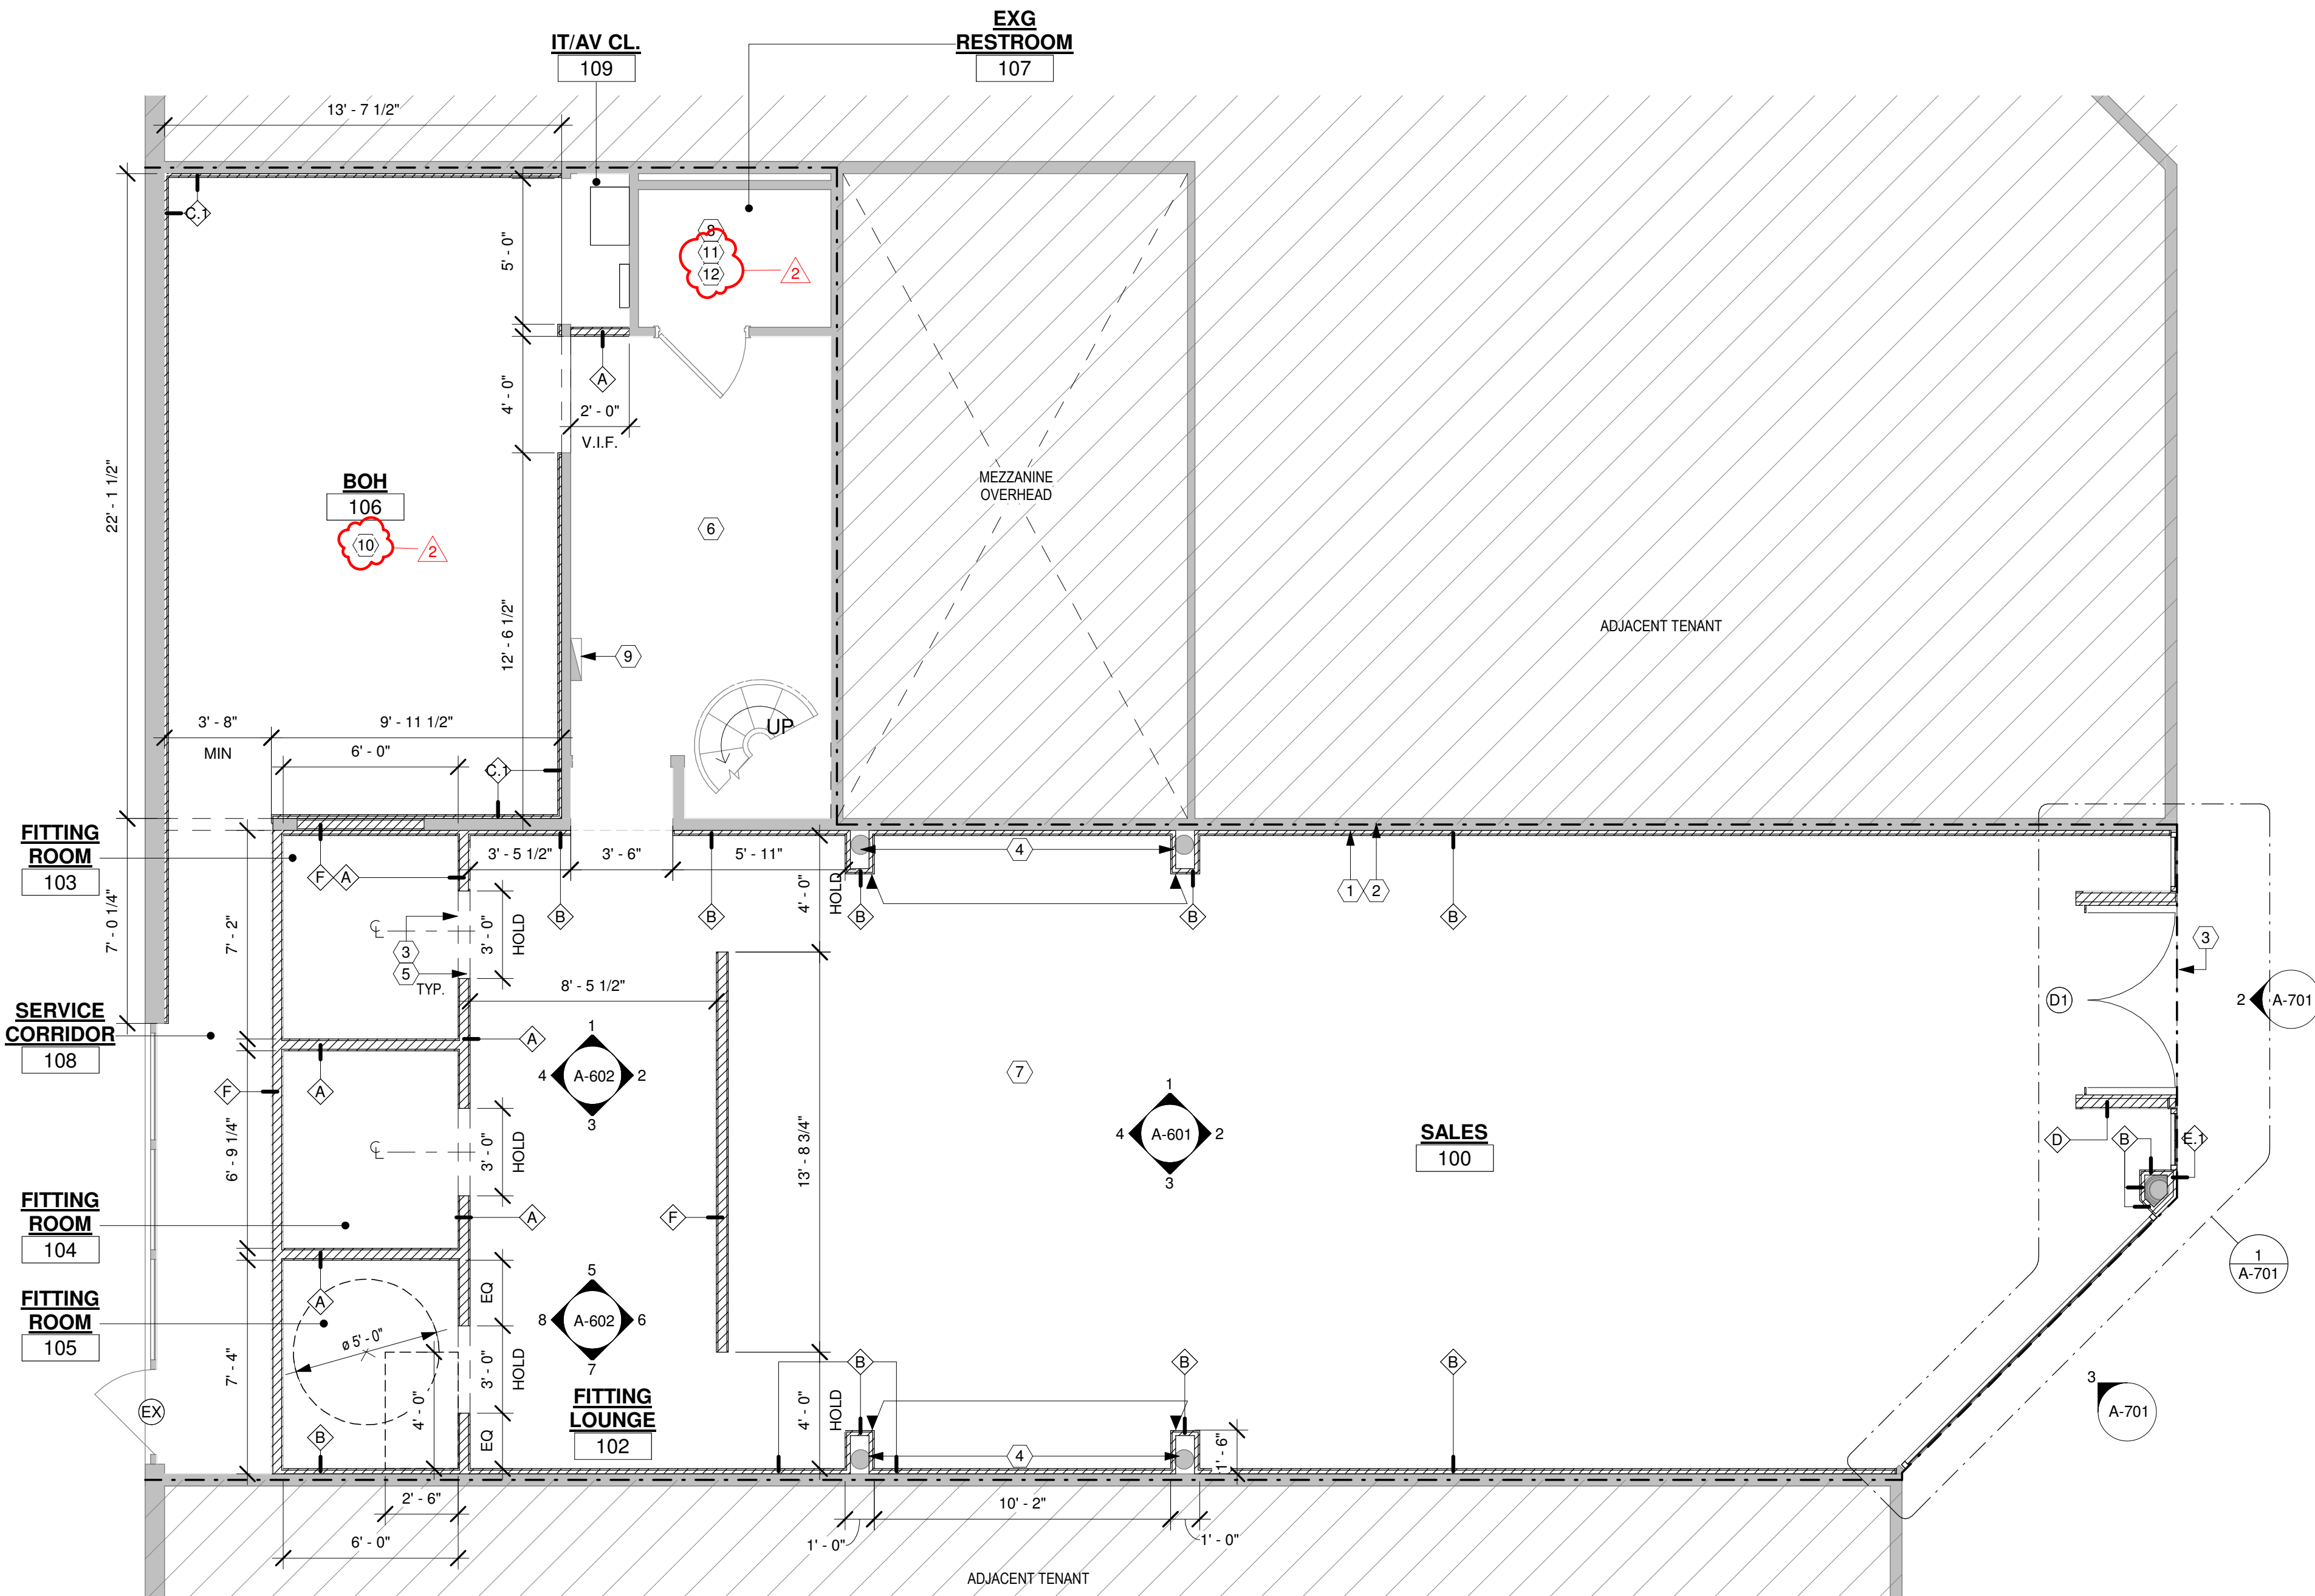

2

MEZZANINE
SCALE: 1/4" = 1'-0"

1

CONSTRUCTION PLAN
SCALE: 1/4" = 1'-0"

FIRE ALARM NOTES

DURING DEMOLITION, FIRE SPRINKLER SYSTEM MUST BE BLANKED OFF PRIOR TO COMMENCING DEMOLITION.
SMOKE DETECTOR SHALL BE CONNECTED TO LANDLORD'S ANNUNCIATOR PANEL BY TENANT ON A SEPARATE FIRE ALARM ZONE AND SEPARATE TROUBLE ZONE.
TENANT TO PROVIDE FIRE ALARM SYSTEM INCLUDING AUTOMATIC SENSORS AND DETECTORS, HORNS, STROBES, BACKUP BATTERIES, ETC TO BE TIED INTO LL BAS SYSTEM WITH LANDLORD SPECIFIED EQUIPMENT ONLY. SPRINKLER SYSTEM TO CONNECT TO THE SPRINKLER SYSTEM FLANGE STUB PROVIDED BY LANDLORD.
UPON ACTIVATION OF LANDLORD'S FIRE SYSTEM, TENANT'S CONTRACTOR SHALL NOTIFY LANDLORD'S REPRESENTATIVE AT SUCH TIME AS FINAL SPRINKLER CONNECTION TO THE MALL SYSTEM IS READY TO BE MADE. ONLY LANDLORD'S SPRINKLER CONTRACTOR SHALL DRAIN THE MALL SYSTEM AND ONLY DURING NONBUSINESS HOURS. ONCE THE SYSTEM IS DRAINED, TENANT'S CONTRACTOR SHALL MAKE THE FINAL CONNECTION AND REMAIN IN THE PREMISES WHILE THE MALL CONTRACTOR FILLS THE SYSTEM TO REPAIR ANY LEAKS.

CONSTRUCTION PLAN LEGEND

SYMBOL	DESCRIPTION
	NEW FULL HEIGHT (OR UP TO CEILING) PARTITION. REFER TO PARTITION TYPES FOR MORE INFORMATION
	NEW PARTIAL HEIGHT PARTITION. REFER TO PARTITION TYPES FOR MORE INFORMATION
	EXISTING TO REMAIN
	LEASE LINE
	INDICATES ADJACENT TENANT SPACE - AREAS NOT IN CONTRACT
	INDICATES TENANT AREA WITH NO NEW WORK SCOPE
	ALIGN AS INDICATED
ROOM NAME ####	ROOM NAME AND NUMBER
	DOOR/FINISHED OPENING NUMBER

CONSTRUCTION PLAN GENERAL NOTES

STOREFRONT GLASS MUST BE TEMPERED AND/OR LAMINATED WITH POLISHED/HONED CORNERS, TYP.
GLASS JOINTS CAN BE NO LARGER THAN 1/4" THICK - SILICONE IS NOT ACCEPTABLE, TYP.
IN SENSORMATIC OR ANY KIND OF ANTITHEFT DETECTION EQUIPMENT IS DESIRED BY TENANT, EVERY COMPONENT OF THE SYSTEM IS REQUIRED TO BE COMPLETELY CONCEALED FROM SALES AREA, TYP.
ALL WOOD BLOCKING MUST BE FIRE TREATED, TYP.
ANY AND ALL FIRE EXTINGUISHERS IN SALES AREA WHETHER OR NOT REQUIRED BY ANY CODE MUST BE CONCEALED IN RECESSED CABINET.
RESTROOMS AND ANY WET AREAS WITHIN TENANT SPACE ARE REQUIRED TO HAVE WATERPROOFING OVER FLOOR AND MIN. 4" ON ALL BOUNDING WALLS, TYP. - REVIEW WITH AND COORDINATE WITH LL FIELD REP. FOR WATER TEST.
TENANT MUST HAVE AT LEAST ONE 44" MINIMUM WIDTH PATH OF EGRESS FROM STOREFRONT TO BACK CORRIDOR. ALL OTHER PATHWAYS MUST BE MINIMUM 36" WIDE.
IT IS TENANT'S RESPONSIBILITY TO ENSURE THAT FIRE RATING IS MAINTAINED AS REQUIRED, TYP.
ALL COMPONENTS OF STOREFRONT MUST BE BEHIND THE LEASELINE, TYP.

CONSTRUCTION PLAN KEY NOTES (#)

- PATCH AND REPAIR EXISTING GYPSUM DEMISING WALL TO REMAIN (VISIBLE AREAS), BRING TO LIKE NEW CONDITION AND PREP FOR NEW WALL FINISH OR ATTACHMENTS AS REQUIRED.
- INDICATES LEASE LINE.
- DASHED LINE INDICATES NEW HEADER ABOVE, TYPICAL.
- EXISTING STRUCTURAL COLUMN TO REMAIN. PROTECT DURING ALL PHASES OF CONSTRUCTION.
- REFER TO FINISH SCHEDULE FOR CURTAIN FINISHES - CURTAIN TO BE PROVIDED BY MILLWORKER, TRACK PROVIDED AND INSTALLED BY GC.
- BOH CASHWRAP EQUIPMENT TO BE PROVIDED BY OWNER. EXISTING DESK AREA TO REMAIN.
- GC TO PREPARE EXISTING SLAB FOR NEW TENANT FLOORING, REFER TO FLOOR FINISH PLAN.
- EXISTING RESTROOM PLUMBING FIXTURES AND RESTROOM ACCESSORIES TO REMAIN, GC TO ENSURE PROPER WORKING FUNCTION, INCLUDING HOT WATER HEATER. ALL DRAINS, LINES, PIPES, ETC. SHALL BE SNAKED/CLEANED AT TIME OF REMODEL. GC TO VERIFY WITH THE MALL FACILITIES TEAM THE CONDITION OF THE EXISTING WATERPROOFING.
- EXISTING ELECTRICAL PANEL TO REMAIN.
- AT OPEN CEILING AREA, PERIMETER WALLS MUST EXTEND TO THE DECK AND RETURN AIR TO BE DUCTED. OTHERWISE, CEILING IS REQUIRED.
- MODIFICATIONS TO EXISTING WET AREAS ARE THE RESPONSIBILITY OF CONTRACTOR. EXISTING WATERPROOF MEMBRANE MUST BE WATER TESTED, INSPECTED, AND SIGNED OFF BY MALL PERSONNEL. IF THE MEMBRANE FAILS THE WATER TEST IT MUST BE REPLACED. WATERPROOFING TO BE OVER UNDERLYING FLOOR AND MIN. 6" UP ALL BOUNDING WALLS.
- CLEAN AND CAMERA ALL SANITARY LINES A MINIMUM OF 75' FROM THE RESTROOM DRAIN/TOILET/CLEAN OUT TOWARDS THE MAIN AT THE CONCLUSION OF CONSTRUCTION PROCESS. PROVIDE THE TIME STAMPED VIDEO PROOF VIA ATTACHMENT OR LINK TO LANDLORD REPRESENTATIVE FOR RECORD.



45 WEST 21st STREET, SUITE 403
NEW YORK, NY 10010

IN ASSOCIATION WITH THE ARCHITECT:
R H SWEERS II, PROPRIETOR
R H SWEERS ARCHITECT

ALL DRAWINGS AND WRITTEN MATERIAL APPEARING HEREIN
CONSTITUTE ORIGINAL AND UNPUBLISHED WORK OF THE
ARCHITECT AND MAY NOT BE DUPLICATED, USED OR DISCLOSED
WITHOUT WRITTEN
CONSENT OF THE ARCHITECT. THIS DOCUMENT IS INTENDED
SOLELY FOR THE CONSTRUCTION OF THE PROJECT NAMED HEREIN
AND SHALL NOT BE USED BY ANY OTHER CONSTRUCTION WITHOUT
WRITTEN CONSENT OF THE ARCHITECT.

THIS DRAWING WAS PREPARED UNDER MY SUPERVISION AND I
DISCLAIM ANY RESPONSIBILITY FOR THE EXISTING BUILDING
CONSTRUCTION ELEMENTS, SITE CONDITIONS, OR ANY DOCUMENTS
WHICH DO NOT BEAR MY SEAL.

SEAL

ISSUE FOR BID

DRAWINGS ISSUED

No.	Rev	Date	Description
1		06.18.26	LL REVIEW SET
2		06.24.26	ISSUE FOR PERMIT
3		07.02.26	ISSUE FOR BID
5	2	08.27.26	BID ADDENDUM #2

PROJECT NAME:

TWP NAPLES

TWP

PROJECT ADDRESS:

WATERSIDE SHOPS
5455 TAMIAMI TRL N
NAPLES, FL 34108

DRAWING TITLE:


TYPICAL FRAMING
DETAILS

SCALE: AS SHOWN

Project No.	26TWP05
Scale:	As indicated
Date:	08-20-2026
Drawn By:	212
Checked By:	212


DRAWING NO:

A-120

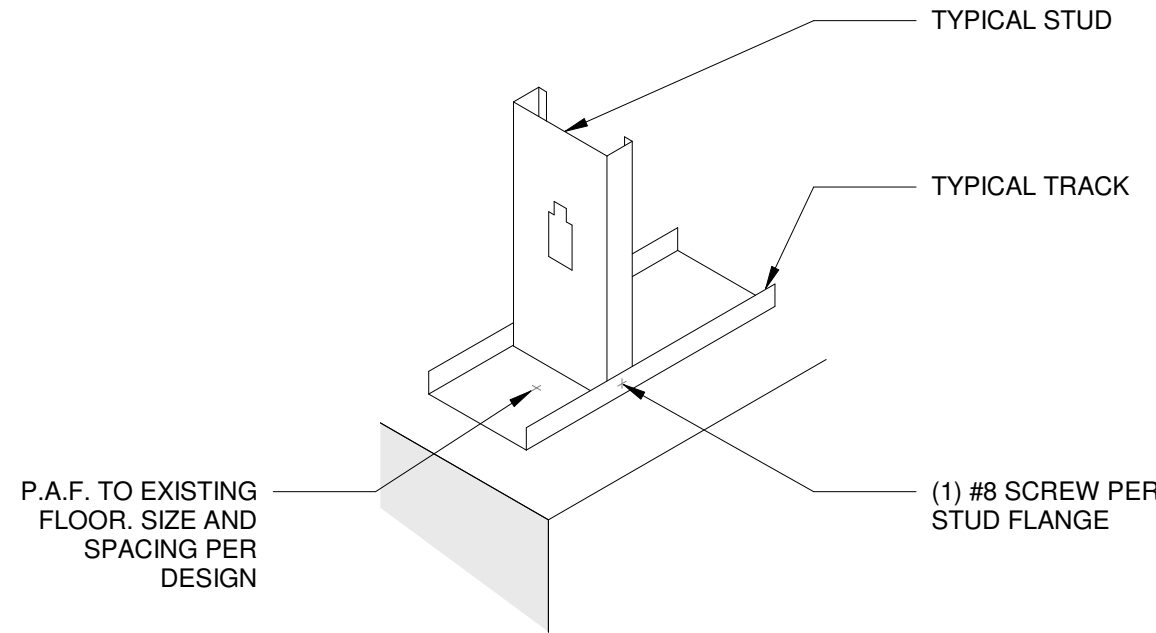


6 STUD BASE DETAIL

SCALE: 3/4" = 1'-0"

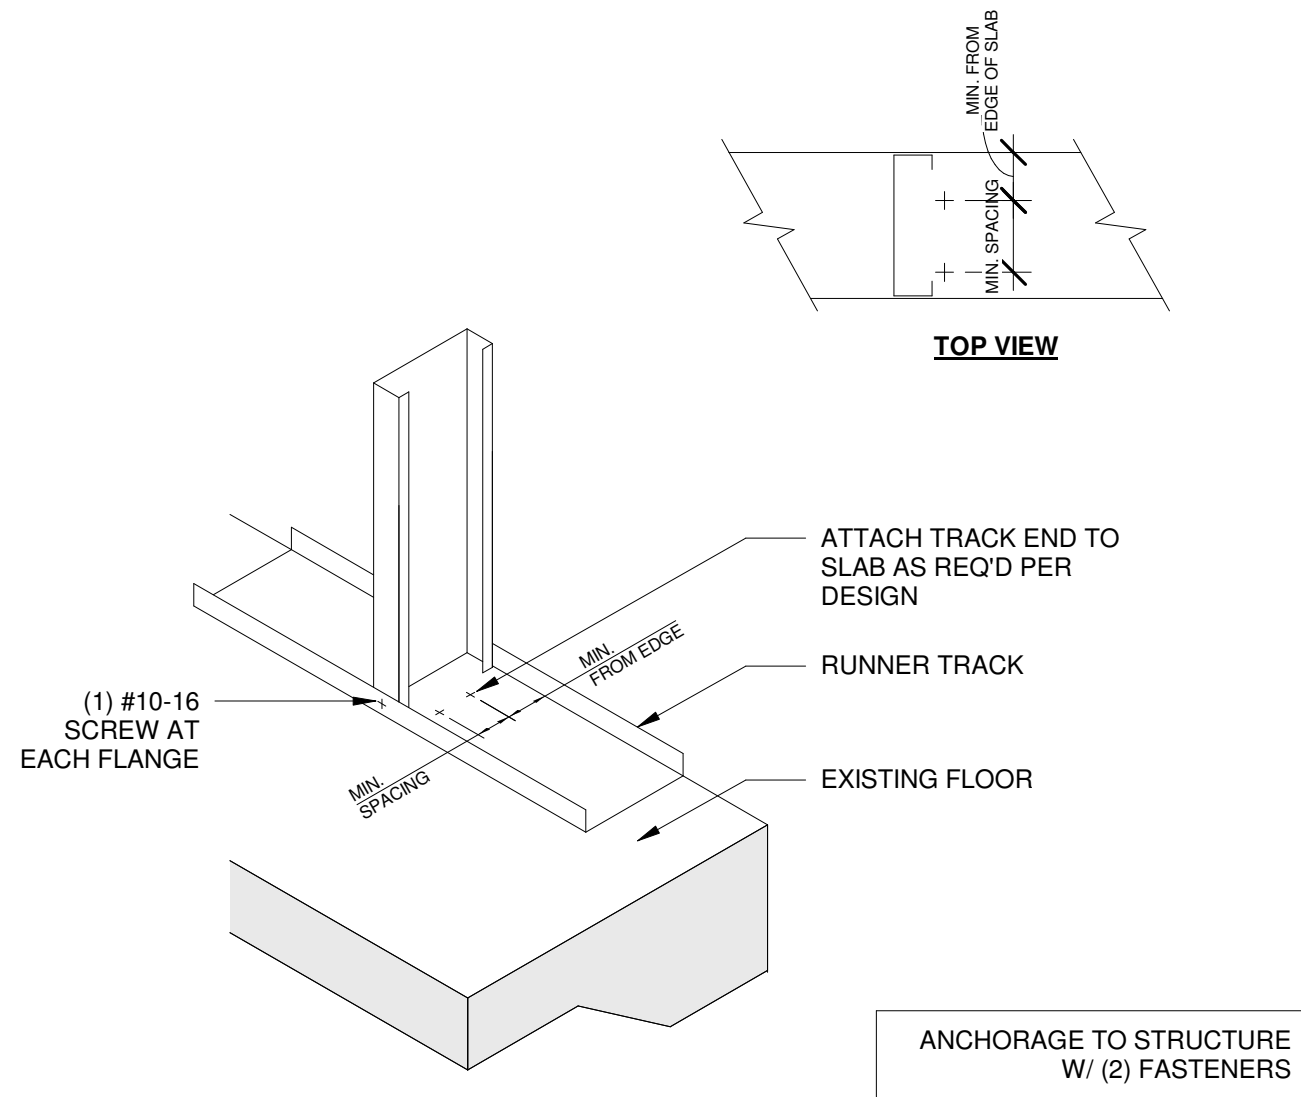


3 STUD TO TRACK DETAIL

SCALE: 3/4" = 1'-0"

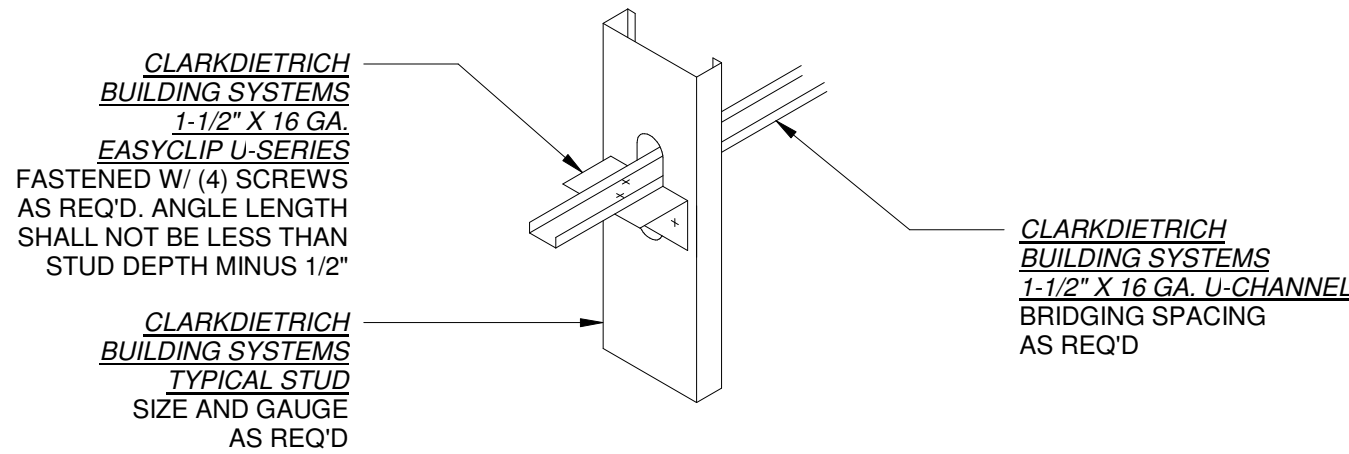


5 U-CHANNEL BRIDGING CONNECTION

SCALE: 3/4" = 1'-0"

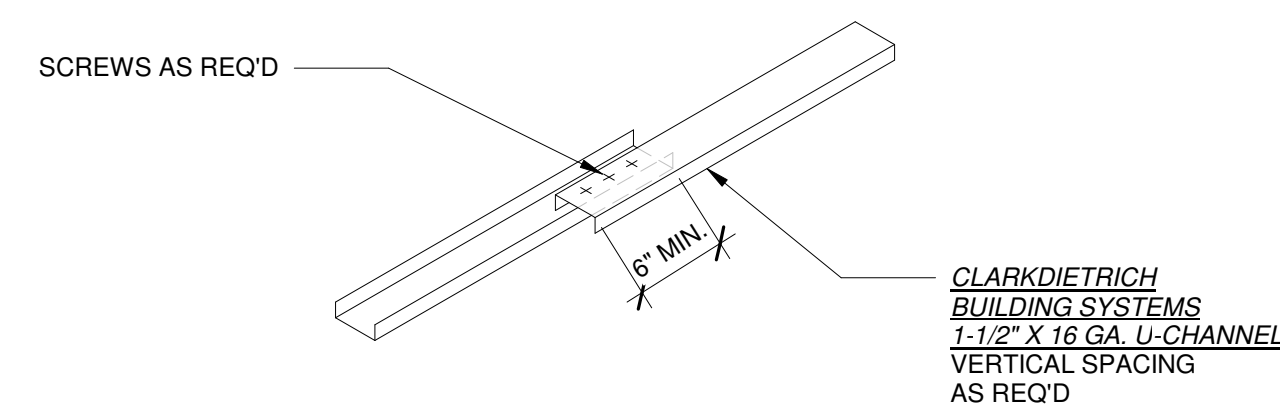


2 U-CHANNEL SPLICE DETAIL

SCALE: 3/4" = 1'-0"

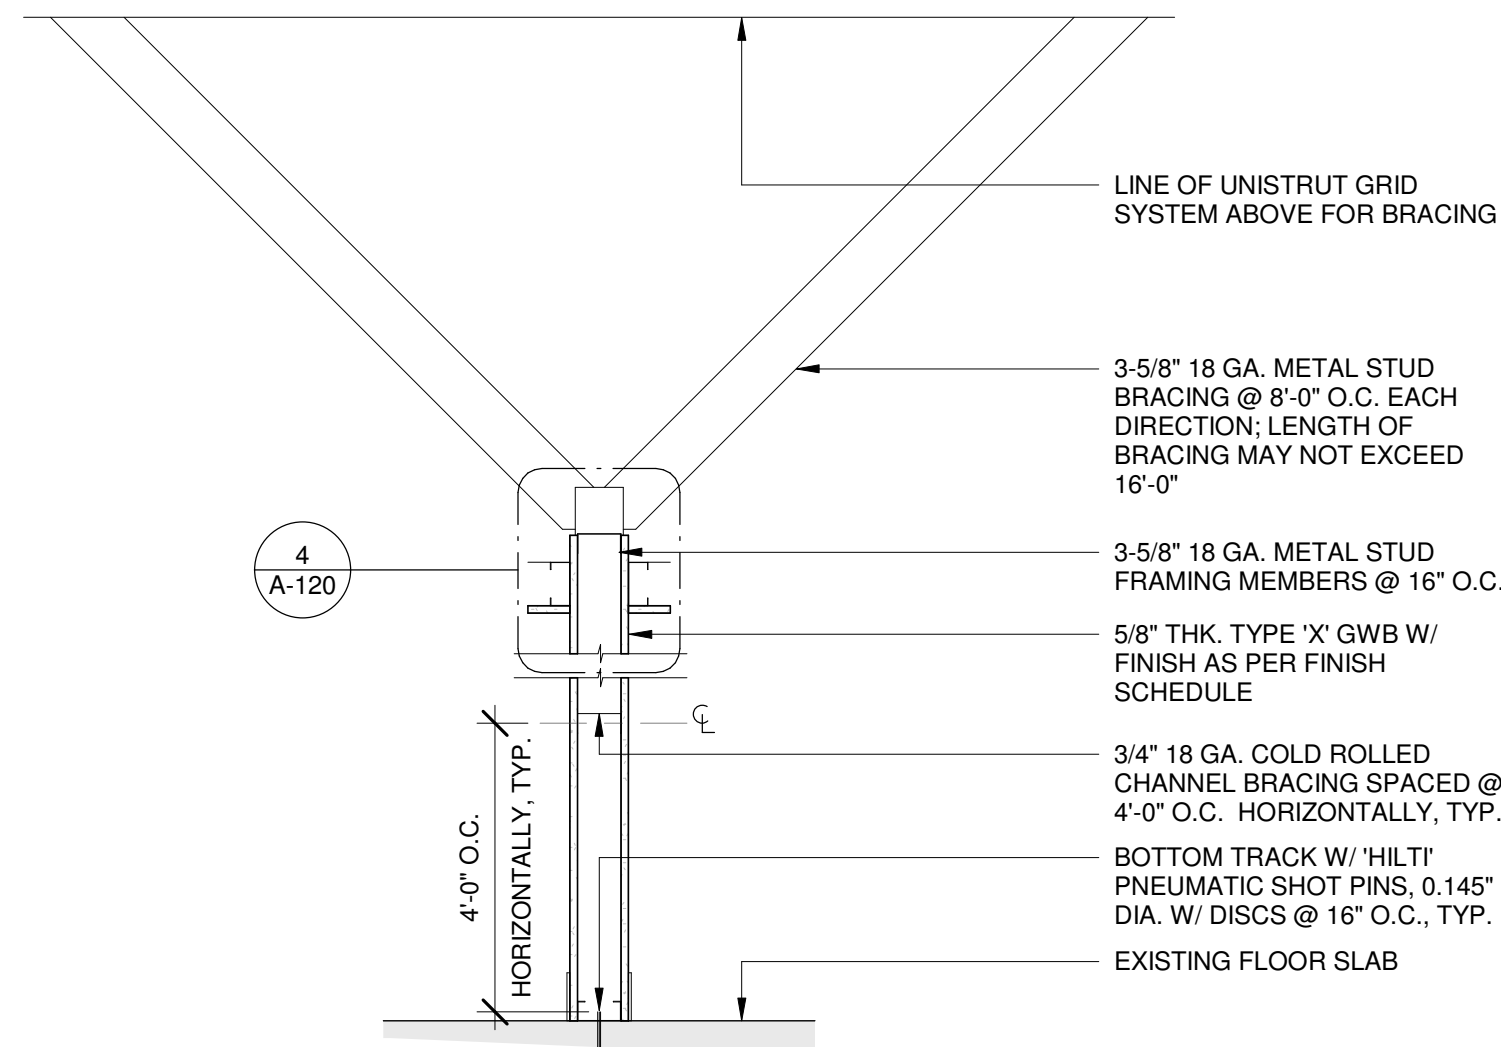


7 WALL PARTITION METAL BRACING DETAIL


SCALE: 1/4" = 1'-0"

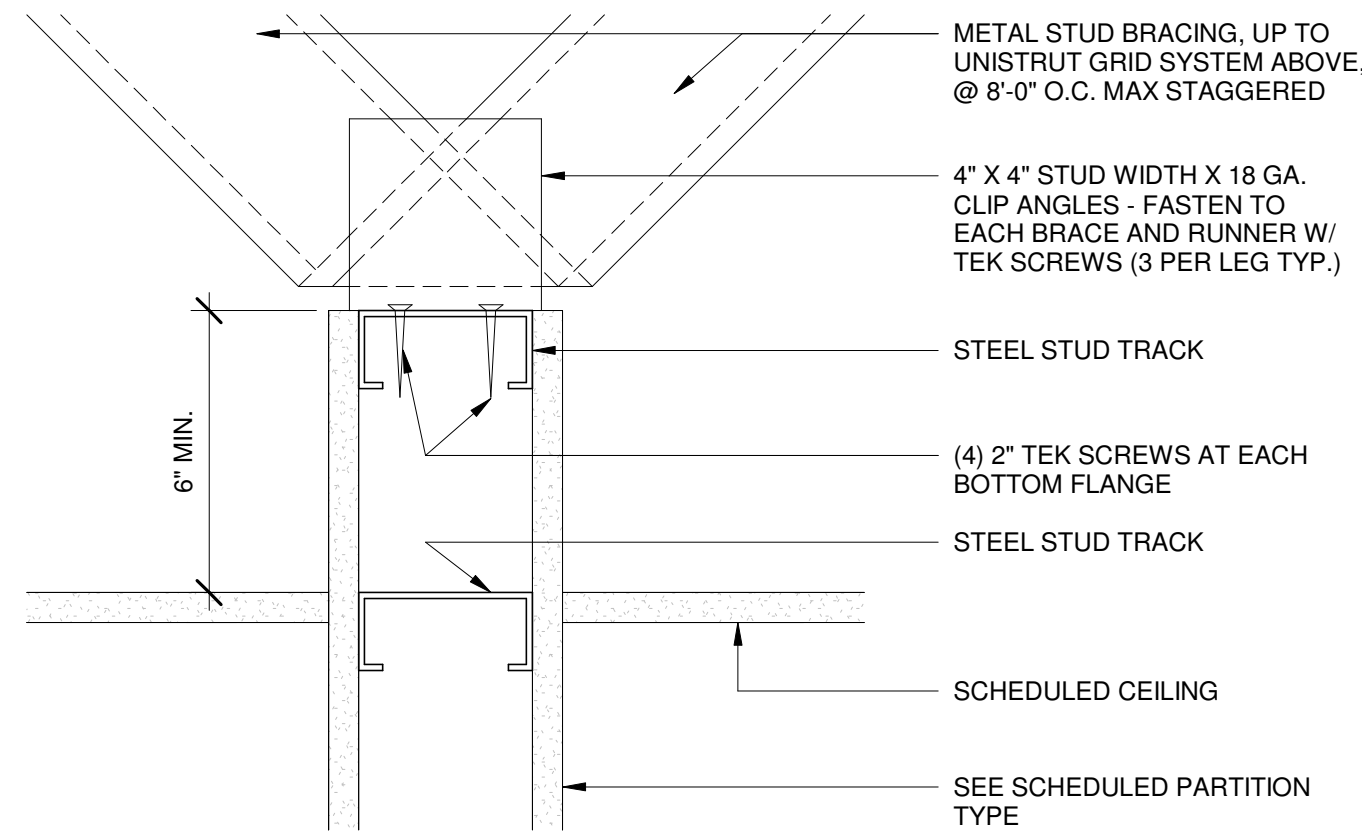

4 WALL BRACING CONNECTION

 SCALE: 1/4" = 1'-0"

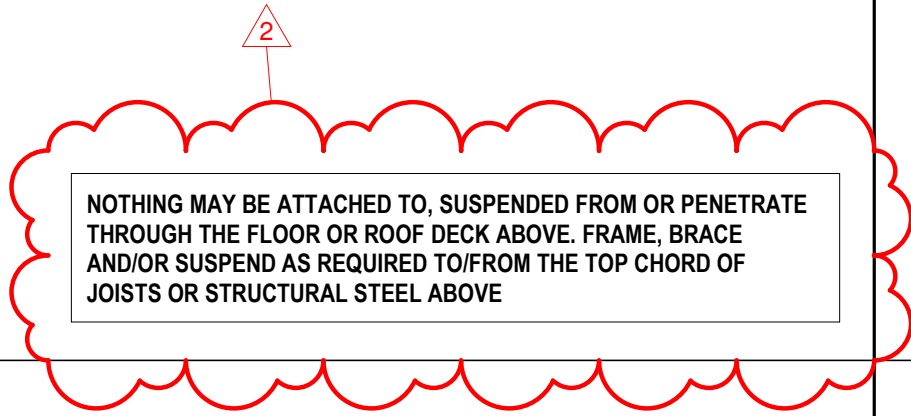



ALL DRAWINGS AND WRITTEN MATERIAL APPEARING HEREIN
CONSTITUTE ORIGINAL AND UNPUBLISHED WORK OF THE
ARCHITECT AND MAY NOT BE DUPLICATED, USED OR DISCLOSED
WITHOUT WRITTEN
CONSENT OF THE ARCHITECT. THIS DOCUMENT IS INTENDED
SOLELY FOR THE CONSTRUCTION OF THE PROJECT NAMED HEREIN
AND SHALL NOT BE USED BY ANY OTHER CONSTRUCTION WITHOUT
WRITTEN CONSENT OF THE ARCHITECT.

THIS DRAWING WAS PREPARED UNDER MY SUPERVISION AND I
DISCLAIM ANY RESPONSIBILITY FOR THE EXISTING BUILDING
CONSTRUCTION ELEMENTS, SITE CONDITIONS, OR ANY DOCUMENTS
WHICH DO NOT BEAR MY SEAL.

SEAL

ISSUE FOR BID

DRAWINGS ISSUED			
No.	Rev	Date	Description
1		06.18.26	LL REVIEW SET
2		06.24.26	ISSUE FOR PERMIT
3		07.02.26	ISSUE FOR BID




TWP

DRAWING TITLE:
TYPICAL FRAMING
DETAILS

SCALE: AS SHOWN

Project No.	26TWP05
Scale:	3/4" = 1'-0"
Date:	08-20-2026
Drawn By:	212
Checked BY:	212
DRAWING NO:	

A-121

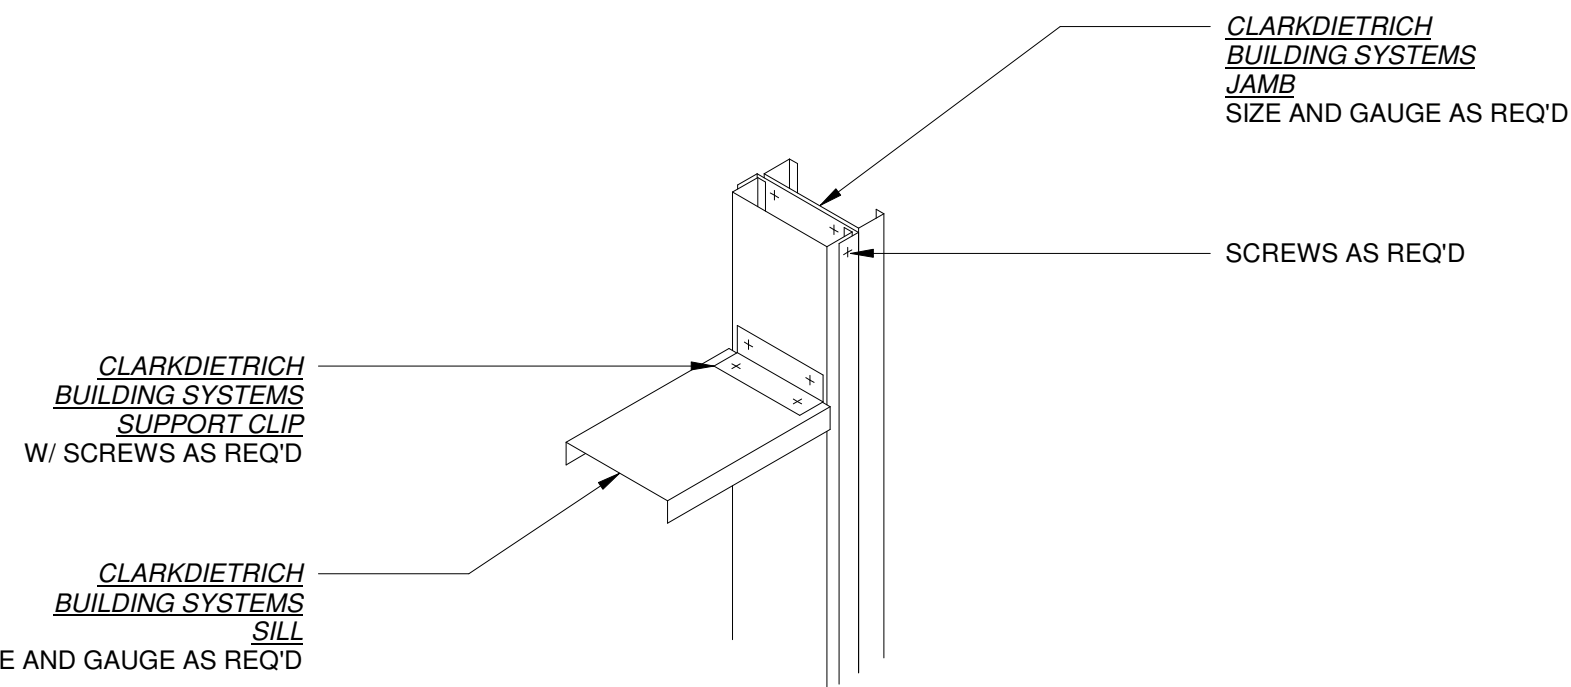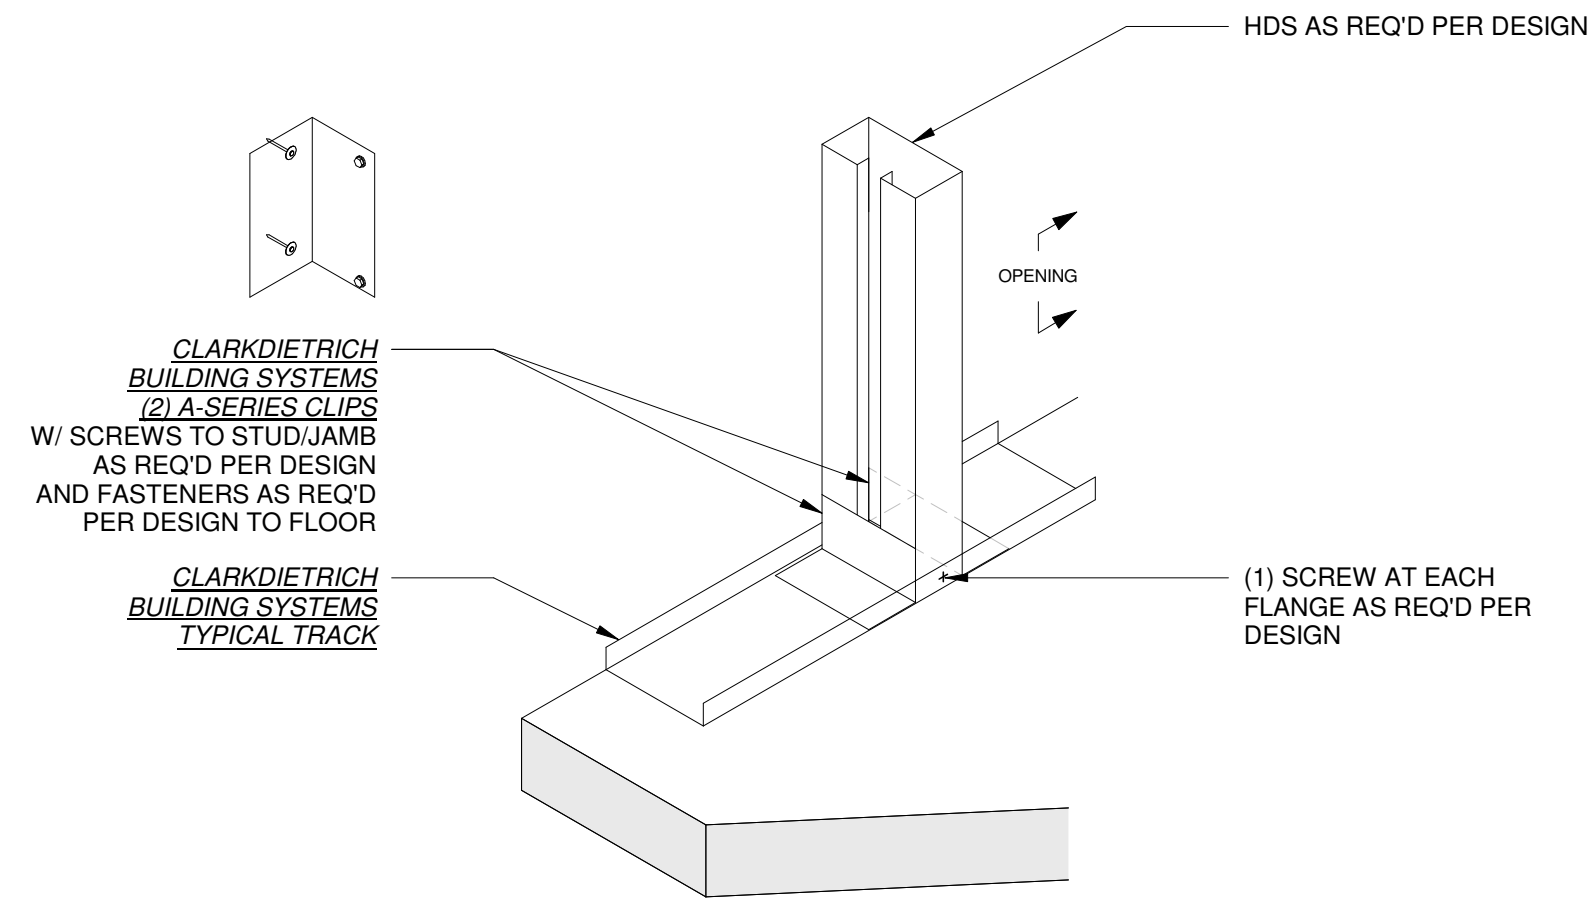
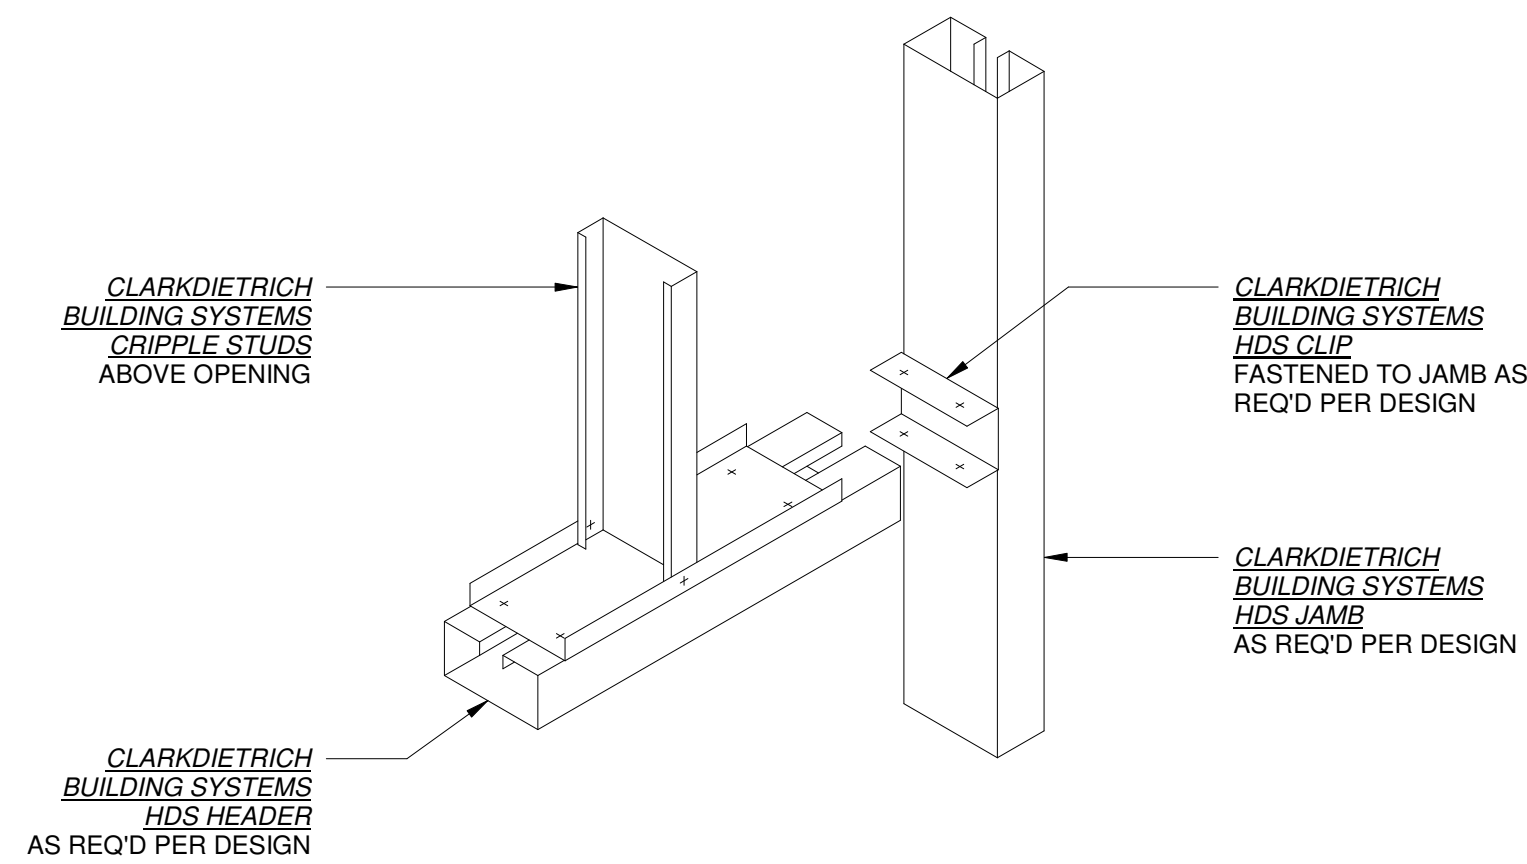


PROVIDE FIRE-RATED BLOCKING IN
HEADER FOR CONCEALED DOOR CLOSER


9 SILL DETAIL
SCALE: 3/4" = 1'-0"

6 CLIPS AT BASE OF HDS STUD / JAMB
SCALE: 3/4" = 1'-0"

3 HDS HEADER CONNECTION TO JAMB

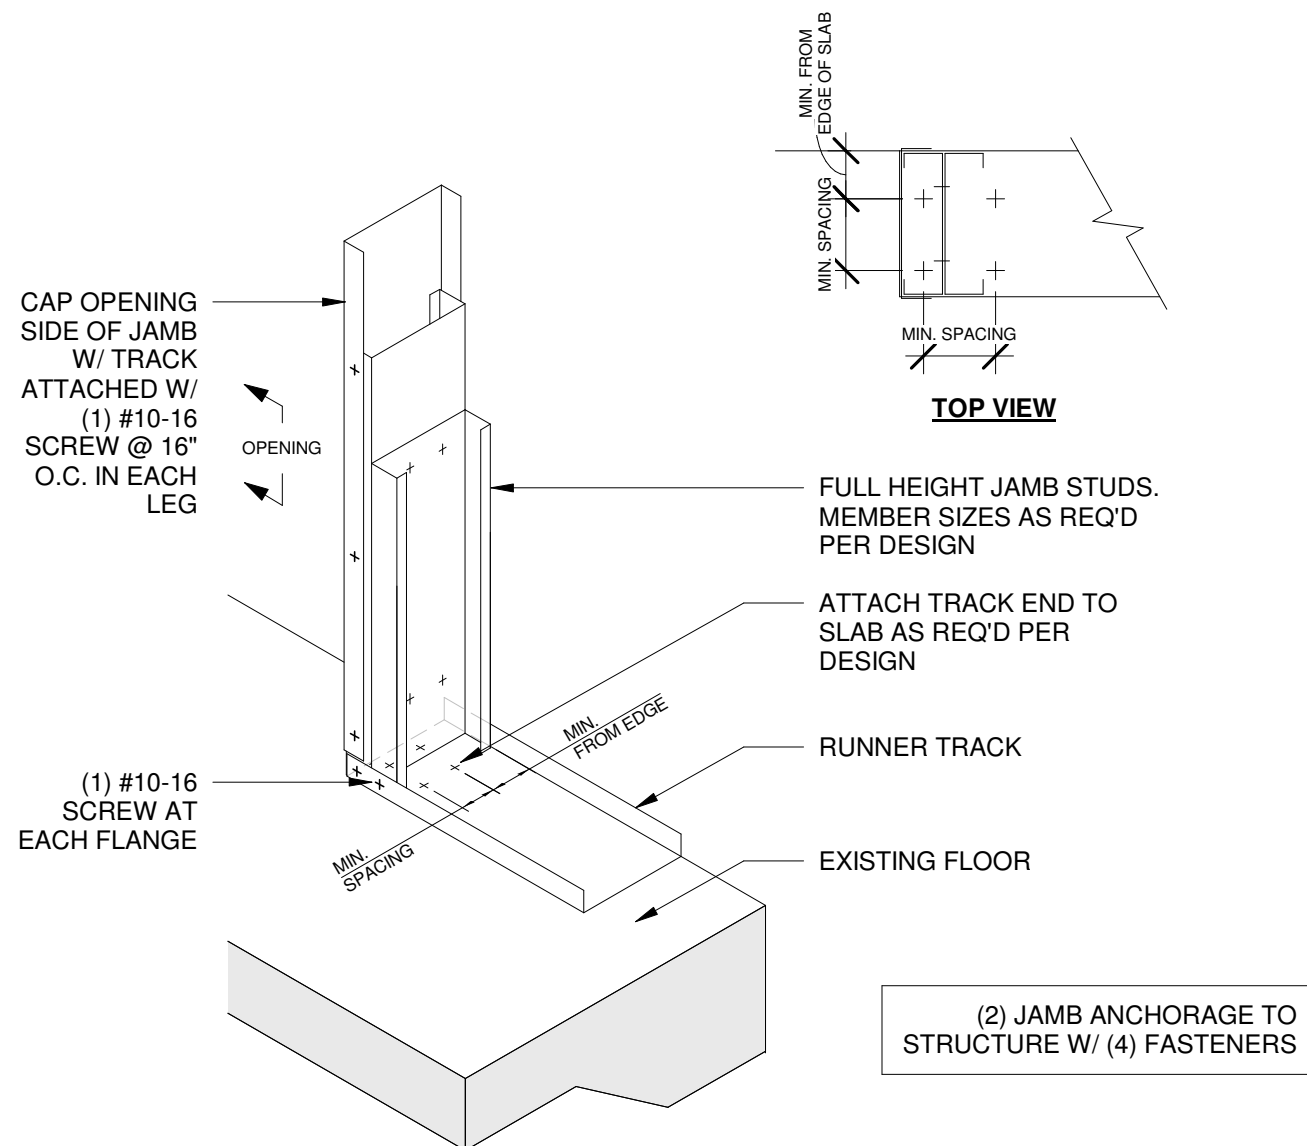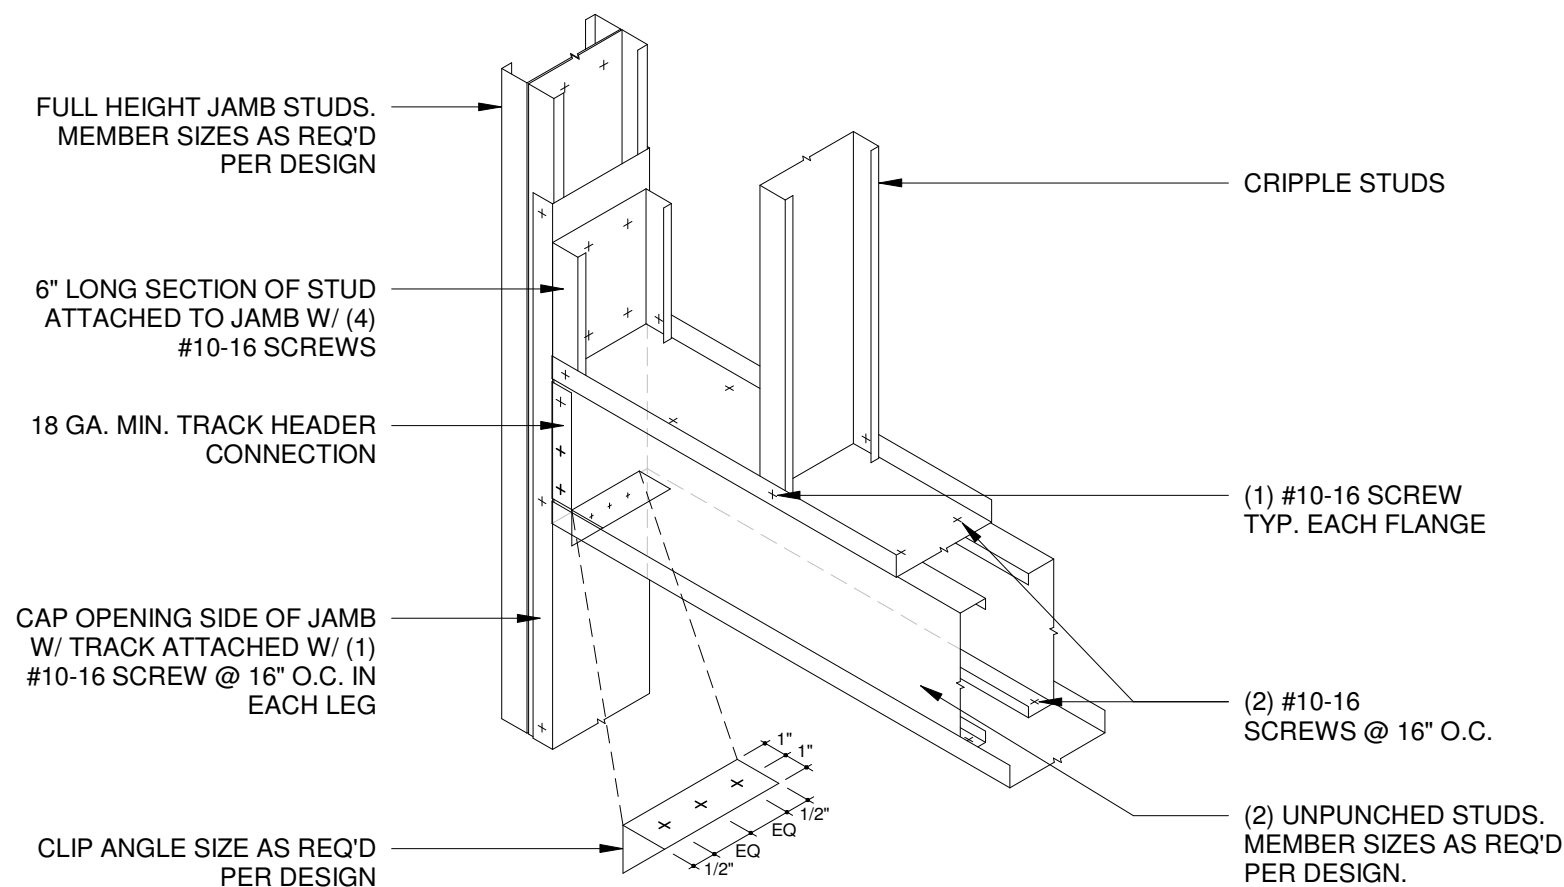

CURTAIN WALL HEADER TO BACK-TO-BACK JAMB

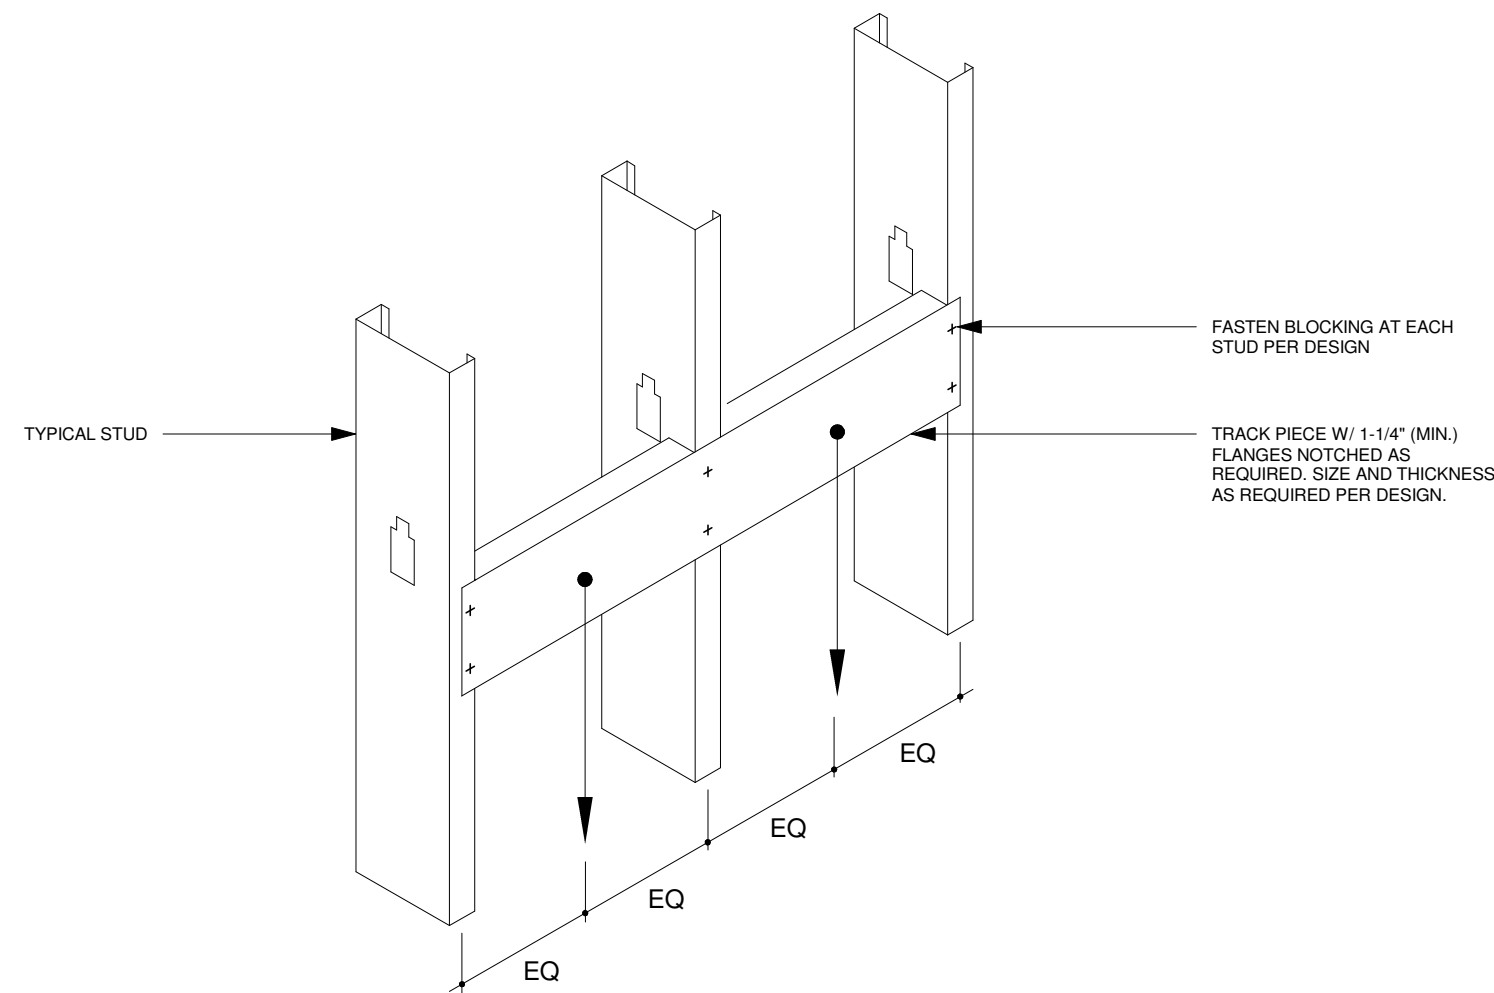




8 DOOR JAMB ANCHORAGE DETAIL

SCALE: 3/4" = 1'-0"

5 BOXED HEADER CONNECTION
SCALE: 3/4" = 1'-0"

2 BACKING PLATE DETAIL

SCALE: 3/4" = 1'-0"

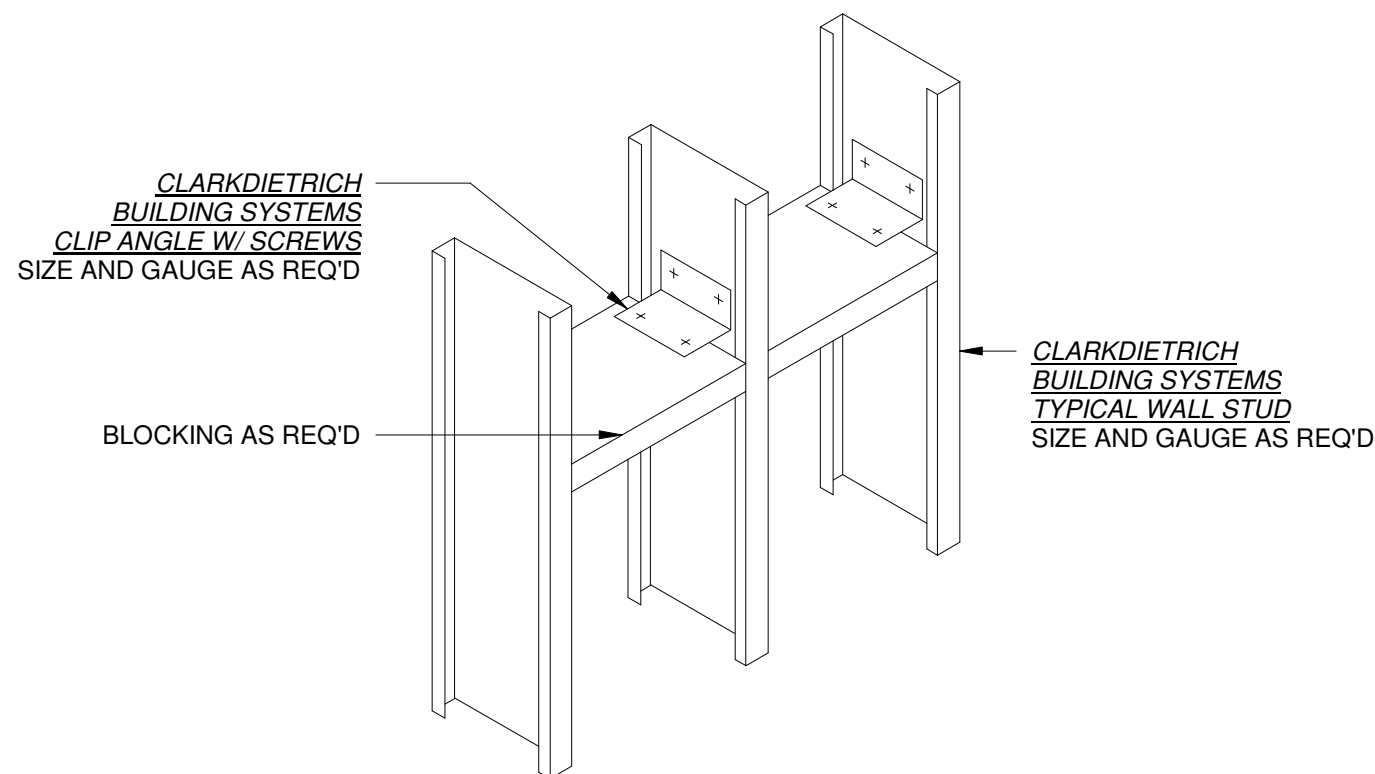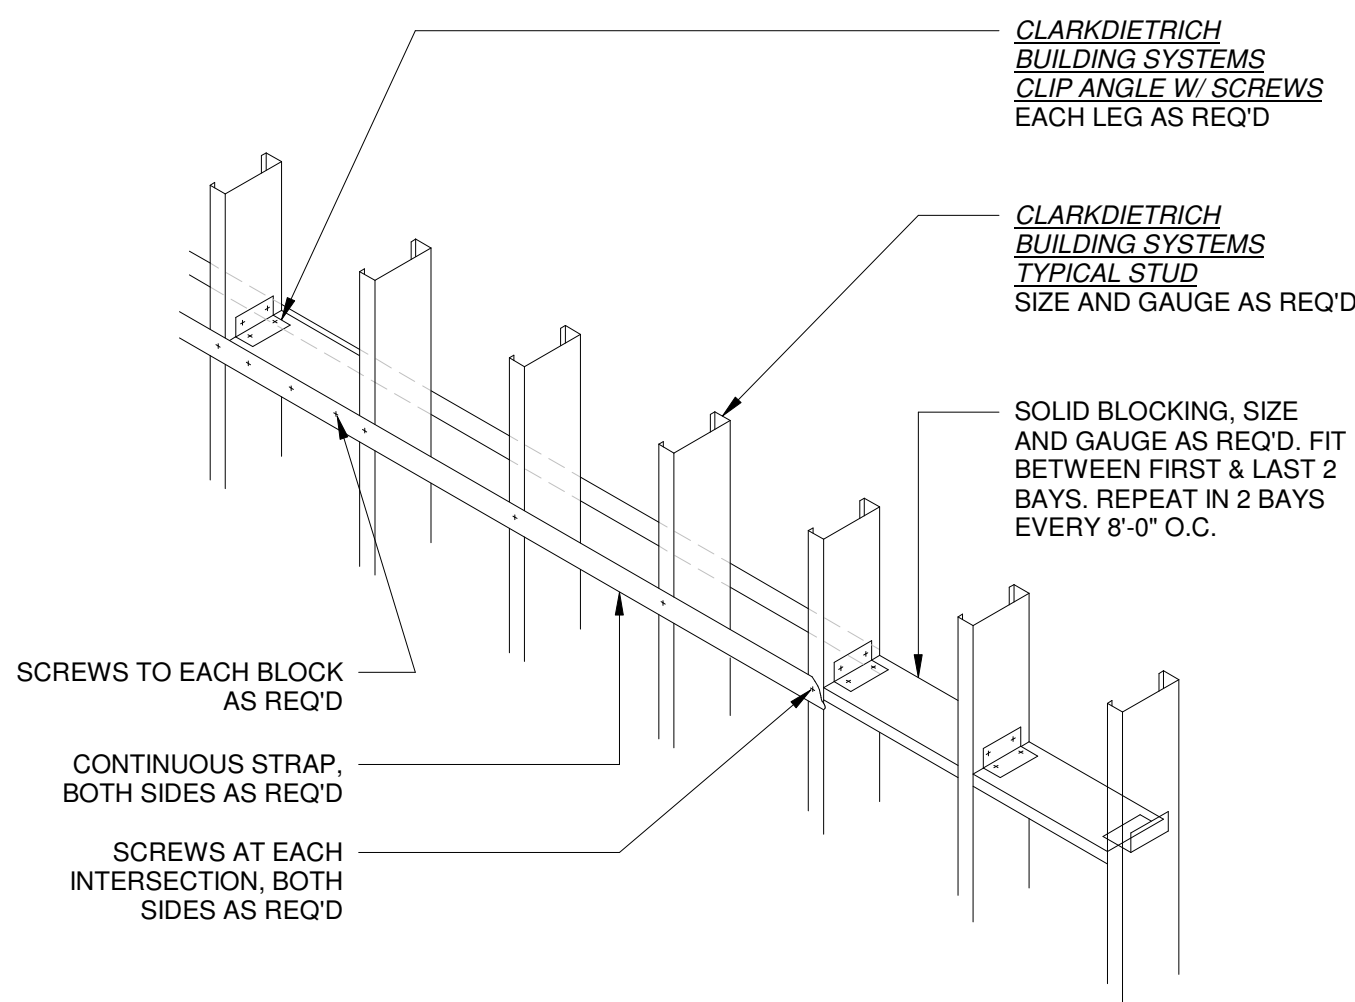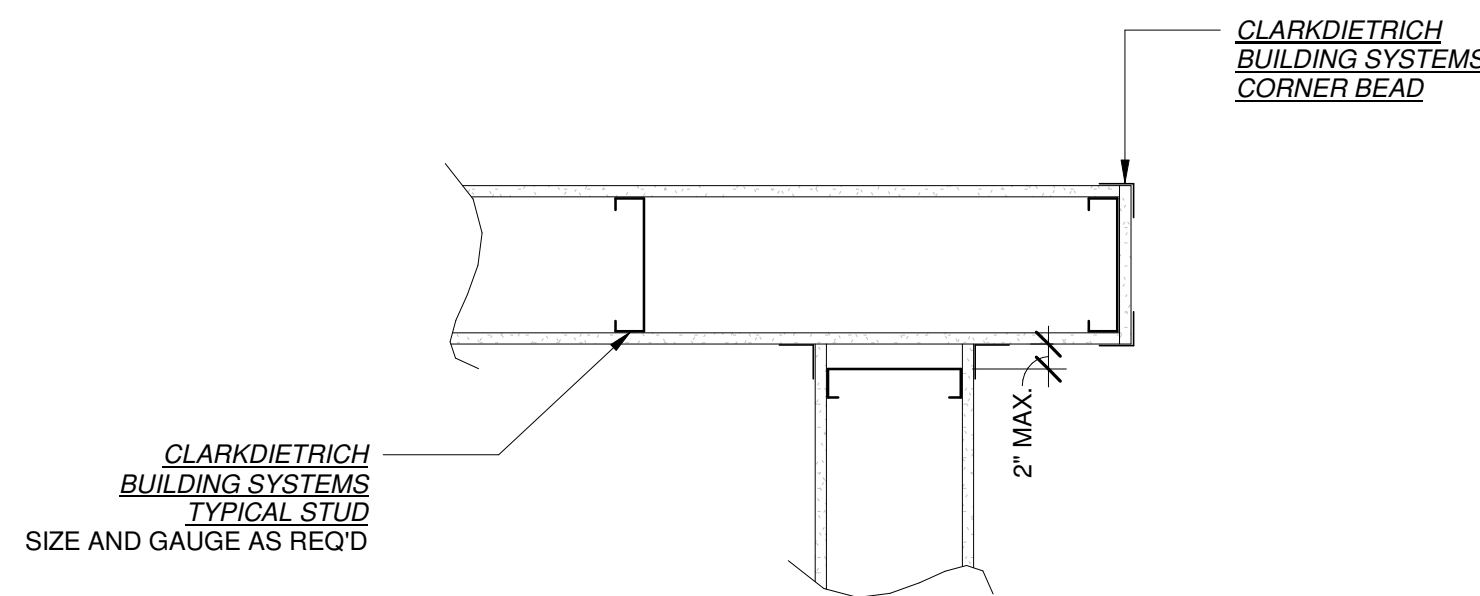


7 SOLID BLOCKING DETAIL


SCALE: 3/4" = 1'-0"

4 BLOCK AND STRAP BRIDGING

1 CORNER BEAD APPLICATION DETAIL

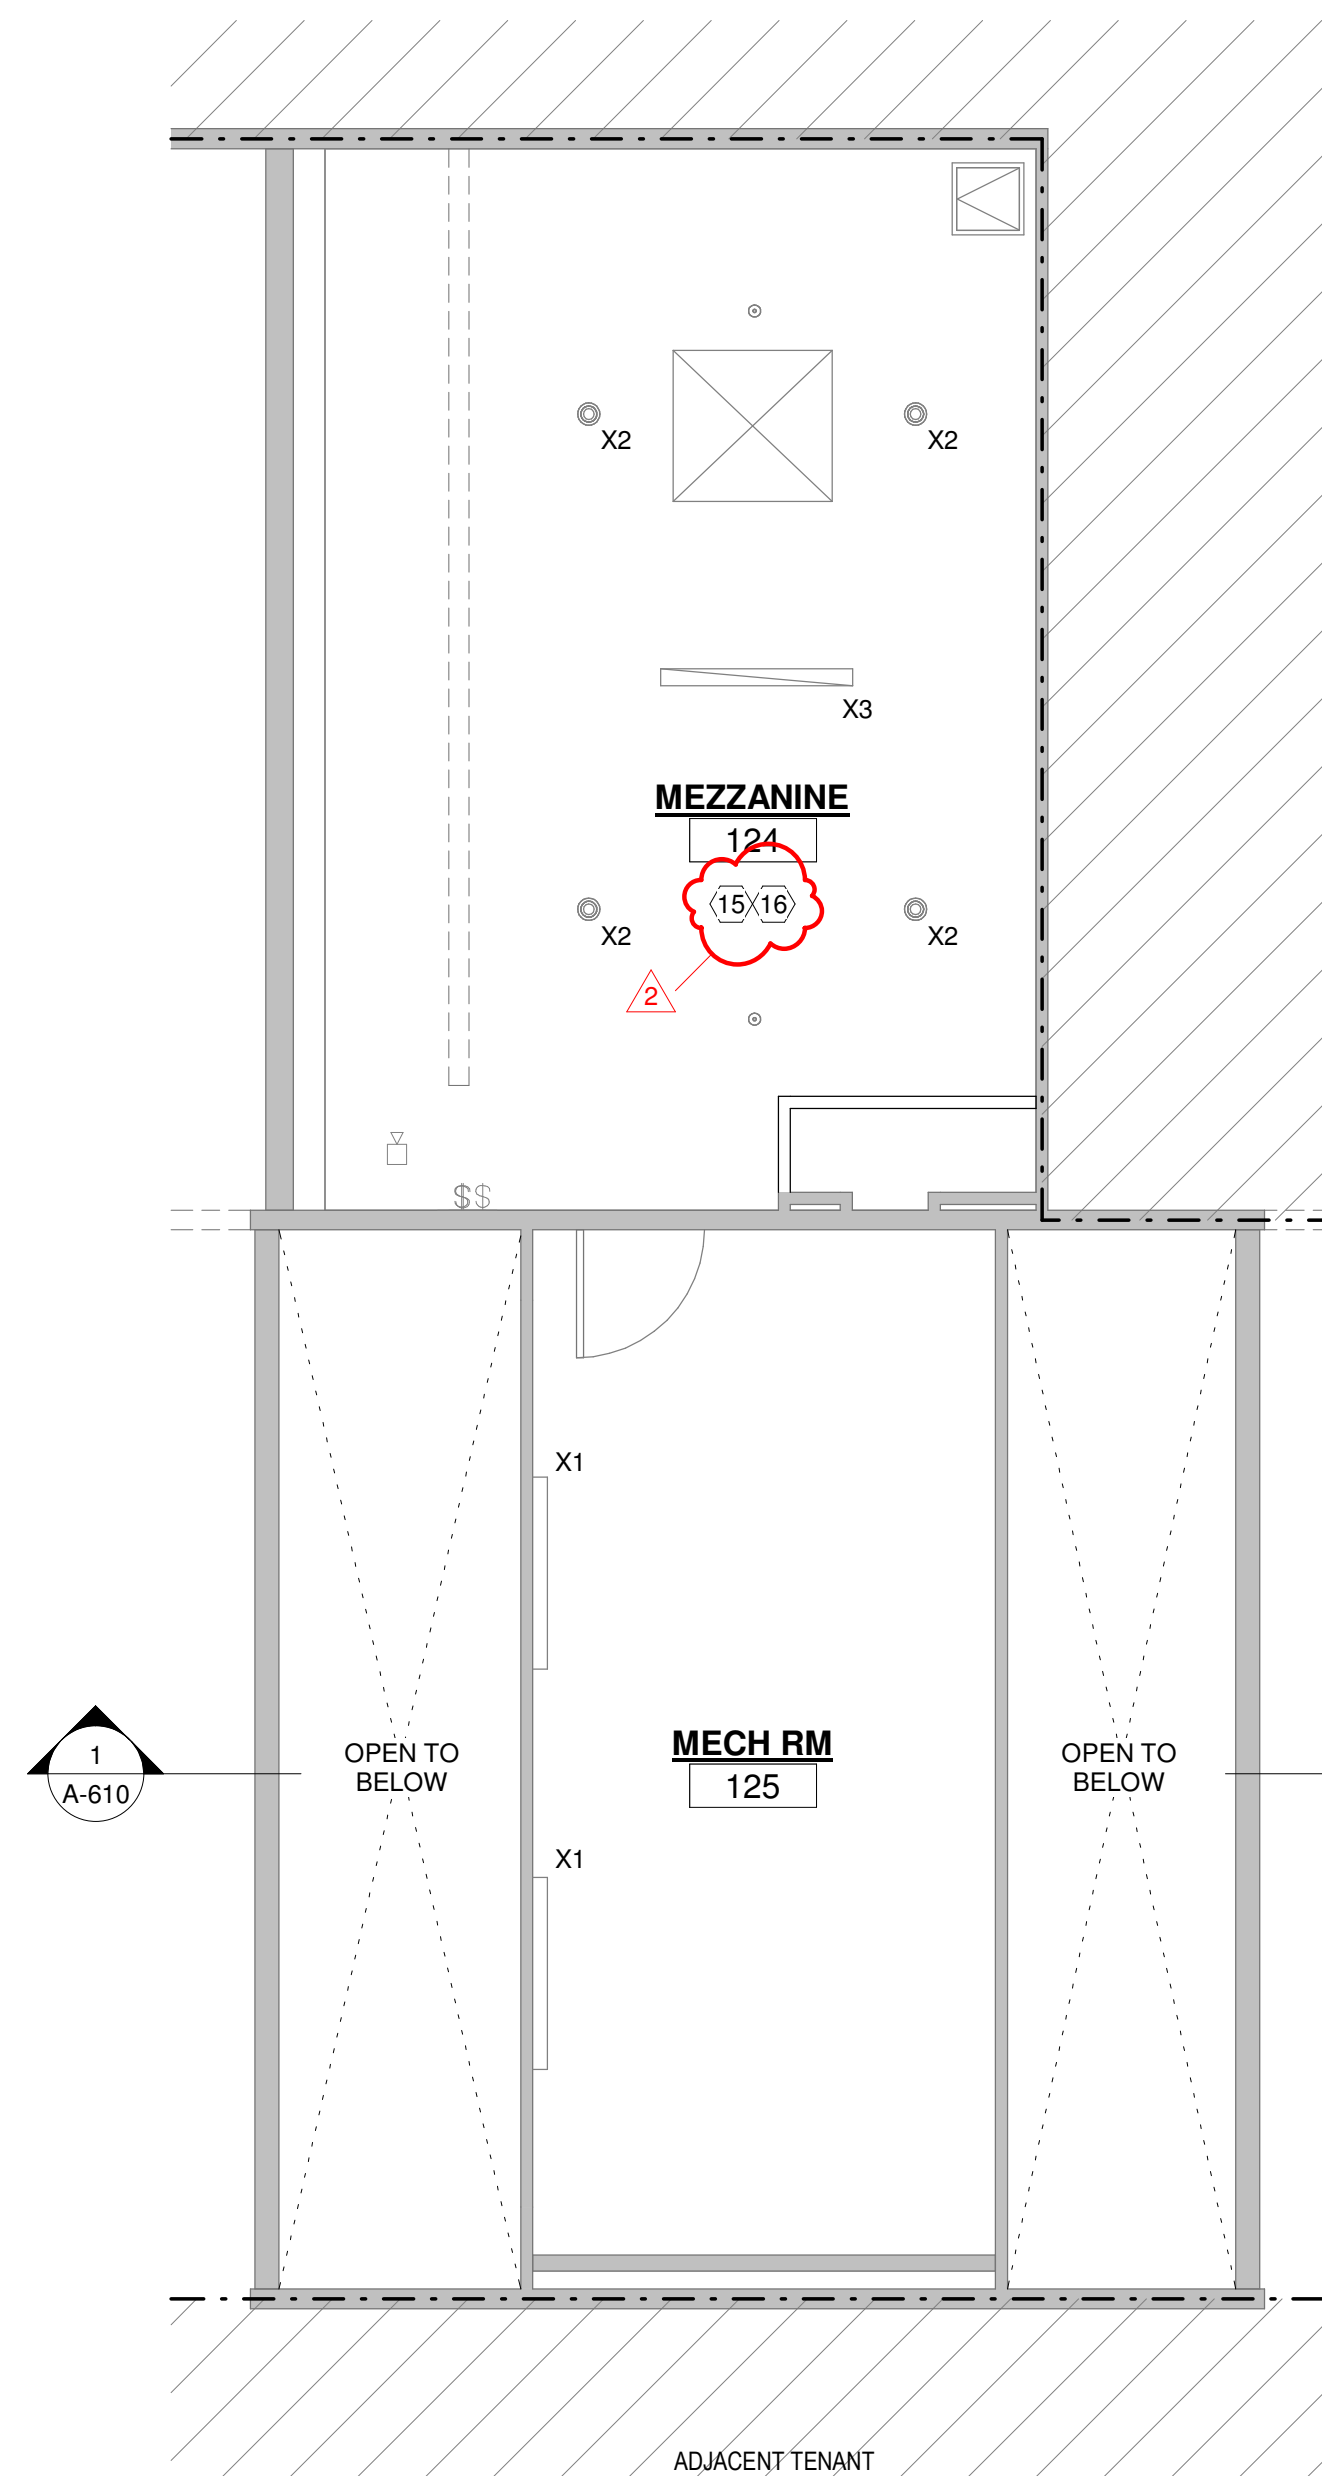


2 MEZZANINE REFLECTED CEILING PLAN

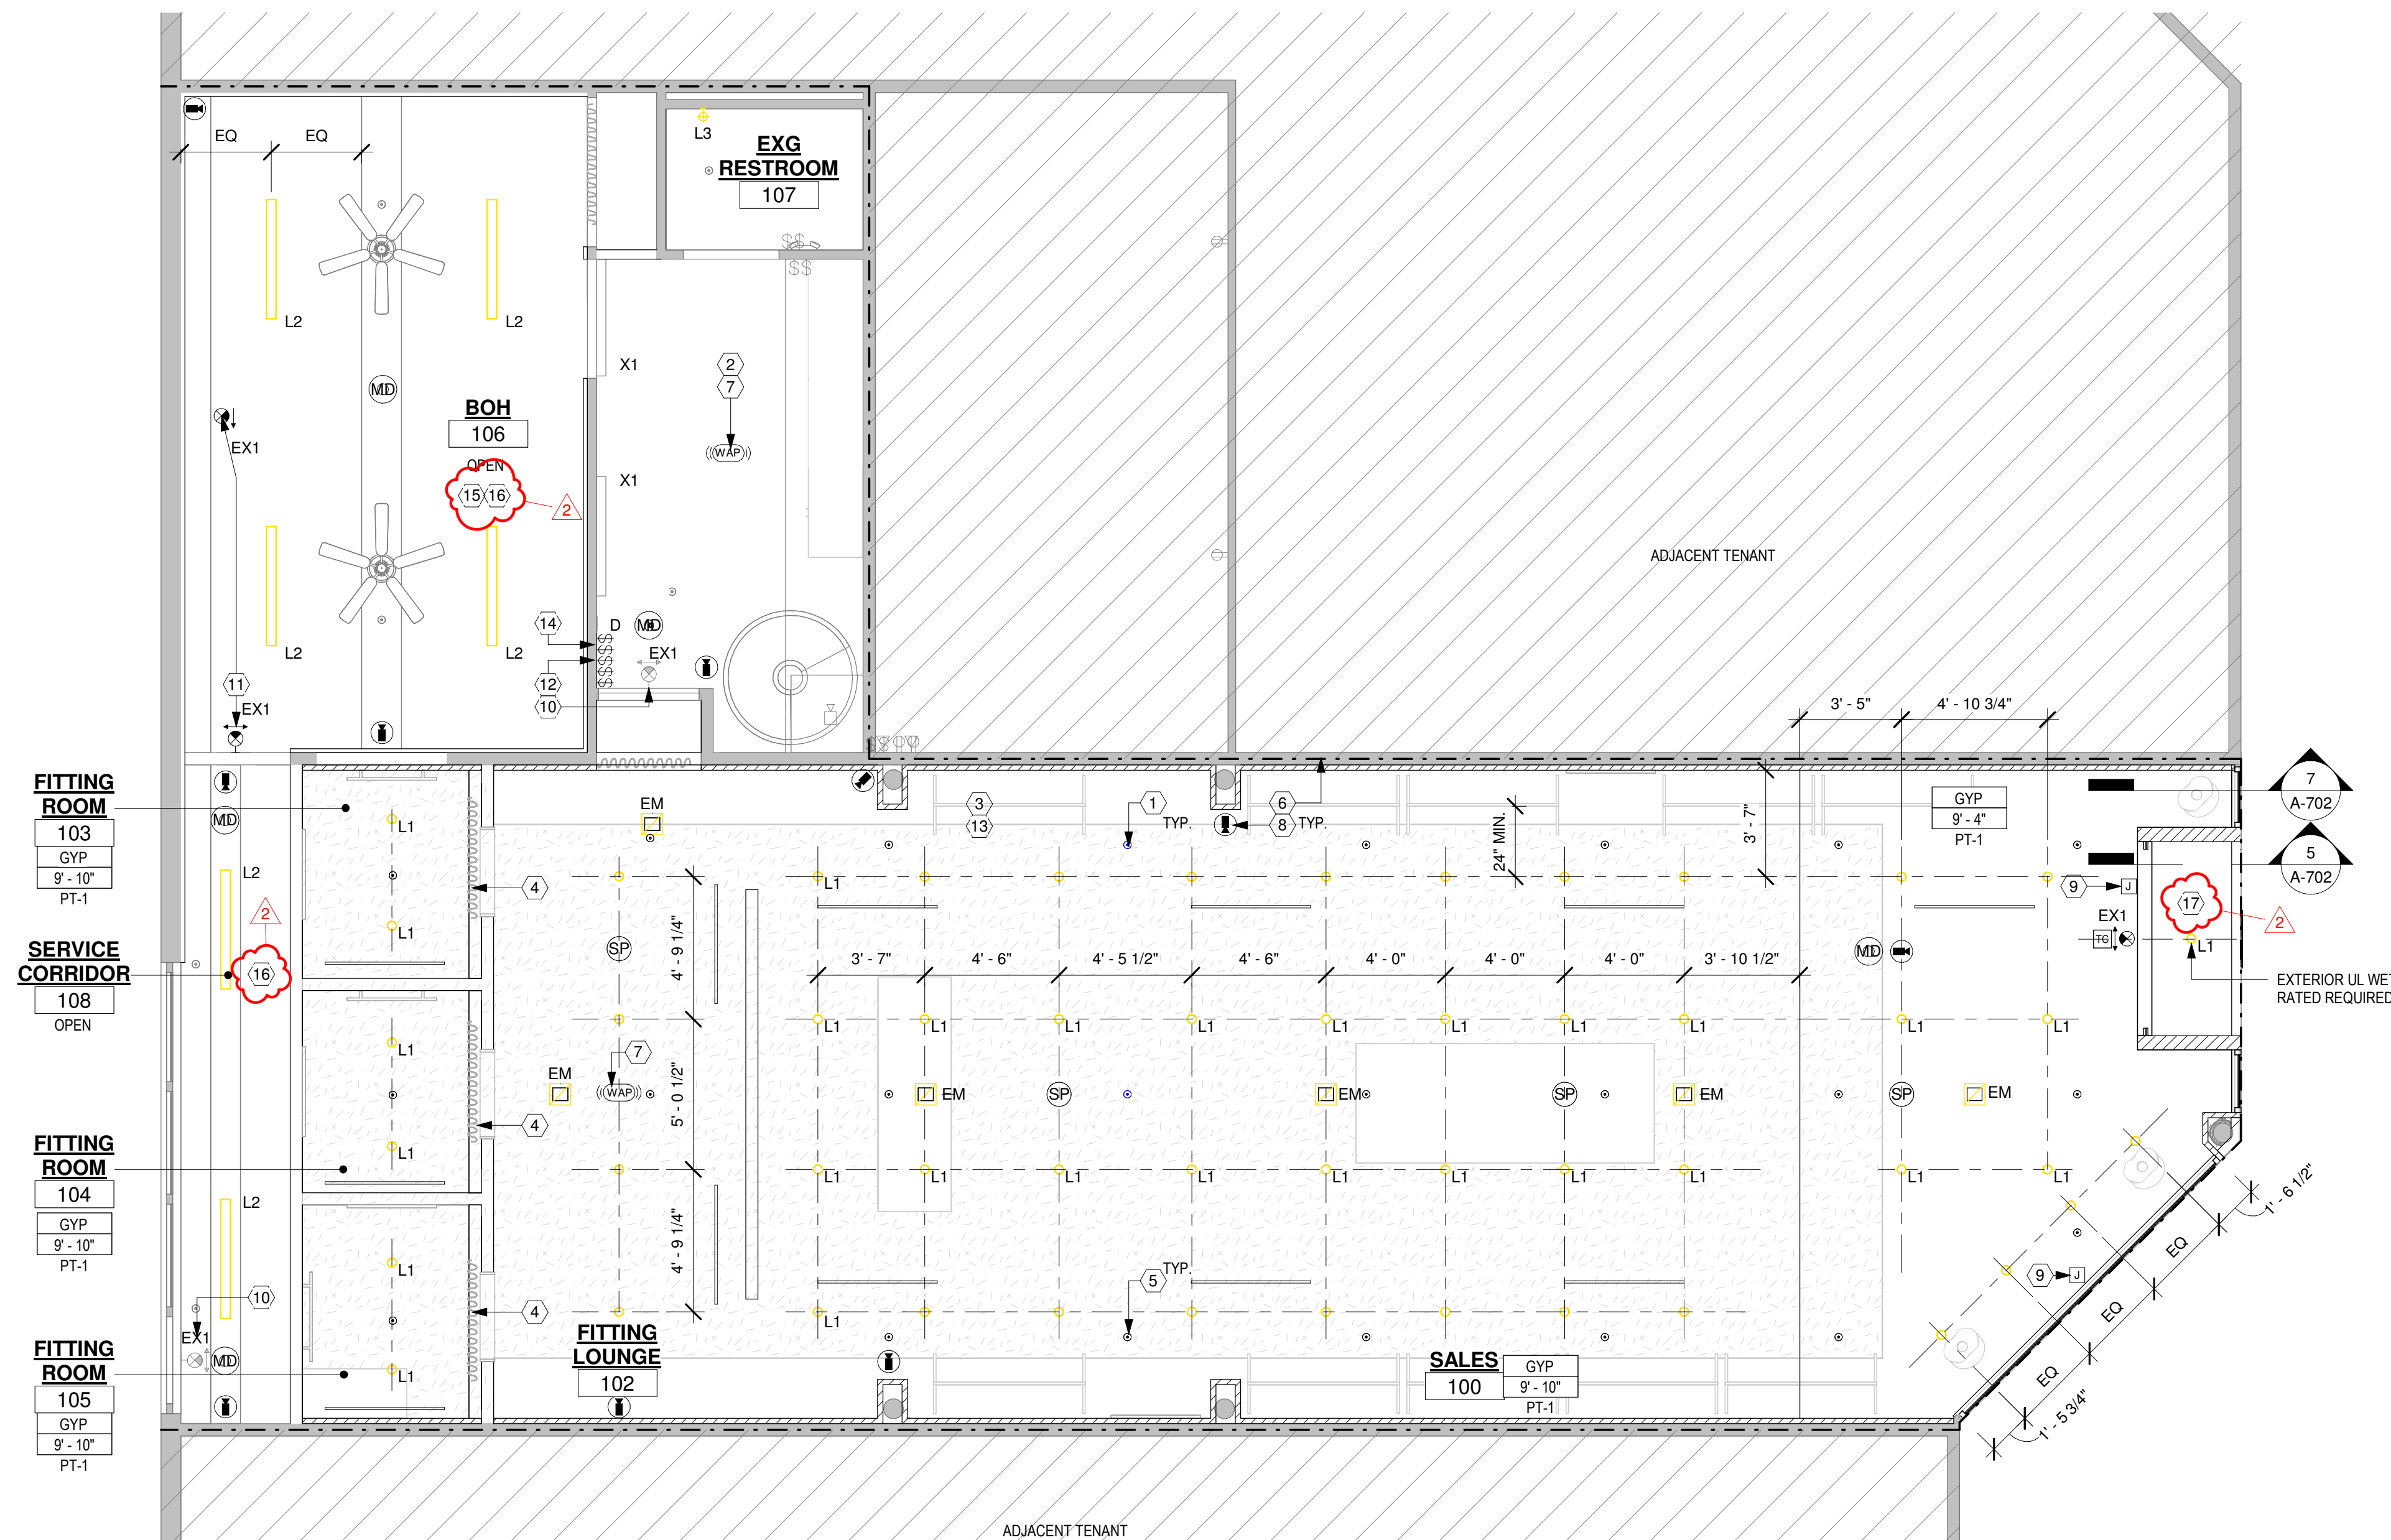

1 REFLECTED CEILING PLAN
SCALE: 1/4" = 1'-0"

 REFLECTED CEILING PLAN LEGEND

SYMBOL	DESCRIPTION
•	CONCEALED SPRINKLER HEAD. WHITE FINISH COVER PLATE AT GYP. BOARD/ACTING. REFER TO SPRINKLER SHOP DRAWINGS FOR MORE INFORMATION.
	TAPE-IN SLOT DIFFUSER. REFER TO MECHANICAL DRAWINGS FOR MORE INFORMATION.
	CEILING SPEAKER. EACH WIRED BACK TO AVX RACK. SEE POWER PLAN FOR VC LOCATION.
	LIFT & SHIFT TAPE-IN CEILING ACCESS PANEL. SQUARE CORNERS. SPEC: BAUCO PLUS II 24X24 & 36X36 - OR APPROVED EQUAL SEAMLESS
	CEILING SUPPLY GRILLE. REFER TO MECHANICAL DRAWINGS FOR MORE INFORMATION.
	CEILING RETURN GRILLE. REFER TO MECHANICAL DRAWINGS FOR MORE INFORMATION.
	CEILING EXHAUST FAN. REFER TO MECHANICAL DRAWINGS FOR MORE INFORMATION.
	NEW CAT 6 CEILING DATA CONNECTION WAP = WIRELESS ACCESS POINT DEVICE
	CEILING MOUNTED DOME SECURITY CAMERA. REFER TO VENDOR SHOP DRAWINGS. FINAL DIMENSIONAL LOCATIONS SEE RCP.
	WALL MOUNTED SECURITY MOTION DETECTOR. REFER TO VENDOR SHOP DWGS.
	CEILING MOUNTED SECURITY MOTION DETECTOR. REFER TO VENDOR SHOP DWGS.
	SMOKE DETECTOR AS REQUIRED. REFER TO ENGINEERING DRAWINGS
 EXIT (c/w)	SEE LIGHTING SCHEDULE FOR EXIT SIGN SPECIFICATIONS c = RECESSED CEILING / PENDANT MOUNTED w = RECESSED WALL MOUNTED

REFLECTED CEILING PLAN GENERAL NOTES

	GYP BD CEILING AT STOREFRONT IS NOT PERMITTED. STOREFRONT FINISHES ARE TO COVER CEILING OF RECESSED ENTRY VESTIBULE AND CEILING ON MALL SIDE OF STOREFRONT GLASS. TYP.
	SURFACE MOUNTED CEILING EQUIPMENT/COMPONENTS MUST BE CONCEALED ABOVE CEILING AS APPLICABLE WITH ACCESS AT ADJACENT HVAC DIFFUSER. IF NECESSARY TO BE ON CEILING PLANE MUST BE PREFINISHED TO COLOR TO MATCH FINISHED CEILING. TYPICAL.
	SURFACE MOUNTED TRACK LIGHTS ARE REQUIRED TO BE IN RECESSED COVES. TYP.
	FIRE SPRINKLER HEADS MUST BE FULLY RECESSED, QUICK RESPONSE AND HAVE ESCUTCHEONS FINISHED TO MATCH COLOR OF FINISH CEILING. TYP.
	CEILING MUST BE FRAMED AND CONSTRUCTED OF NON COMBUSTIBLE MATERIALS. TYP.
	ACCESS PANELS ARE NOT PERMITTED UNLESS REQUIRED FOR ACCESS TO MALL SYSTEMS - ANY TENANT ITEMS REQUIRING AN ACCESS PANEL SHOULD PROVIDE ACCESS AT ADJACENT HVAC DIFFUSER OR RETURN AIR. TYP.
	ACCESS PANELS TO BE FRAMELESS AND SHALL BE MADE AS INCONSPICUOUS AS POSSIBLE, HIDDEN FROM VIEW FROM THE ENCLOSED MALL.
	DISPLAY GRIDS ARE NOT ACCEPTABLE - MUST USE RECESSED DISPLAY TRACKS. TYP.
	WIFI ANTENNAS TO BE LOCATED ABOVE CEILING PLANE IN SALES AREA TYP.
	SUBMIT LIGHT FIXTURE CUT SHEETS TO LL FOR REVIEW.
	CONNECTION TO LANDLORD METAL DECK IS NOT PERMITTED
	EXPPOSED DECK AND STRUCTURE TO BE DETAILED FOR EXPOSURE. ALL CONDUTS, DUCT WORK, AND PIPING SHALL BE GANGED TOGETHER AND RUN PARALLEL AND PERPENDICULAR TO LEASE LINES. ALL EQUIPMENT (GRID, PIPES, DUCTS, FIXTURES, ETC) SHALL BE HUNG BY HANG RODS (NOT WIRE). DUCT WORK TO BE ROUND OR SPIRAL WITH NO EXTERIOR INSULATION
	SEPARATE EMERGENCY LIGHT FUTURES ARE NOT ACCEPTABLE. EMERGENCY LIGHTING MUST BE HANDLED WITH POWER INVERTERS TO TENANT LIGHT FIXTURES. AS MANY AS REQUIRED TO MEET CODE FOR ILLUMINATION OR USE CONCEALED EMERGENCY LIGHT FIXTURES THAT ARE ONLY VISIBLE UPON TRIGGER.

REFLECTED CEILING PLAN KEY NOTES

- 1 SPRINKLERS TO BE RELOCATED. SPRINKLER HEADS TO BE CONCEALED. COLOR TO MATCH CEILING.
- 2 EXISTING GYP. BOARD CEILING AT BACK OF HOUSE TO REMAIN.
- 3 NEW SECURITY CAMERA'S THROUGHOUT GROUND FLOOR. COORDINATE WITH VENDOR SHOP DRAWINGS AND DIMENSIONED RCP.
- 4 COVE WITH FITTING ROOM FOR CURTAIN HUNG BY CEILING MOUNTED CURTAIN TRACK. BLINDSPACE TRACKTRIM PROVIDED BY OWNER AND INSTALLED BY GC. GG TO PROVIDE METAL STUD BLOCKING AT CEILING. SEE DETAIL 3/A-211.
- 5 NEW SPRINKLER HEAD. COORDINATE WITH VENDOR'S DRAWINGS. CONCEALED SPRINKLER HEAD ON ALL SALES AREA.
- 6 PATCH AND REPAIR EXISTING GYPSUM DEMISING WALL TO REMAIN (VISIBLE PATCHES) PRIOR TO NEW CONITION AND PREP FOR NEW WALL FINISH OR ATTACHMENT IS REQUIRED.
- 7 WIRELESS ACCESS POINT AT CEILING. GC TO PROVIDE (1) FEMALE PORT AT CEILING FOR FINAL DEVICE CONNECTION. RUN 2 CABLES (ONE ACTIVE, ONE SPACE) TO IT RACK, TERMINATED INTO 2 PORTS AT PATCH PANEL. WAP AND WIFI ANTENNAS MUST BE LOCATED ABOVE CEILING AND NOT VISIBLE IN SALES AREA.
- 8 SECURITY CAMERA TO BE 360 DEGREES
- 9 J-BOX ABOVE CEILING. GC TO COORDINATE EXACT LOCATION WITH STORE FRONT SIGNAGE
- 10 EXISTING EXIST SIGN TO REMAIN; SCHEDULED FOR RE-USE
- 11 NEW EXIST SIGN TO BE INSTALLED BY GC. SEE SCHEDULE FOR MORE INFORMATION.
- 12 NEW LIGHT SWITCHES FOR FIXTURES. ALL LIGHT SWITCH COVER PLATES TO BE DELETED SNAP ON SERIES. NO VISIBLE SCREWS. GC TO PROVIDE SUBMITTAL FOR REVIEW.
- 13 EXISTING FIRE PROTECTION SPRINKLER SYSTEM TO BE MODIFIED AS REQUIRED PER NEW TENANT DESIGN. LANDLORD APPROVED SPRINKLER CONTRACTOR (PROCURED THRU GC) TO PROVIDE SHOP DRAWINGS AND SEPARATE PERMIT SUBMITTAL. CONCEALED HEADS WITH WHITE COVERPLATE AT ALL CUSTOMER VISIBLE AREAS.
- 14 WALL MOUNTED LIGHTING MASTER SWITCH BANK AT J.B. REF. REFER TO ELECTRICAL DWGS. ALL SWITCHES TO BE DIMMABLE U.O.N.
- 15 NEW CEILING IS USED. ALL ELECTRICAL AND SPRINKLER CONDUITS AND ALL DUCTWORK TO BE RUN ORTHOGONALLY AND IN AN ORGANIZED MANNER. DO NOT RUN ANY CEILING EQUIPMENT ON A DIAGONAL.
- 16 AT OPEN CEILING AREA, EXTEND GYP BD TO DECK ON STOCK ROOM SIDE OF WALL AND SEAL OR INSTALL CEILING IN STOCK ROOM.
- 17 EXTERIOR ENTRY SOFFIT FINISH TO MATCH EXTERIOR FACADE.

45 WEST 21st STREET, SUITE 403
NEW YORK, NY 10010

IN ASSOCIATION WITH THE ARCHITECT:
R H SWEERS II, PROPRIETOR
R H SWEERS ARCHITECT

ALL DRAWINGS AND WRITTEN MATERIAL APPEARING HEREIN
CONSTITUTE ORIGINAL AND UNPUBLISHED WORK OF THE
ARCHITECT AND MAY NOT BE DUPLICATED, USED OR DISCLOSED
WITHOUT WRITTEN
CONSENT OF THE ARCHITECT. THIS DOCUMENT IS INTENDED
SOLELY FOR THE CONSTRUCTION OF THE PROJECT NAMED HEREIN
AND SHALL NOT BE USED BY ANY OTHER CONSTRUCTION WITHOUT
WRITTEN CONSENT OF THE ARCHITECT.

THIS DRAWING WAS PREPARED UNDER MY SUPERVISION AND I
DISCLAIM ANY RESPONSIBILITY FOR THE EXISTING BUILDING
CONSTRUCTION ELEMENTS, SITE CONDITIONS, OR ANY DOCUMENT
WHICH DO NOT BEAR MY SEAL.

SEAL

ISSUE FOR BID

DRAWINGS ISSUED

No.	Rev	Date	Description
1		06.18.26	LL REVIEW SET
2		06.24.26	ISSUE FOR PERMIT
3		07.02.26	ISSUE FOR BID
5	2	08.27.26	BID ADDENDUM #2

PROJECT NAME:
TWP NAPLES

TWP

PROJECT ADDRESS:
WATERSIDE SHOPS
5455 TAMiami TrL N
NAPLES, FL 34108

DRAWING TITLE:
**REFLECTED CEILING
PLAN**

SCALE: AS SHOWN

Project No.	26TWP05
Scale:	1/4" = 1'-0"
Date:	08-20-2026
Drawn By:	212
Checked BY:	212

DRAFTING NO.

LIGHTING SCHEDULE								
TAG	QTY	LOCATION	COMMENTS	SPEC	WATTS	MANUF.	PROVIDED BY	INSTALLED BY
EM	7	EMERGENCY CONCEALED LIGHTS THROUGHOUT SPACE	EMERGENCY LIGHTS THROUGHOUT	APAL-WH-UI	9 W	Evenlite	OWNER	GC
EX1	1	SALES, BOH VESTIBULE, BOH	EDGE-LIT SINGLE FACE EXIT SIGN - GREEN LETTERS ON CLEAR PANEL	PINN-G-AC90MINBU-CR/WR-1-C-BAL	3 W	Pinnacle	OWNER	GC
L1	53	SALES DOWNLIGHTS	TRIMLESS RECESSED DOWNLIGHTS THROUGHOUT SALES AREA. LIGHTS TO BE ADJUSTABLE.	H3R-2035Z/W00LE NNC TRIM H3T-LR-A/WWHTL	21W	Liteline	OWNER	GC
L2	6	BOH LINEAR PENDANTS	NEW LINEAR PENDANTS FOR BOH	12100-22-P-FLT-24-WH-SHD-B-RCP-OS	10W/FT	Alcon Lighting	OWNER	GC
L3	1	BATHROOM WALL SCONCE	WALL SCONCE IN BATHROOM TO BE REPLACED IN SAME LOCATION	FMVCCLS 24IN MVOLT 30K 90CRI BN	18W	Lithonia	OWNER	GC
EXISTING LIGHTING SCHEDULE								
TAG	QTY	LOCATION	COMMENTS	SPEC	WATTS	MANUF.		
X1	4	WALL MOUNTED FLUORESCENT LIGHT	EXISTING BOH AND MECHANICAL ROOM WALL MOUNTED LIGHT	LAMP UP 4/39 LAMP DOWN 1/382D TRIM STYLE-A/120V	54 W		LIGHTOLIER	
X2	4	RECESSED DOWNLIGHT	EXISTING RECESSED DOWNLIGHT LOCATED AT MEZZANINE	REFLECTOR 8031CLW/TRIPL. LUBE LAMP. 26W	26 W		LIGHTOLIER	
X3	1	CEILING FLUORESCENT LIGHT	EXISTING BOH MEZZANINE LIGHT AT CEILING	SILVANIA #FP54/835/HO	54 W		LIGHTOLIER	

ISSUE FOR BID



45 WEST 21st STREET, SUITE 403
NEW YORK, NY 10010

IN ASSOCIATION WITH THE ARCHITECT:
R H SWEERS II, PROPRIETOR
R H SWEERS ARCHITECT

ALL DRAWINGS AND WRITTEN MATERIAL APPEARING HEREIN CONSTITUTE ORIGINAL AND UNPUBLISHED WORK OF THE ARCHITECT AND MAY NOT BE DUPLICATED, USED OR DISCLOSED WITHOUT WRITTEN CONSENT OF THE ARCHITECT. THIS DOCUMENT IS INTENDED SOLELY FOR THE CONSTRUCTION OF THE PROJECT NAMED HEREIN AND SHALL NOT BE USED BY ANY OTHER CONSTRUCTION WITHOUT WRITTEN CONSENT OF THE ARCHITECT.

THIS DRAWING WAS PREPARED UNDER MY SUPERVISION AND I DISCLAIM ANY RESPONSIBILITY FOR THE EXISTING BUILDING CONSTRUCTION ELEMENTS, SITE CONDITIONS, OR ANY DOCUMENTS WHICH DO NOT BEAR MY SEAL.

SEAL

DRAWINGS ISSUED

No.	Rev	Date	Description
1		06.18.26	LL REVIEW SET
2		06.24.26	ISSUE FOR PERMIT
3		07.02.26	ISSUE FOR BID

PROJECT NAME:
TWP NAPLES



PROJECT ADDRESS:
WATERSIDE SHOPS
5455 TAMIAMI TRL N
NAPLES, FL 34108

DRAWING TITLE:
LIGHTING CUTS

SCALE: AS SHOWN

Project No.	26TWP05
Scale:	
Date:	08-20-2026
Drawn By:	212
Checked BY:	212

DRAWING NO:



45 WEST 21st STREET, SUITE 403
NEW YORK, NY 10010

IN ASSOCIATION WITH THE ARCHITECT:
R H SWEERS II, PROPRIETOR
R H SWEERS ARCHITECT

ALL DRAWINGS AND WRITTEN MATERIAL APPEARING HEREIN
CONSTITUTE ORIGINAL AND UNPUBLISHED WORK OF THE
ARCHITECT AND MAY NOT BE DUPLICATED, USED OR DISCLOSED
WITHOUT WRITTEN
CONSENT OF THE ARCHITECT. THIS DOCUMENT IS INTENDED
SOLELY FOR THE CONSTRUCTION OF THE PROJECT NAMED HEREIN
AND SHALL NOT BE USED BY ANY OTHER CONSTRUCTION WITHOUT
WRITTEN CONSENT OF THE ARCHITECT.

THIS DRAWING WAS PREPARED UNDER MY SUPERVISION AND I
DISCLAIM ANY RESPONSIBILITY FOR THE EXISTING BUILDING
CONSTRUCTION ELEMENTS, SITE CONDITIONS, OR ANY DOCUMENTS
WHICH DO NOT BEAR MY SEAL.

SEAL

ISSUE FOR BID

DRAWINGS ISSUED

No.	Rev	Date	Description
1		06.18.26	LL REVIEW SET
2		06.24.26	ISSUE FOR PERMIT
3		07.02.26	ISSUE FOR BID

PROJECT NAME:
TWP NAPLES

TWP


PROJECT ADDRESS:
WATERSIDE SHOPS
5455 TAMIAMI TRL N
NAPLES, FL 34108

DRAWING TITLE:
CEILING DETAILS


SCALE: AS SHOWN

Project No.	26TWP05
Scale:	As indicated
Date:	08-20-2026
Drawn By:	212
Checked By:	212
DRAWING NO:	


A-211

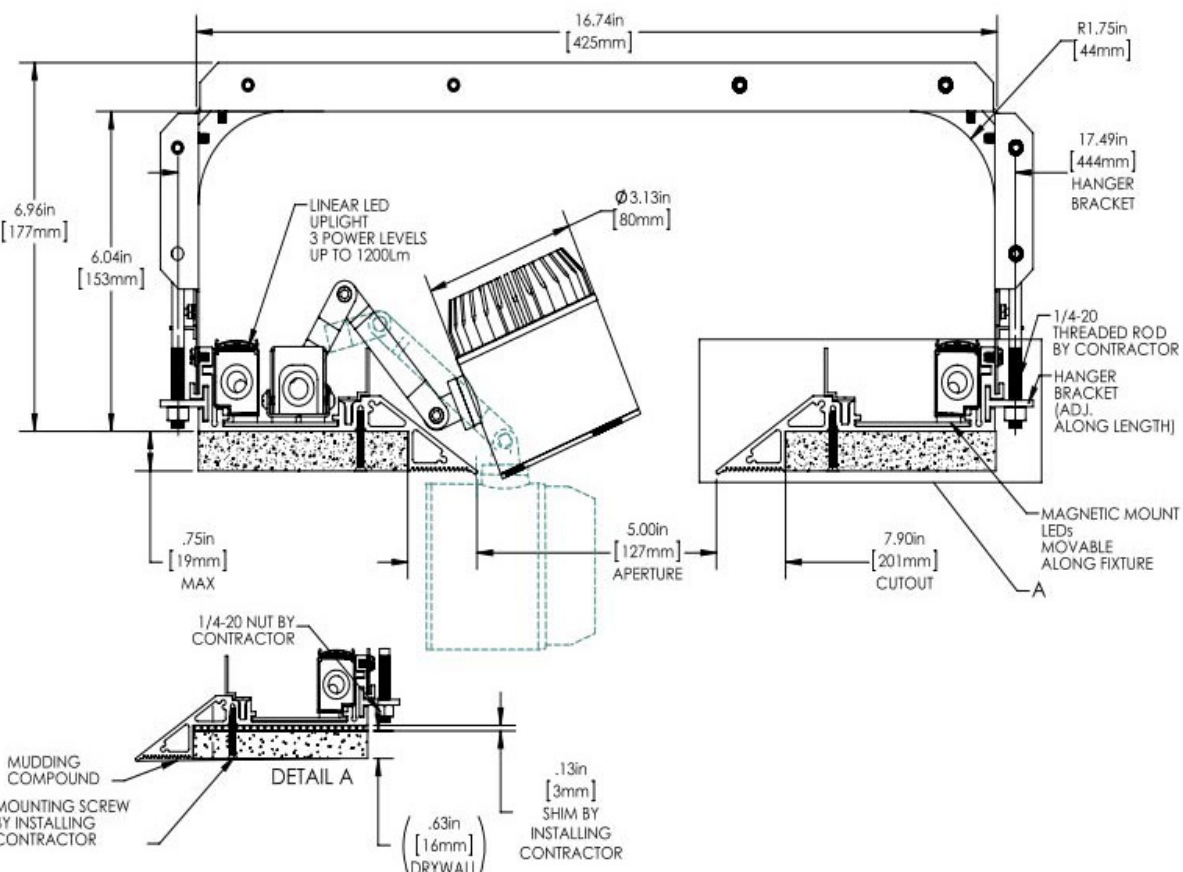


1 TYPICAL LIGHTING COVE DETAIL
SCALE: 3" = 1'-0"

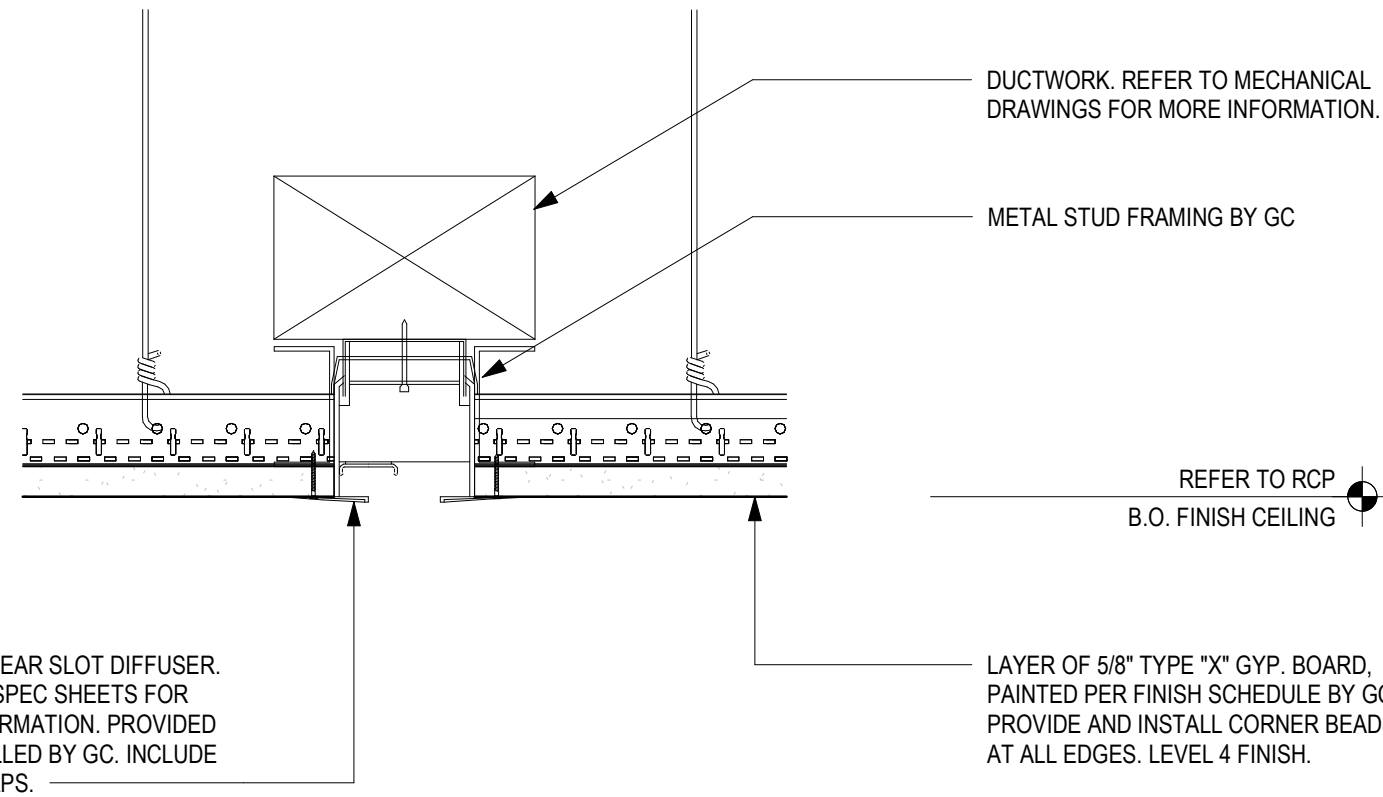


2 TYPICAL TAPE IN SLOT DIFFUSER DETAIL
SCALE: 3" = 1'-0"

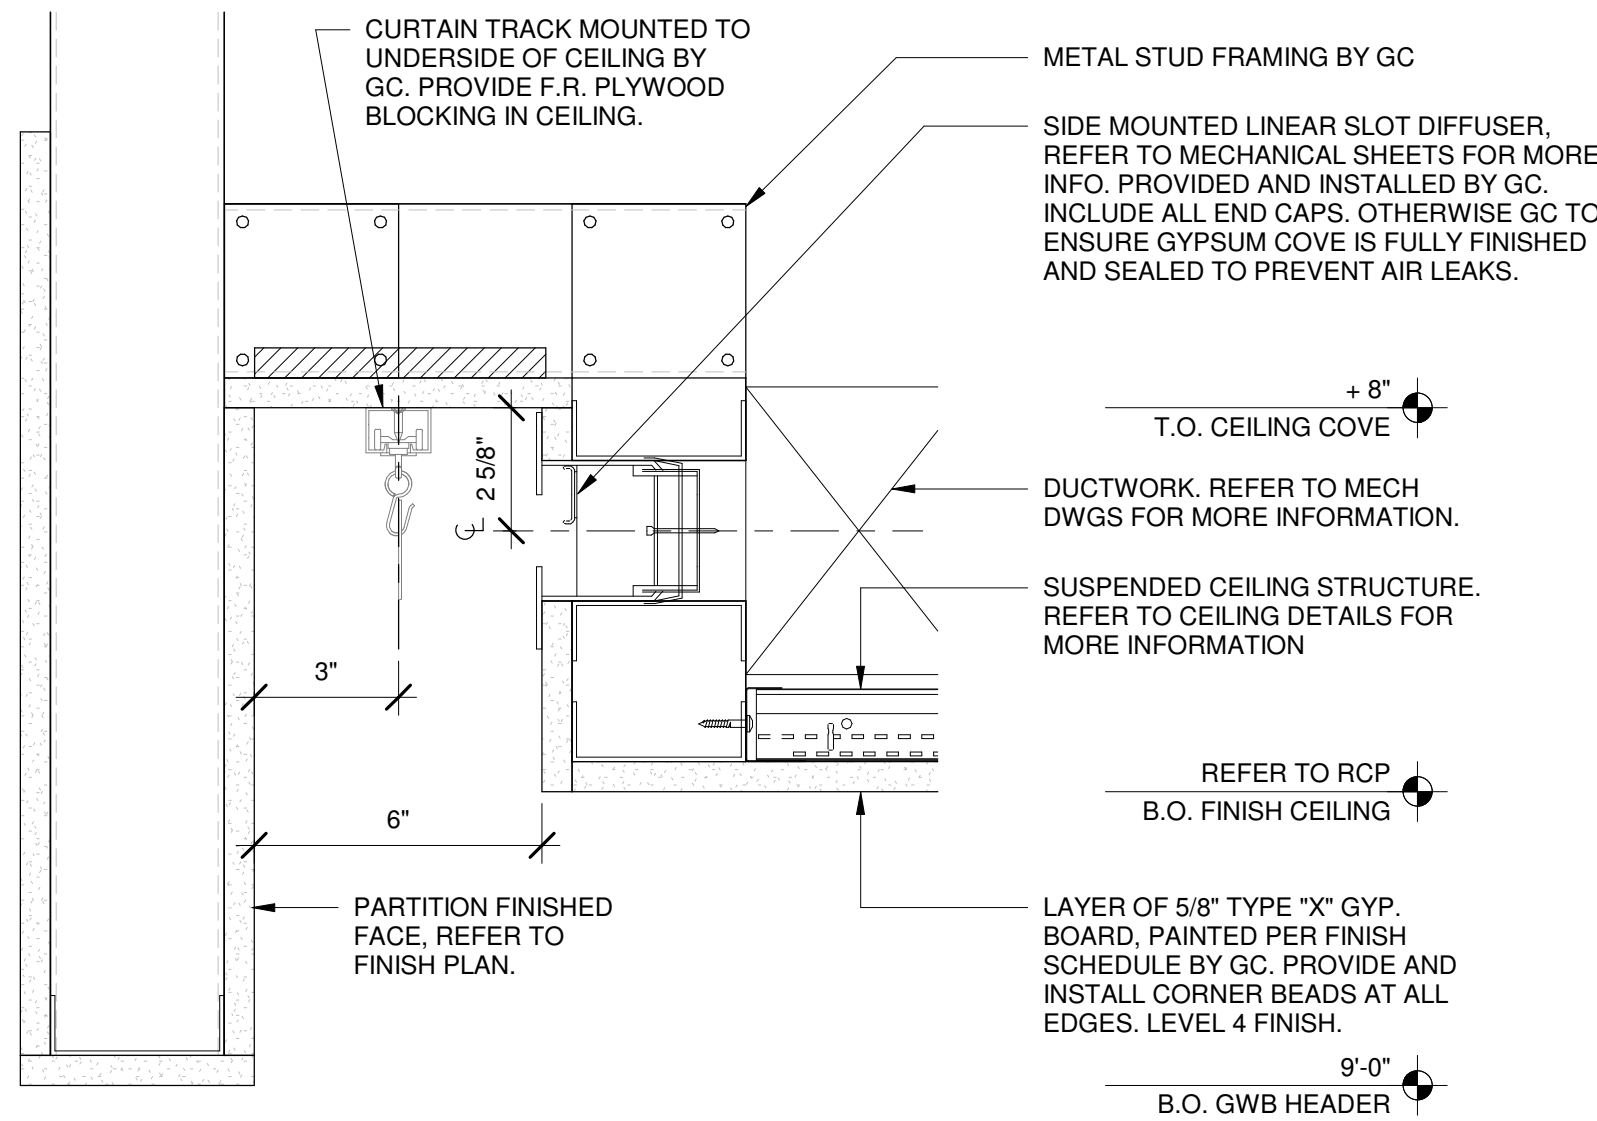


3 CLG COVE DETAIL - FITTING RM CURTAIN W/ SIDE DIFFUSER
SCALE: 3" = 1'-0"

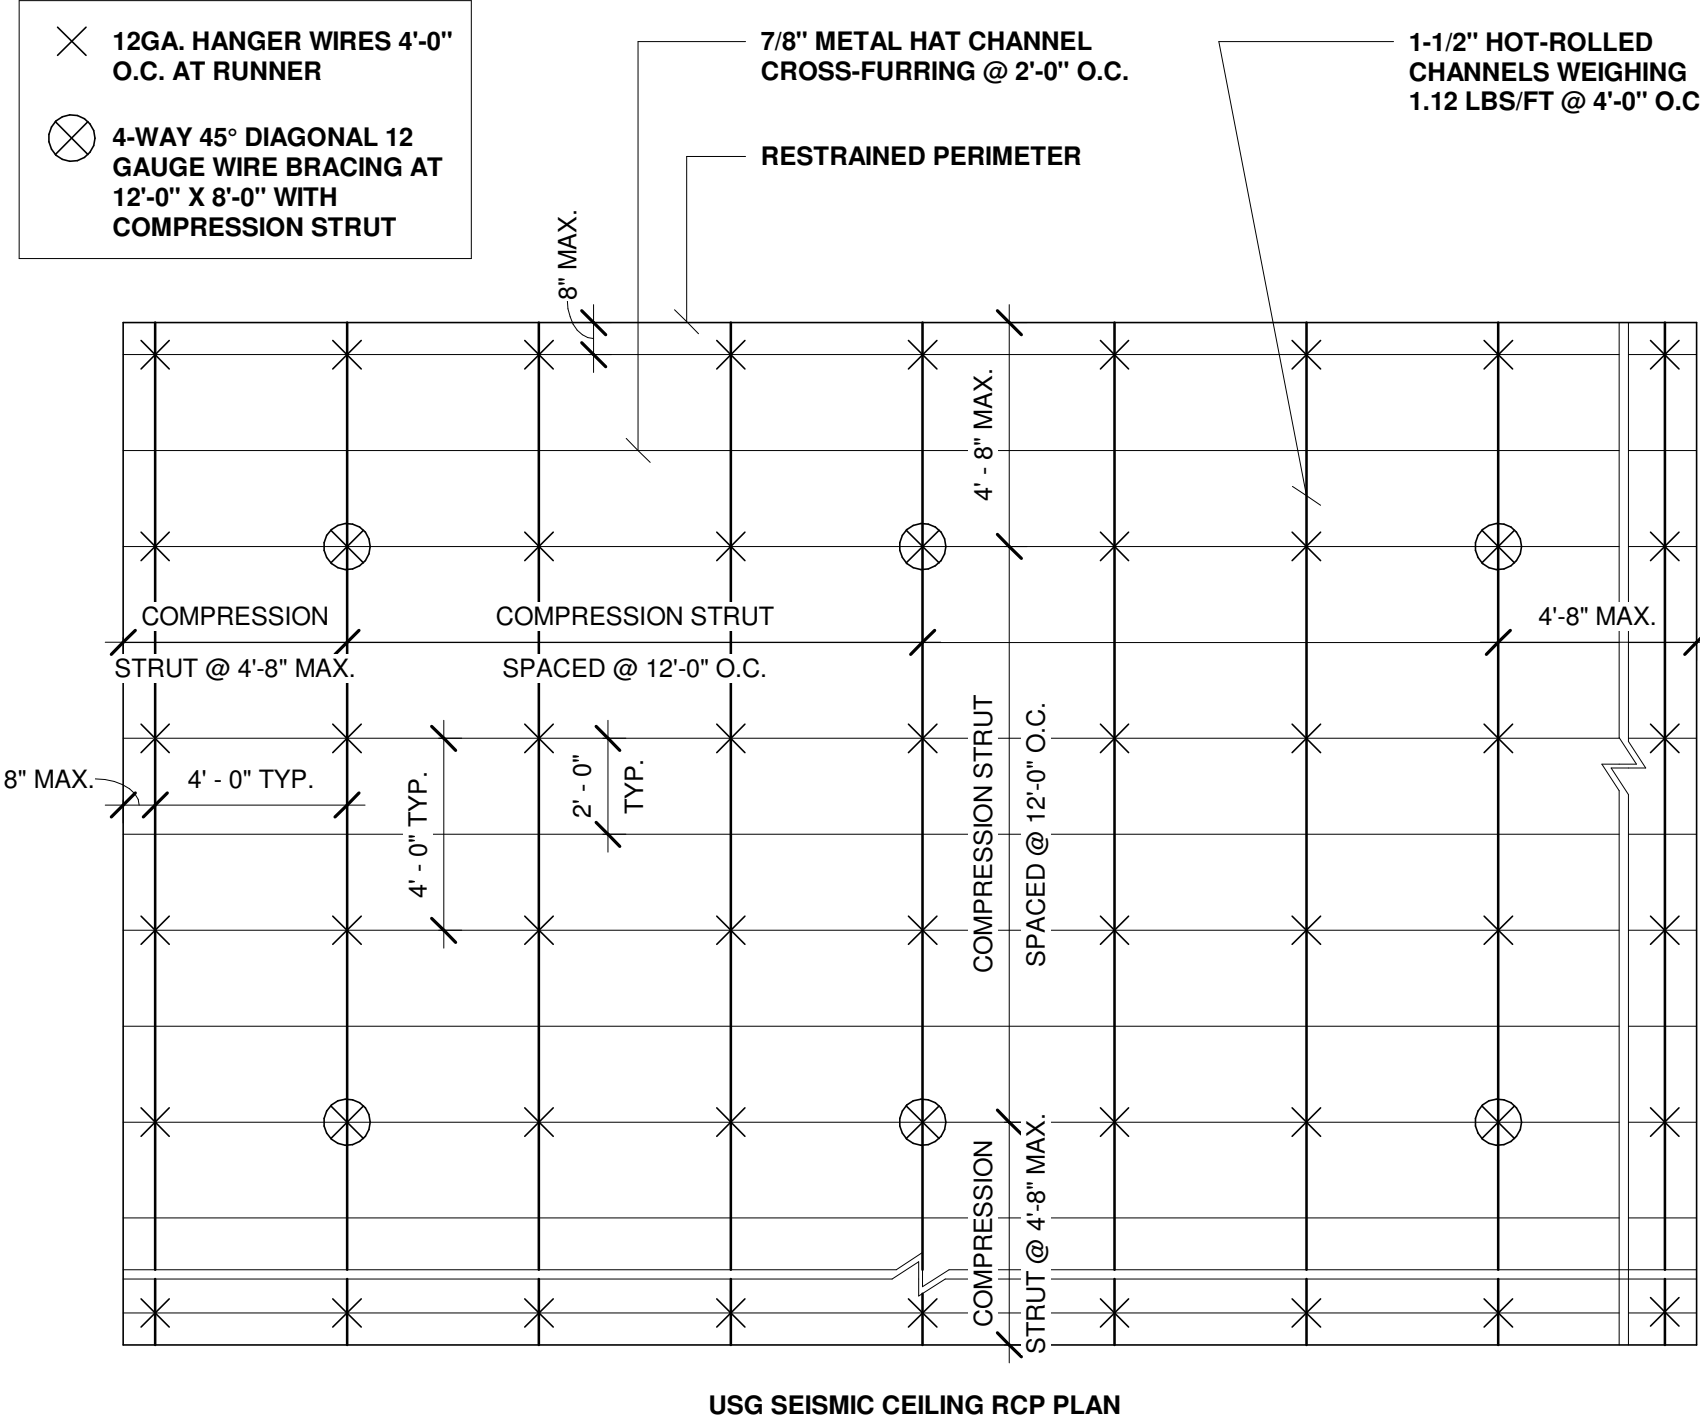




4 TYPICAL SEISMIC CEILING RCP PLAN LAYOUT
SCALE: 1/4" = 1'-0"

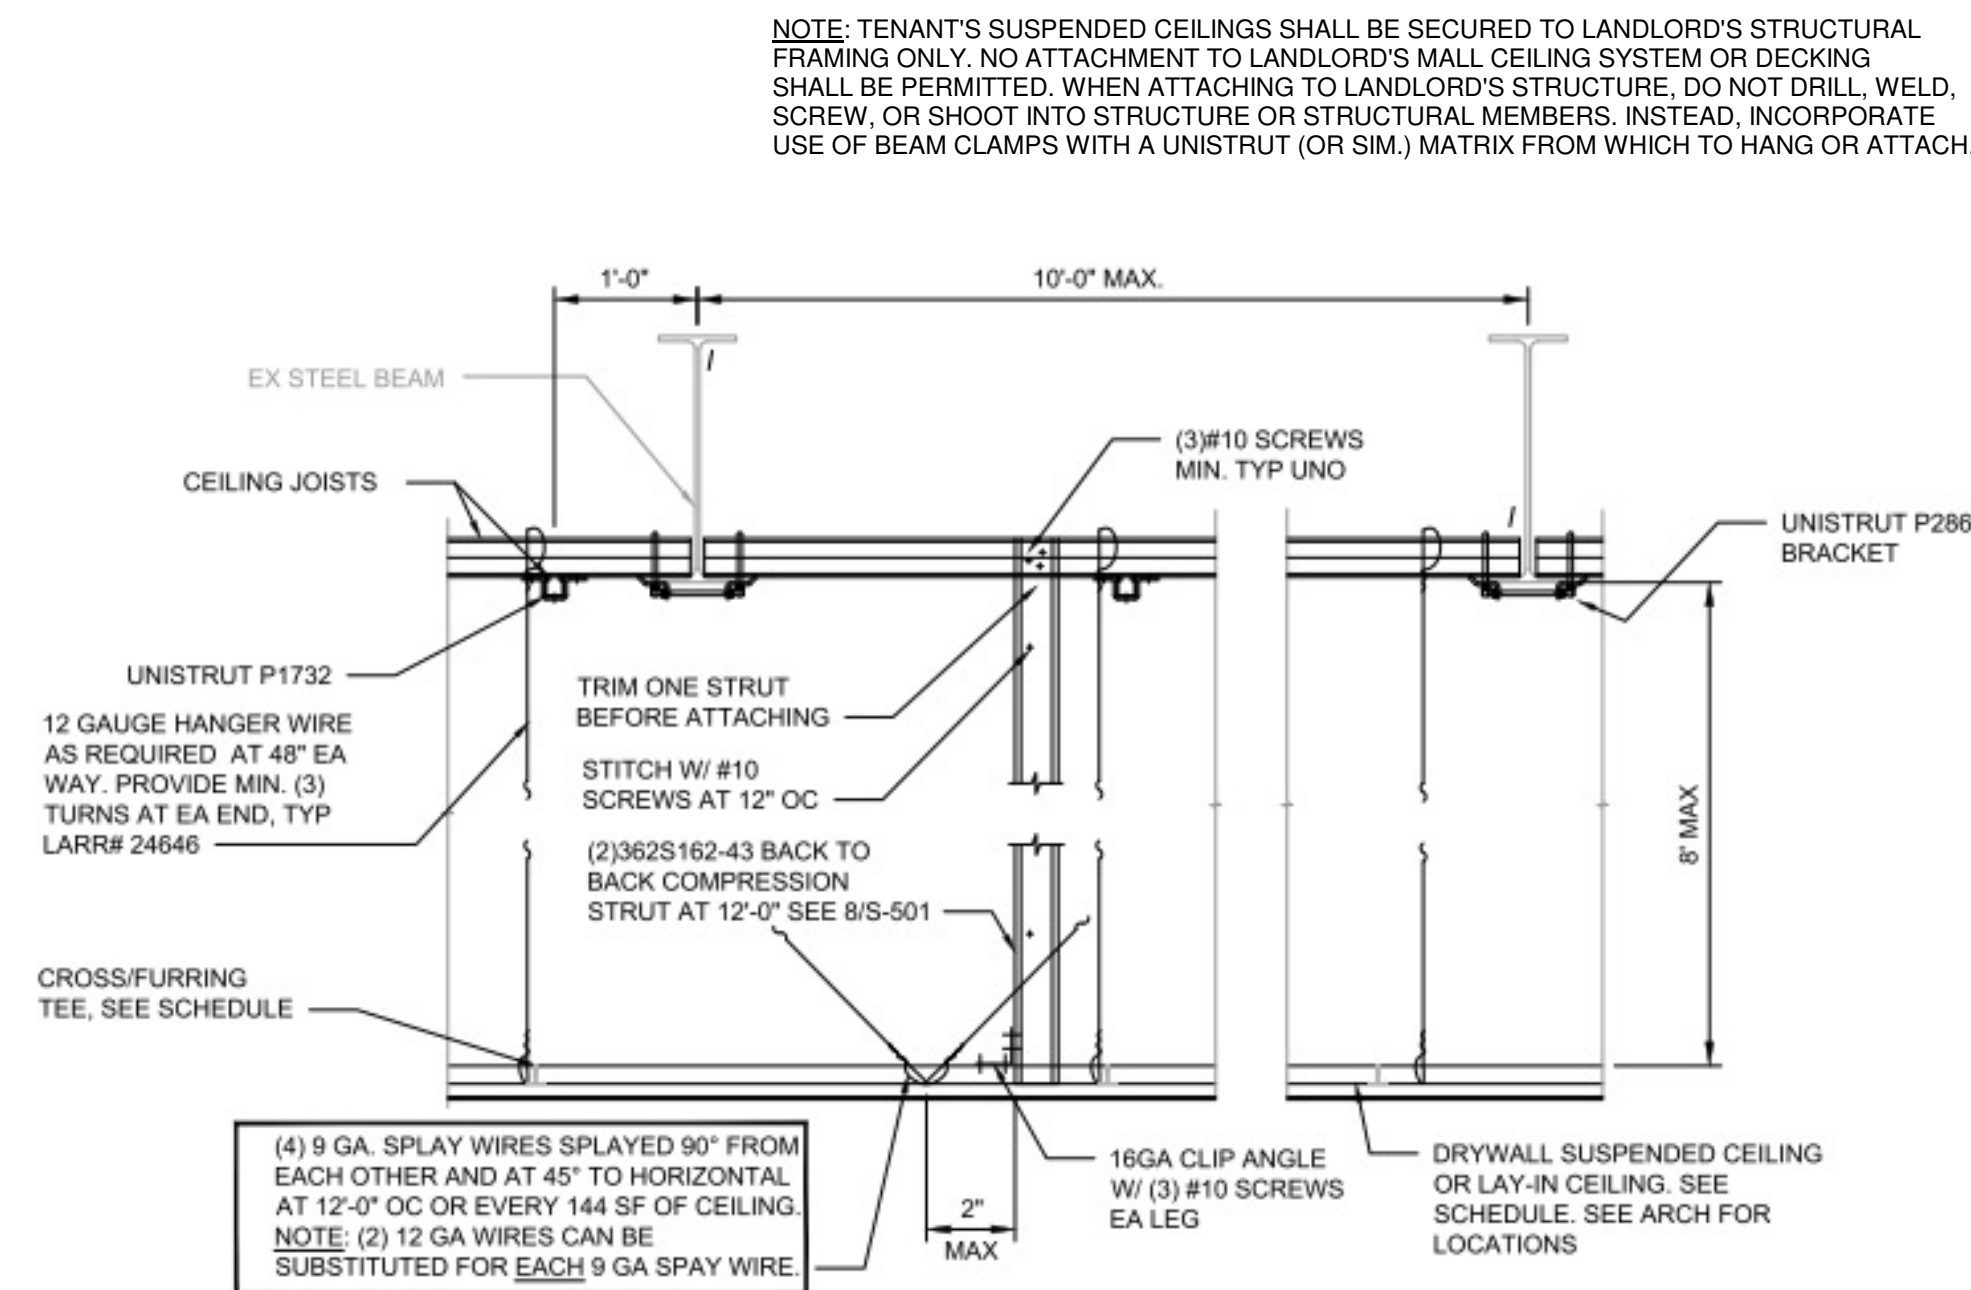

5 TYPICAL SUSPENDED GYP. CEILING
SCALE: 3" = 1'-0"

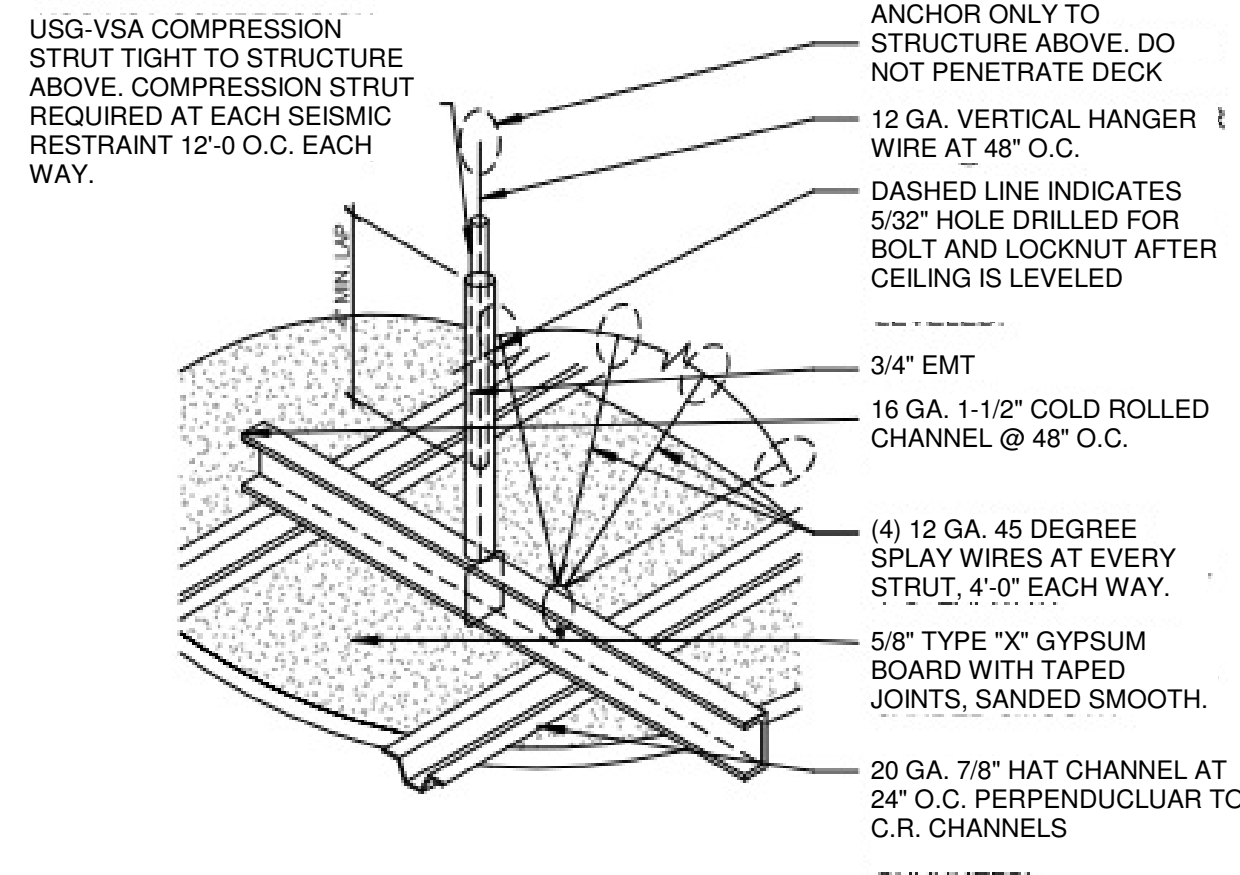

 6 COMPRESSION STRUT DETAIL AT GYP. CEILING
SCALE: 1/4" = 1'-0"

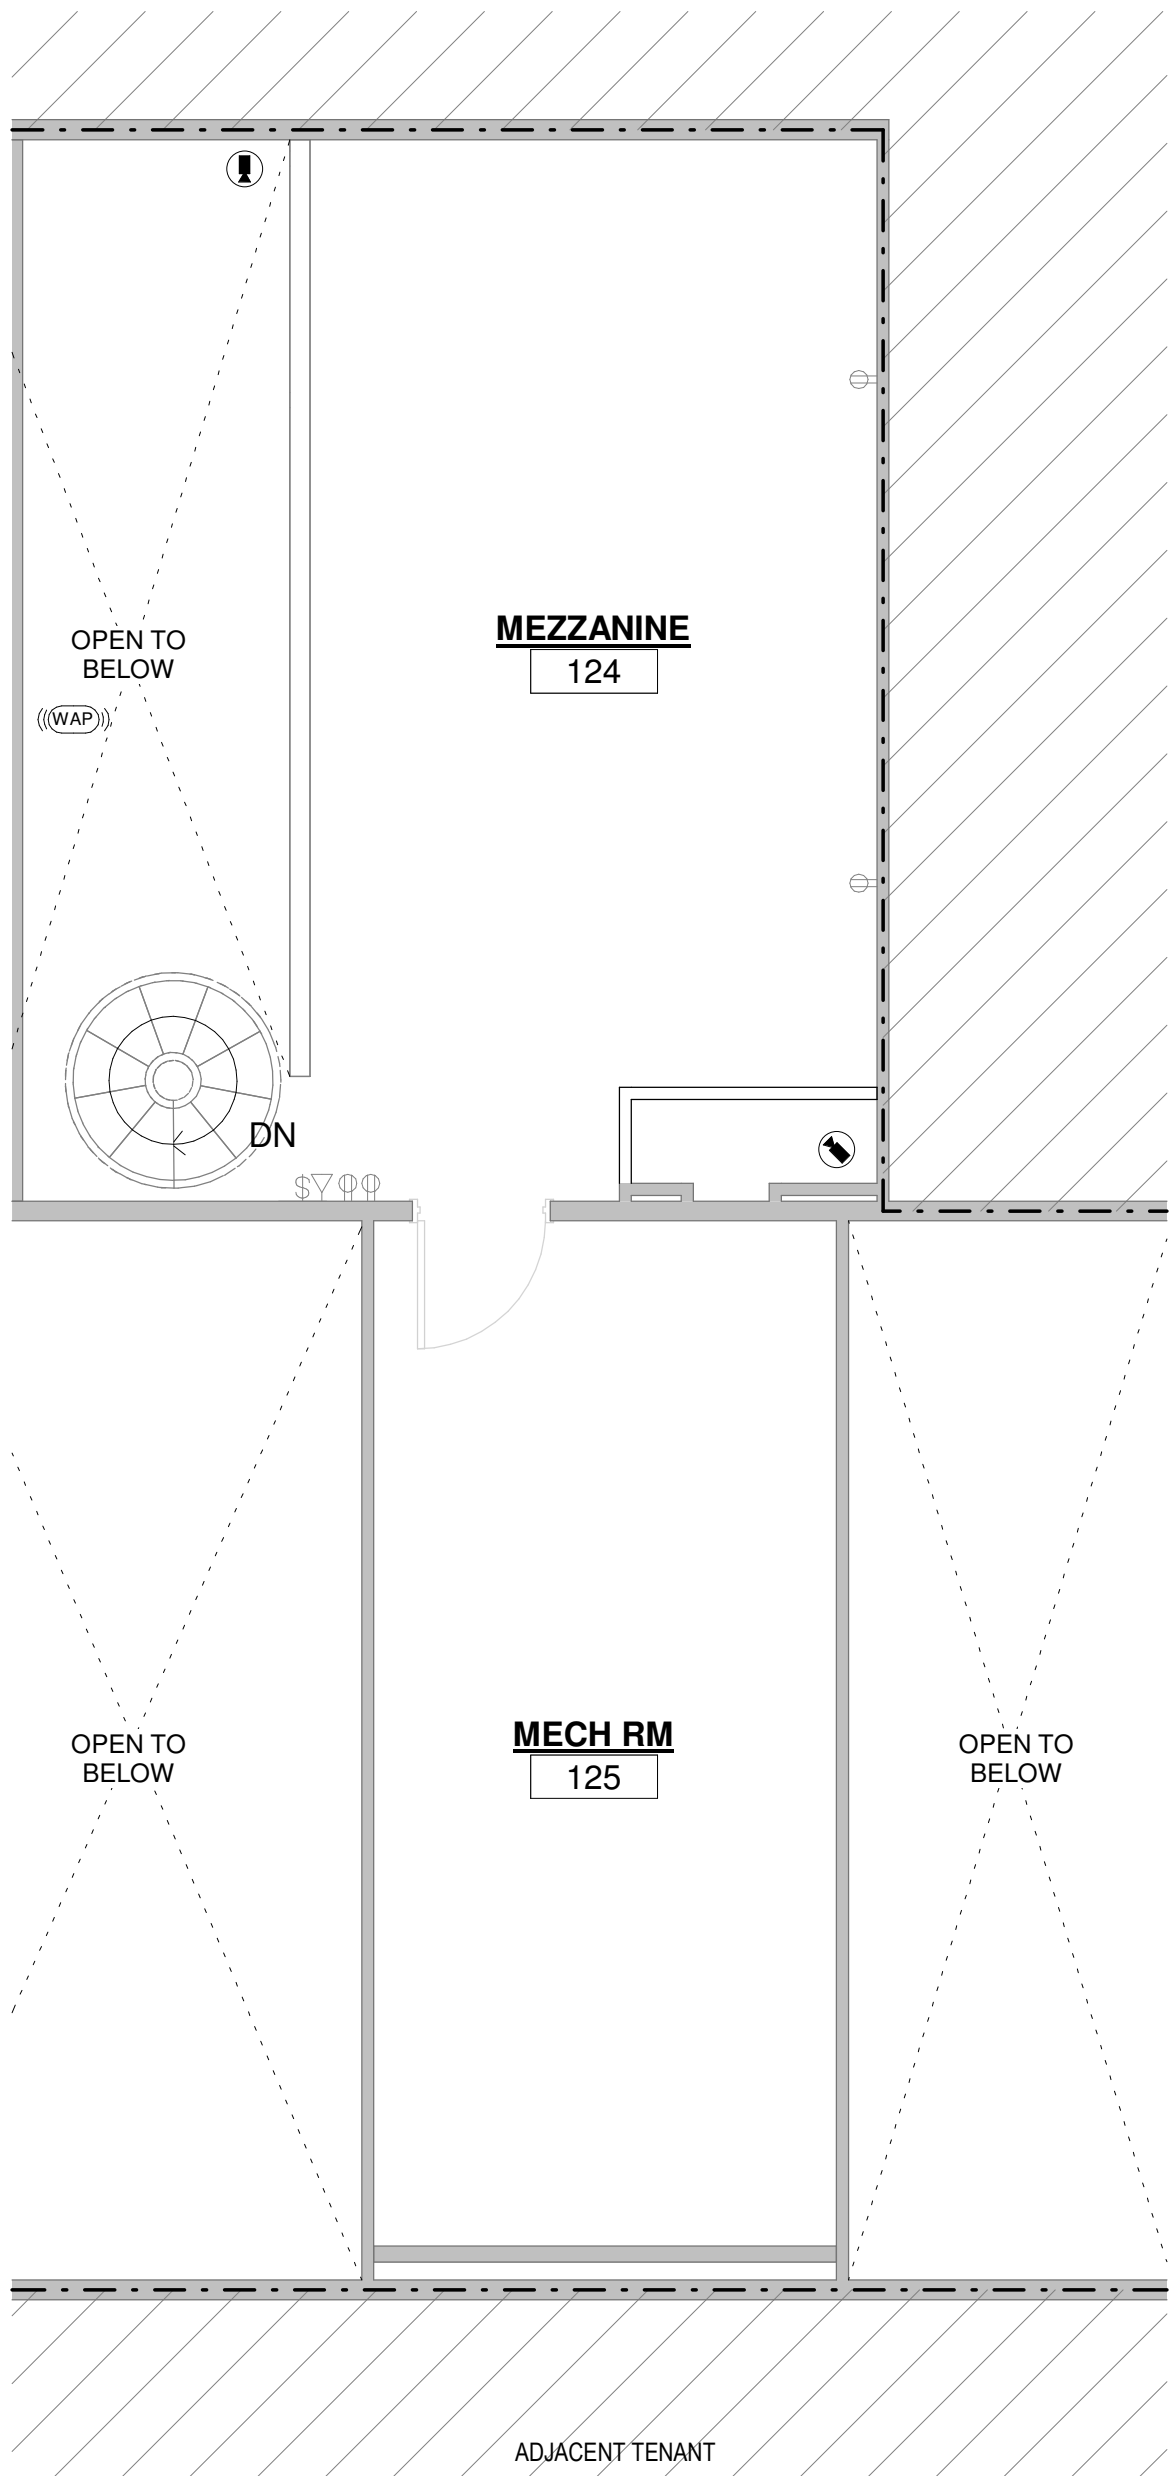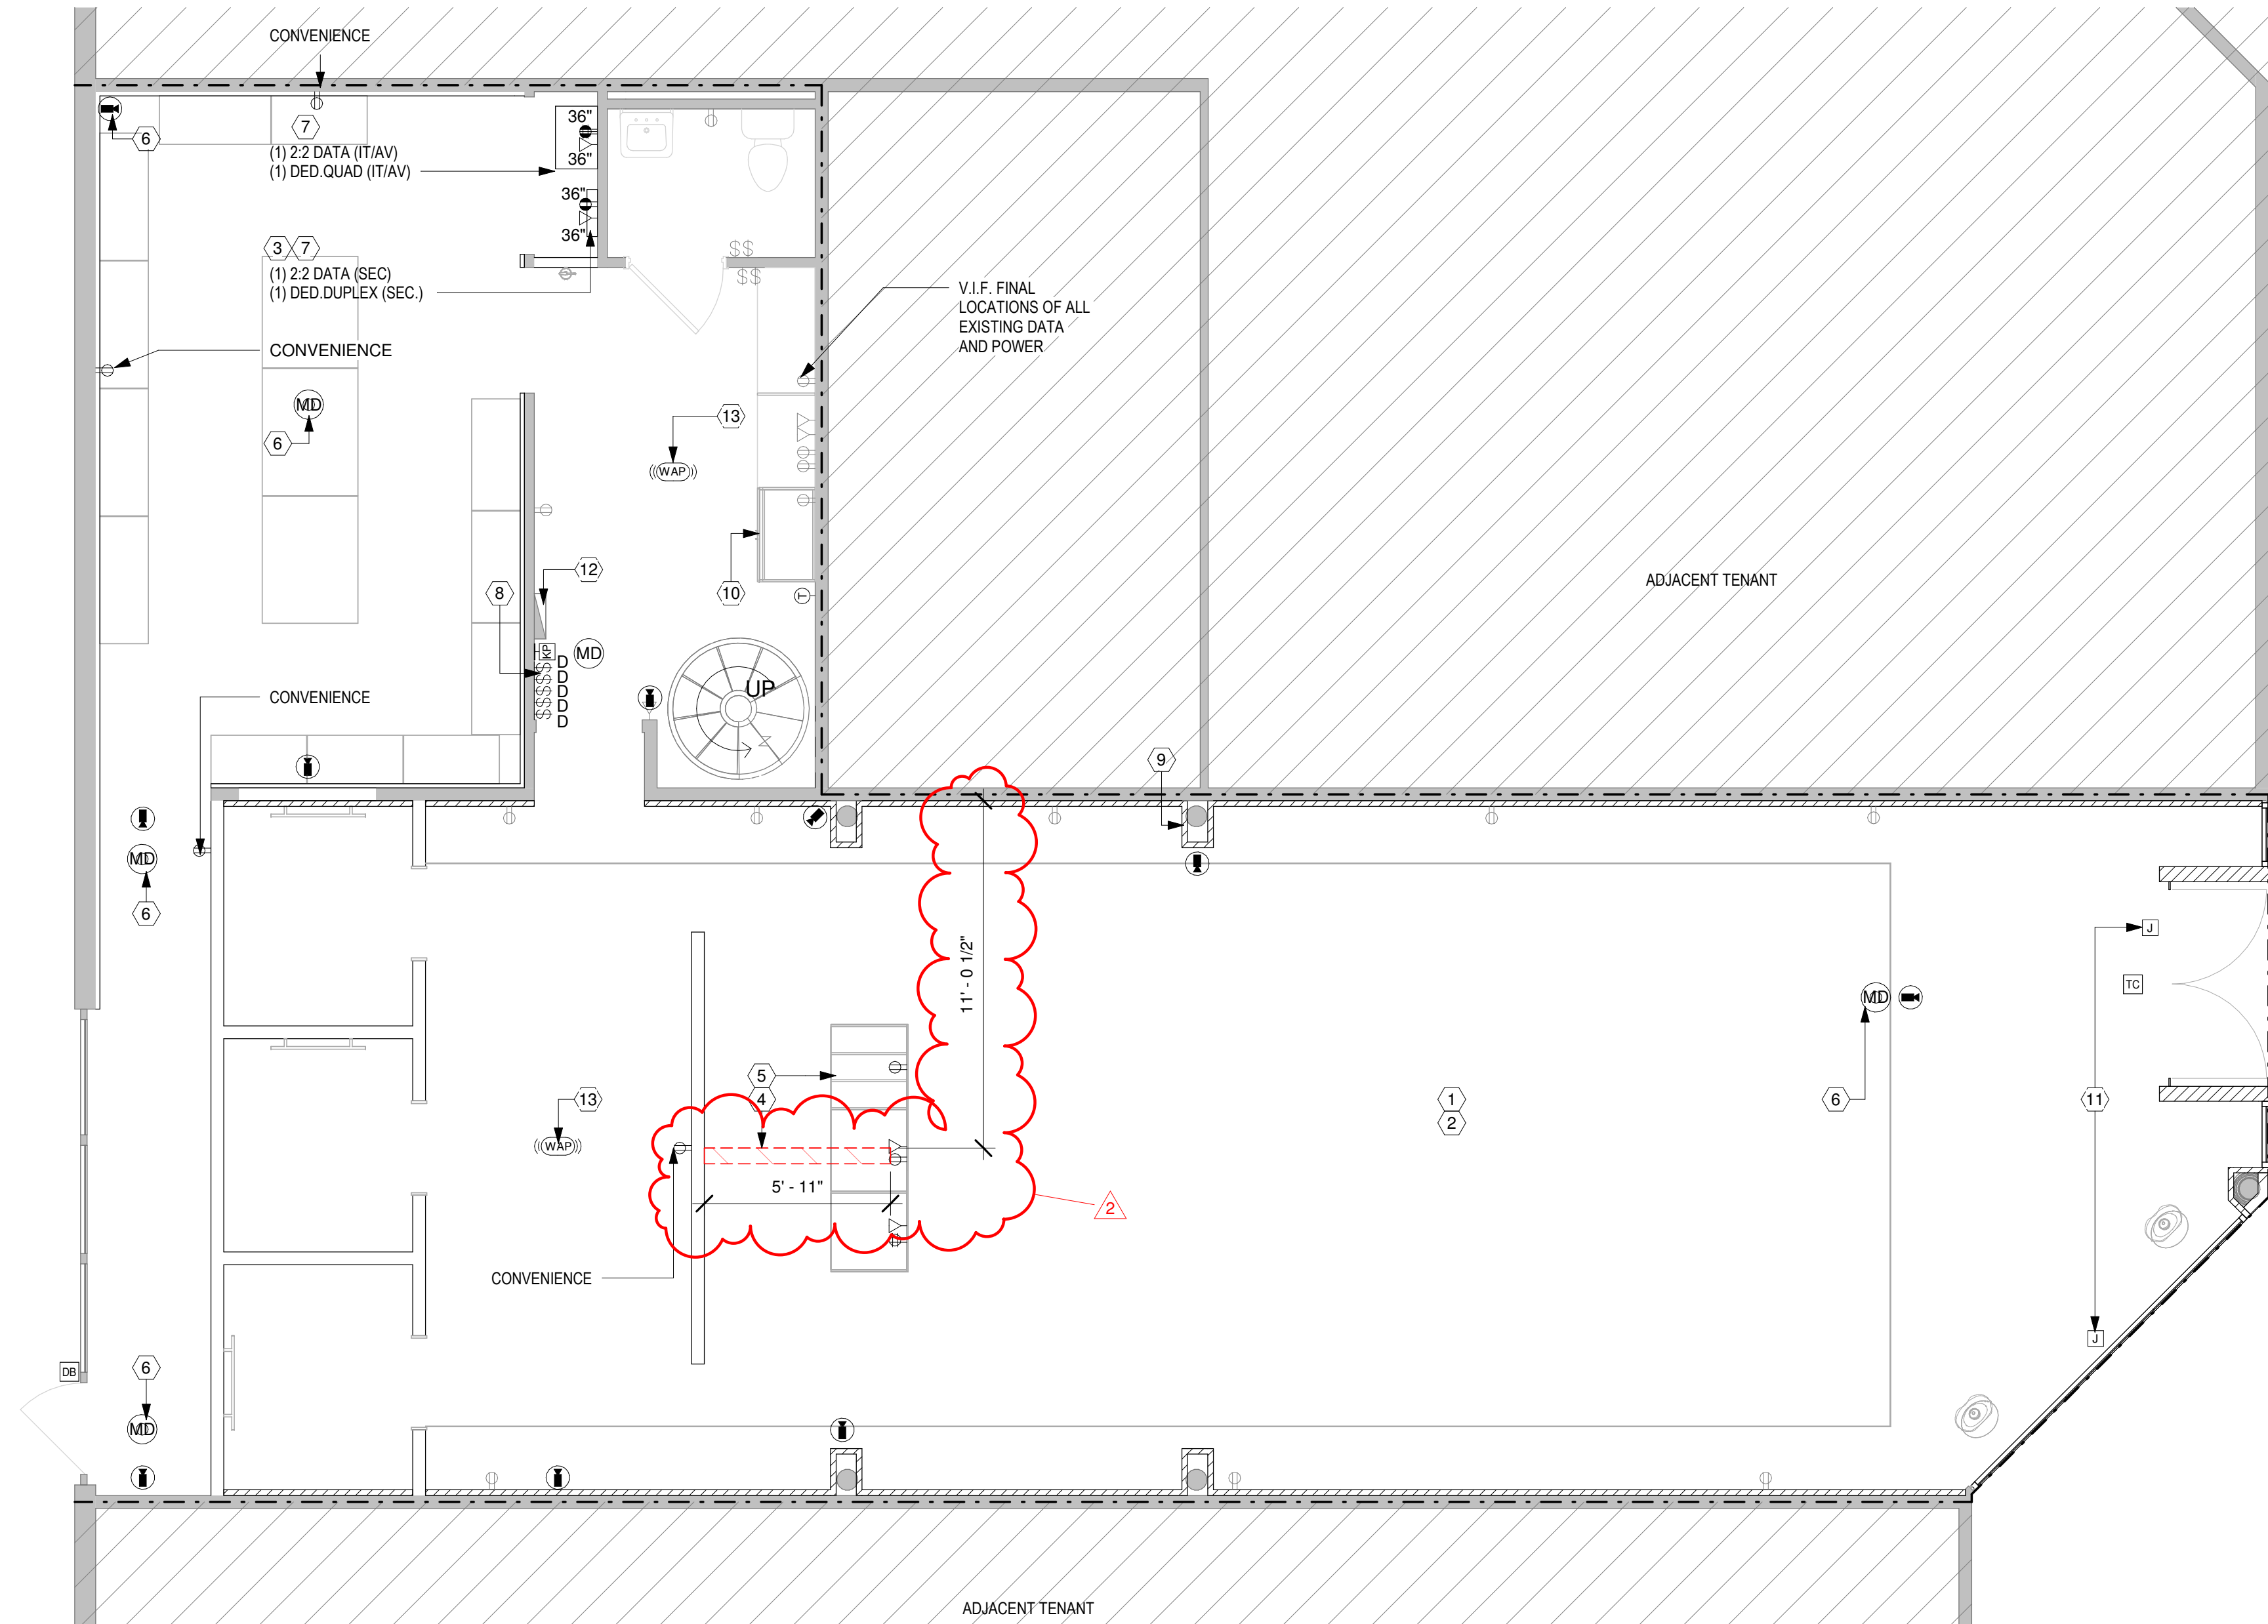

2 MEZZANINE POWER PLAN

SCALE: 1/4" = 1'-0"

LANDLORD POWER AND SIGNAL PLAN NOTES

- ALL WIRING INCLUDING LOW VOLTAGE MUST BE CONCEALED IN CONDUIT, TYP.
- CONDUIT/WIRING/ETC. MUST BE COMPLETELY CONCEALED WITHIN WALL OR MILLWORK - CANNOT BE VISIBLE, TYP.
- ALL ELECTRICAL OUTLETS MUST BE CONCEALED BY FURNITURE, FIXTURES, ETC. - CANNOT BE VISIBLE, TYP.
- MILLWORK LIGHTING MUST BE CONCEALED, TYP.
- TRANSFORMER MUST BE FLOOR SUPPORTED - TRANSFORMER MAY NOT BE HUNG OR SUSPENDED FROM STRUCTURE, TYP.
- IF ELECTRONIC SURVEILLANCE OR ANY KIND OF ANTITHEFT DETECTION EQUIPMENT IS DESIRED BY TENANT, EVERY COMPONENT OF THE SYSTEM IS REQUIRED TO BE COMPLETELY CONCEALED FROM SALES AREA, TYP.

POWER AND SIGNAL PLAN NOTES

- SEE ENGINEER'S DRAWING FOR ALL CIRCUITING AND RELATED WORK.
- GC SHALL VERIFY THE AVAILABLE ELECTRIC SERVICE IN THE TENANT'S SPACE & ADVISE THE ENGINEER OF HIS FINDINGS PRIOR TO SUBMITTING A BID.
- ALL BACK-TO-BACK OUTLETS IN ADJOINING ROOMS TO BE STAGGERED.
- ALL WALL OUTLET COVER PLATES AND SWITCH PLATES TO BE DECORA SNAP ON SCREWLESS PLATES (OR APPROVED EQUAL SCREWLESS SNAP-ON PLATES) IN COLOR TO MATCH ADJACENT FINISH U.O.N. WHITE STANDARD.
- ALL NEW TELEPHONE AND ELECTRICAL OUTLETS TO BE INSTALLED ON AN EXISTING WALL SHOULD BE FLUSH MOUNTED WITH THE FINISHED WALL SURFACE. CHOP OUT THE WALL AS REQUIRED TO RECESS THE J-BOX AND CONDUIT, AND PATCH THE WALL AS REQUIRED.
- ALL EXISTING ELECTRICAL OUTLETS TO BE DISCONNECTED AND CAPPED SHALL HAVE THE ELECTRICAL DEVICE AND ALL ASSOCIATED WIRING REMOVED. PATCH HOLE AS REQUIRED.
- GENERAL CONTRACTOR SHALL REMOVE ALL UNUSED CONDUIT, COAXIAL CABLE AND TELEPHONE WIRING COMPLETELY FROM AREAS IN SCOPE OF THIS CONTRACT.
- GENERAL CONTRACTOR SHALL BE RESPONSIBLE FOR ALL WORK NECESSARY TO COMPLETE CORE DRILLING AND ELECTRICAL HOOK-UP, PATCHING, ETC., INCLUDING WORK IN LANDLORD'S OR OTHER TENANT'S SPACE. ALL CORE DRILLING SHALL BE ACCOMPLISHED DURING CITY APPROVED WORKING HOURS. CONTRACTOR SHALL VERIFY AND CONFORM TO THOSE HOURS WHEN WORK IS REQUIRED.
- SHOULD JOB CONDITIONS REQUIRE RELOCATION OF PLANNED TELEPHONE OR ELECTRICAL OUTLETS FOR ANY REASON, THE CONTRACTOR SHALL NOTIFY THE ARCHITECT FOR APPROVAL OF ALTERNATE LOCATION PRIOR TO THE START OF ANY WORK.
- ALL EXISTING WALL OUTLETS WHICH DO NOT INTERFERE WITH NEW CONSTRUCTION SHALL REMAIN, UNLESS OTHERWISE NOTED.
- ANY EXISTING FIRE ALARM SOUNDERS OR PULL BOXES WHICH INTERFERE WITH NEW PARTITION WORK SHALL BE RELOCATED TO AN APPROVED LOCATION BY ARCHITECT.

1 POWER & SIGNAL

SCALE: 1/4" = 1'-0"

POWER AND SIGNAL SYMBOL LEGEND

SYMBOL	DESCRIPTION	SYMBOL	DESCRIPTION
	RECESSED CEILING SPEAKER, SPEC. BOSE VIRTUALLY INVISIBLE 791 SERIES II OR APPROVED EQUAL, EACH WIRED BACK TO A/V RACK. GC TO PROVIDE ARCHITECT WITH SUBMITTAL FOR APPROVAL.		CEILING DATA CONNECTION WAP = WIRELESS ACCESS POINT DEVICE STR = SHOPPER TRACK DEVICE RUN 2 CABLES (ONE ACTIVE, ONE SPARE) TO IT RACK, EACH TERMINATED INTO A PORT AT PATCH PANEL. EACH CABLE TO HAVE A RJ45 MALE CONNECTOR ON EACH END. LEAVE (1) 24" COILED CABLE POKED-THRU CEILING AT DEVICE LOCATION FOR FINAL VENDOR CONNECTION. SPARE CABLE CAN REMAIN COILED ABOVE CEILING.
	WALL LIGHTING CONTROL SWITCH. ROOM NAMES SHOWN TO INDICATE SWITCH CONTROL. (D) INDICATES DIMMER.		THERMOSTAT REMOTE SENSOR @ 48" AFF
	WALL LIGHTING CONTROL SWITCH BANK. QUANTITY OF SWITCHES BASED ON ZONES. REFER TO ELECTRICAL DWGS.		THERMOSTAT CONTROL @ 48" AFF
	WALL DUPLEX OUTLET, WHITE FINISH. ALL OUTLETS IN CUSTOMER FACING AREAS TO RECEIVE LEVITON DECORA WHITE SCREWLESS SNAP-ON FACEPLATE.		CEILING MOUNTED SECURITY DOME CAMERA SYSTEM
	DEDICATED (20 AMP) RECESSED WALL DUPLEX GROUND FAULT CURRENT INTERRUPTER OUTLET		SECURITY KEYPAD
	CEILING DUPLEX OUTLET, WHITE FINISH.		ELECTRIC DOOR STRIKE (BY GC) & CARD READER (DEVICE PROVIDED BY SECURITY VENDOR)
	WALL QUAD OUTLET, WHITE FINISH.		WIRELESS SECURITY GLASS BREAK AUDIO SENSOR
	FULLY RECESSED DUPLEX OUTLET, 4" ROUND POKE-THRU FLOOR BOX, WITH FLUSH TO FLOOR COVER PLATE. BRUSHED NICKEL FINISH.		DOOR BELL
	NEW JUNCTION BOX LOCATED ABOVE FINISHED CEILING NEAR CEILING ACCESS PANEL OR ABOVE ACT.		SECURITY DOOR CONTACT
	NEW WALL JUNCTION BOX LOCATED BEHIND WALL ACCESS PANEL OR SURFACE MOUNTED.		WALL MOUNTED SECURITY MOTION DETECTOR
	(1) 22/4 SHIELD AUDIO CABLE RUN FROM WALL MOUNTED ipad @ 48" AFF TO A/V RACK. PROVIDE SINGLE GANG BRUSH WALL PLATE FOR CABLE PASS-THRU.		CEILING MOUNTED SECURITY MOTION DETECTOR
	DATA CONNECTION IN A 1, 2 OR 4 PORT WALL PLATE. THE FIRST # IN SEQUENCE (#) IS THE QUANTITY OF FEMALE RJ45 PORTS AT WALL PLATE. THE SECOND # IN SEQUENCE (#) IS THE QUANTITY OF CAT6 CABLE(S) RUN TO IT RACK. TERMINATED INTO PATCH A PANEL PORT. EACH CABLE TO HAVE A RJ45 MALE CONNECTOR ON EACH END.		SECURITY PANIC BUTTON
	FIRE ALARM MANUAL PULL STATION - WALL MOUNTED		FIRE ALARM STROBE - WALL MOUNTED/CEILING MOUNTED
	FIRE ALARM ANNUNCIATOR PANEL		DOORBELL CHIME
	FLOOR DATA OUTLET (SINGLE JACK), INCORPORATE INTO SAME POKE-THRU BOX AS FOR ELECTRICAL OUTLET.		

POWER & SIGNAL PLAN KEY NOTES (#)

- NEW SECURITY CAMERA SYSTEM AND SECURITY BURGLAR DEVICE LAYOUT SUPPLIED BY OWNER'S VENDOR. VENDOR TO PROVIDE ALL EQUIPMENT AND COMPONENTS AS SPECIFIED IN VENDOR SHOP DRAWINGS. FINAL DEVICE INSTALL AND CONNECTION BY VENDOR. VENDOR TO SUPPLY WIRE/CABLE, GC TO PULL ALL WIRES/CABLES TO DEVICE LOCATIONS PER FINAL APPROVED VENDOR PLANS. GC TO CONFIRM ALL LOCATIONS WITH VENDOR PRIOR TO STARTING WORK.
- NEW AUDIO SYSTEM AND CEILING RECESSED SPEAKERS SUPPLIED BY OWNER & GC. GC TO PROVIDE SPEAKERS AND COMPONENTS AS SPECIFIED IN SCHEDULE. GC TO INSTALL AND TO SUPPLY AUDIO WIRE/CABLE, GC TO PULL ALL WIRES/CABLES TO SPEAKER LOCATIONS PER FINAL APPROVED PLANS.
- GC TO CHOP FLOOR AND RUN CONDUIT AS REQUIRED. ELECTRICAL AND TEL DATA LINES TO BE IN SEPARATE CONDUITS.
- CASH WRAP - 2 POS REQUIRED. POWER DATA PROVIDED AT CASH WRAP.
- CEILING MOUNTED MOTION DETECTOR.
- NEW 4X8 PLYWOOD FOR SECURITY & A/V IT PANEL MOUNTING. REFER TO ELECTRICAL DRAWINGS FOR MORE INFORMATION. GC TO ARRANGE EQUIPMENT ACCORDINGLY TO ACCOMMODATE NEW DOOR AND EQUIPMENT IN CLOSET.
- WALL MOUNTED LIGHTING MASTER SWITCHBANK AT 48" AFF, REFER TO ELECTRICAL DWGS. ALL SWITCHES TO BE DIMMERS U.O.N.
- THERMOSTAT SENSOR LOCATIONS TO BE FINALIZED BY ARCHITECT AND ENGINEER. SEND SUBMITTAL OF THERMOSTAT SENSOR SPEC FOR FINAL APPROVAL. THERMOSTATS TO BE LOCATED IN BOH CASHWRAP.
- EXISTING POWER & DATA RECEPTACLES FOR MANAGER'S DESK. GC TO CONFIRM FINAL POWER AND DATA IN FIELD. NOTIFY ARCHITECT OF ANY DISCREPANCIES.
- J-BOX FOR STOREFRONT LIGHTING DRIVERS. GC TO PROVIDE POWER/FINAL CONNECTIONS TO ALL LED DRIVERS. LOCATE J-BOX POWER AND LIGHTING DRIVERS AT ACCESS PANEL AS INDICATED. REFER TO VENDOR SHOP DWGS FOR QUANTITY OF DRIVERS AND FEED LOCATION. ALSO REFER TO INTERIOR ELEVATIONS.
- EXISTING ELECTRICAL PANEL TO REMAIN. PROTECT IN PLACE. HOLD REQUIRED CLEARANCE ACCESS.
- WIRELESS ACCESS POINT AT CEILING. GC TO PROVIDE (1) FEMALE PORT AT CEILING FOR FINAL DEVICE CONNECTION. RUN 2 CABLES (ONE ACTIVE, ONE SPARE) TO IT RACK. TERMINATED INTO 2 PORTS AT PATCH PANEL. WAP AND WIFI ANTENNAS MUST BE LOCATED ABOVE CEILING AND NOT VISIBLE IN SALES AREA.



45 WEST 21st STREET, SUITE 403
NEW YORK, NY 10010

IN ASSOCIATION WITH THE ARCHITECT:
R H SWEERS II, PROPRIETOR
R H SWEERS ARCHITECT

ALL DRAWINGS AND WRITTEN MATERIAL APPEARING HEREIN CONSTITUTE ORIGINAL AND UNPUBLISHED WORK OF THE ARCHITECT AND MAY NOT BE DUPLICATED, USED OR DISCLOSED WITHOUT WRITTEN CONSENT OF THE ARCHITECT. THIS DOCUMENT IS INTENDED SOLELY FOR THE CONSTRUCTION OF THE PROJECT NAMED HEREIN AND SHALL NOT BE USED BY ANY OTHER CONSTRUCTION WITHOUT WRITTEN CONSENT OF THE ARCHITECT.

THIS DRAWING WAS PREPARED UNDER MY SUPERVISION AND I DISCLAIM ANY RESPONSIBILITY FOR THE EXISTING BUILDING CONSTRUCTION ELEMENTS, SITE CONDITIONS, OR ANY DOCUMENTS WHICH DO NOT BEAR MY SEAL.

SEAL

ISSUE FOR BID

DRAWINGS ISSUED

No.	Rev	Date	Description
1		06.18.26	LL REVIEW SET
2		06.24.26	ISSUE FOR PERMIT
3		07.02.26	ISSUE FOR BID
5	2	08.27.26	BID ADDENDUM #2

PROJECT NAME:
TWP NAPLES

TWP

PROJECT ADDRESS:
WATERSIDE SHOPS
5455 TAMIAMI TRL N
NAPLES, FL 34108

DRAWING TITLE:
POWER & SIGNAL PLAN

SCALE: AS SHOWN

Project No.	26TWP05
Scale:	1/4" = 1'-0"
Date:	08-20-2026
Drawn By:	212
Checked By:	212
DRAWING NO:	

A-301



45 WEST 21st STREET, SUITE 403
NEW YORK, NY 10010

IN ASSOCIATION WITH THE ARCHITECT:
R H SWEERS II, PROPRIETOR
R H SWEERS ARCHITECT

ALL DRAWINGS AND WRITTEN MATERIAL APPEARING HEREIN
CONSTITUTE ORIGINAL AND UNPUBLISHED WORK OF THE
ARCHITECT AND MAY NOT BE DUPLICATED, USED OR DISCLOSED
WITHOUT WRITTEN
CONSENT OF THE ARCHITECT. THIS DOCUMENT IS INTENDED
SOLELY FOR THE CONSTRUCTION OF THE PROJECT NAMED HEREIN
AND SHALL NOT BE USED BY ANY OTHER CONSTRUCTION WITHOUT
WRITTEN CONSENT OF THE ARCHITECT.
THIS DRAWING WAS PREPARED UNDER MY SUPERVISION AND I
DISCLAIM ANY RESPONSIBILITY FOR THE EXISTING BUILDING
CONSTRUCTION ELEMENTS, SITE CONDITIONS, OR ANY DOCUMENTS
WHICH DO NOT BEAR MY SEAL.

SEAL

ISSUE FOR BID

DRAWINGS ISSUED

No.	Rev	Date	Description
1		06.18.26	LL REVIEW SET
2		06.24.26	ISSUE FOR PERMIT
3		07.02.26	ISSUE FOR BID
4	1	07.28.26	BID ADDENDUM #1
5	2	08.27.26	BID ADDENDUM #2

PROJECT NAME:
TWP NAPLES

TWP




PROJECT ADDRESS:
WATERSIDE SHOPS
5455 TAMIAMI TRL N
NAPLES, FL 34108

DRAWING TITLE:
WALL FINISH PLAN

SCALE: AS SHOWN

Project No.	26TWP05
Scale:	1/4" = 1'-0"
Date:	08-20-2026
Drawn By:	212
Checked By:	212
DRAWING NO:	

 A-401

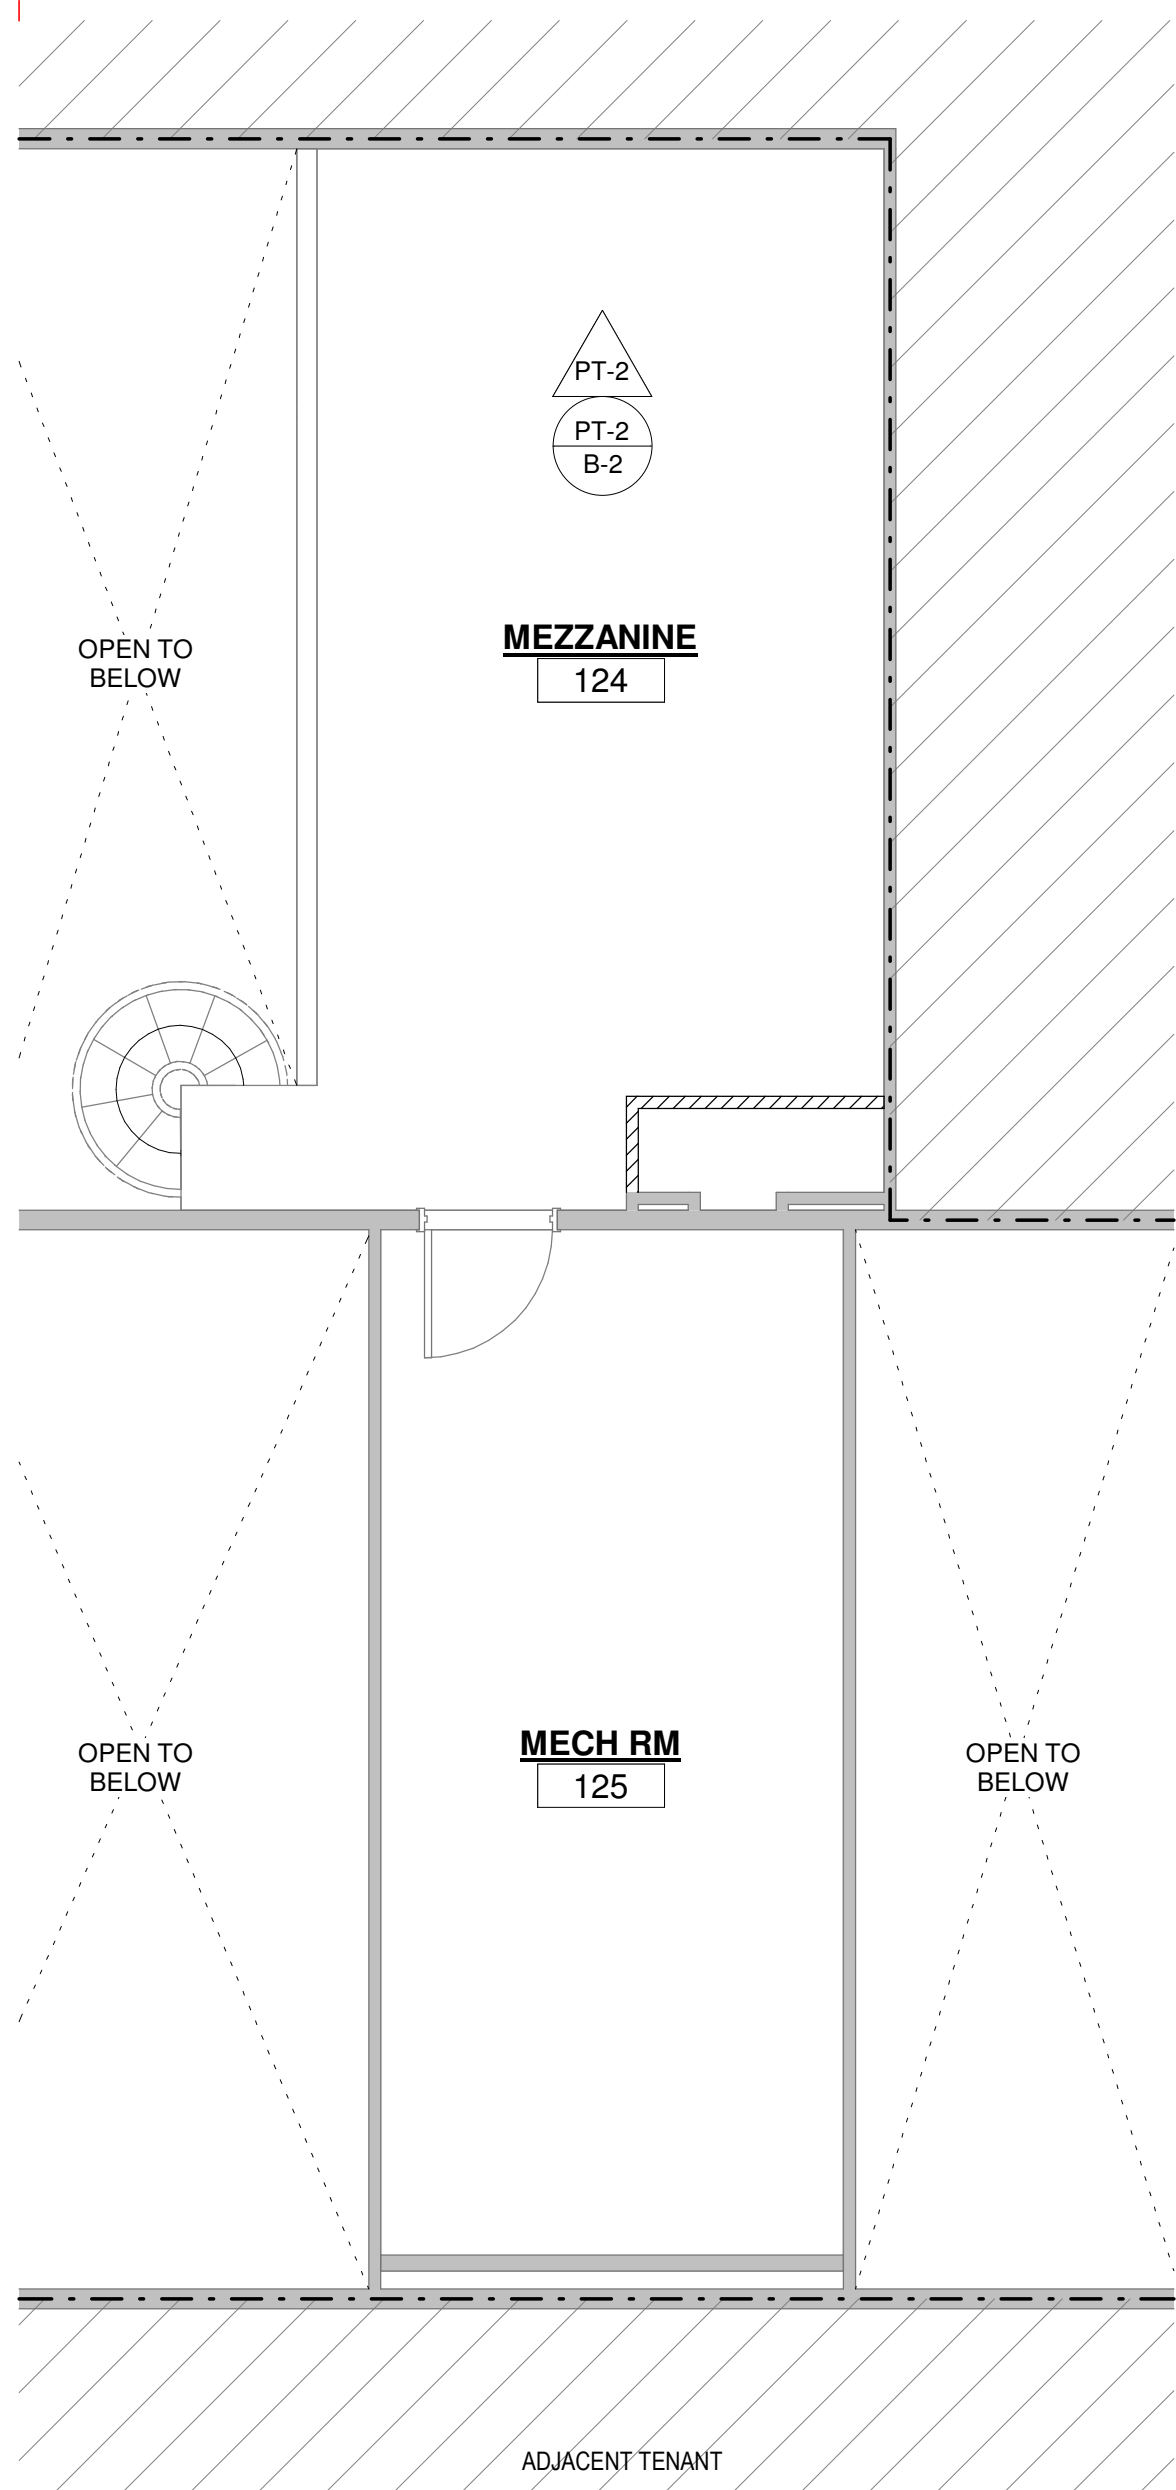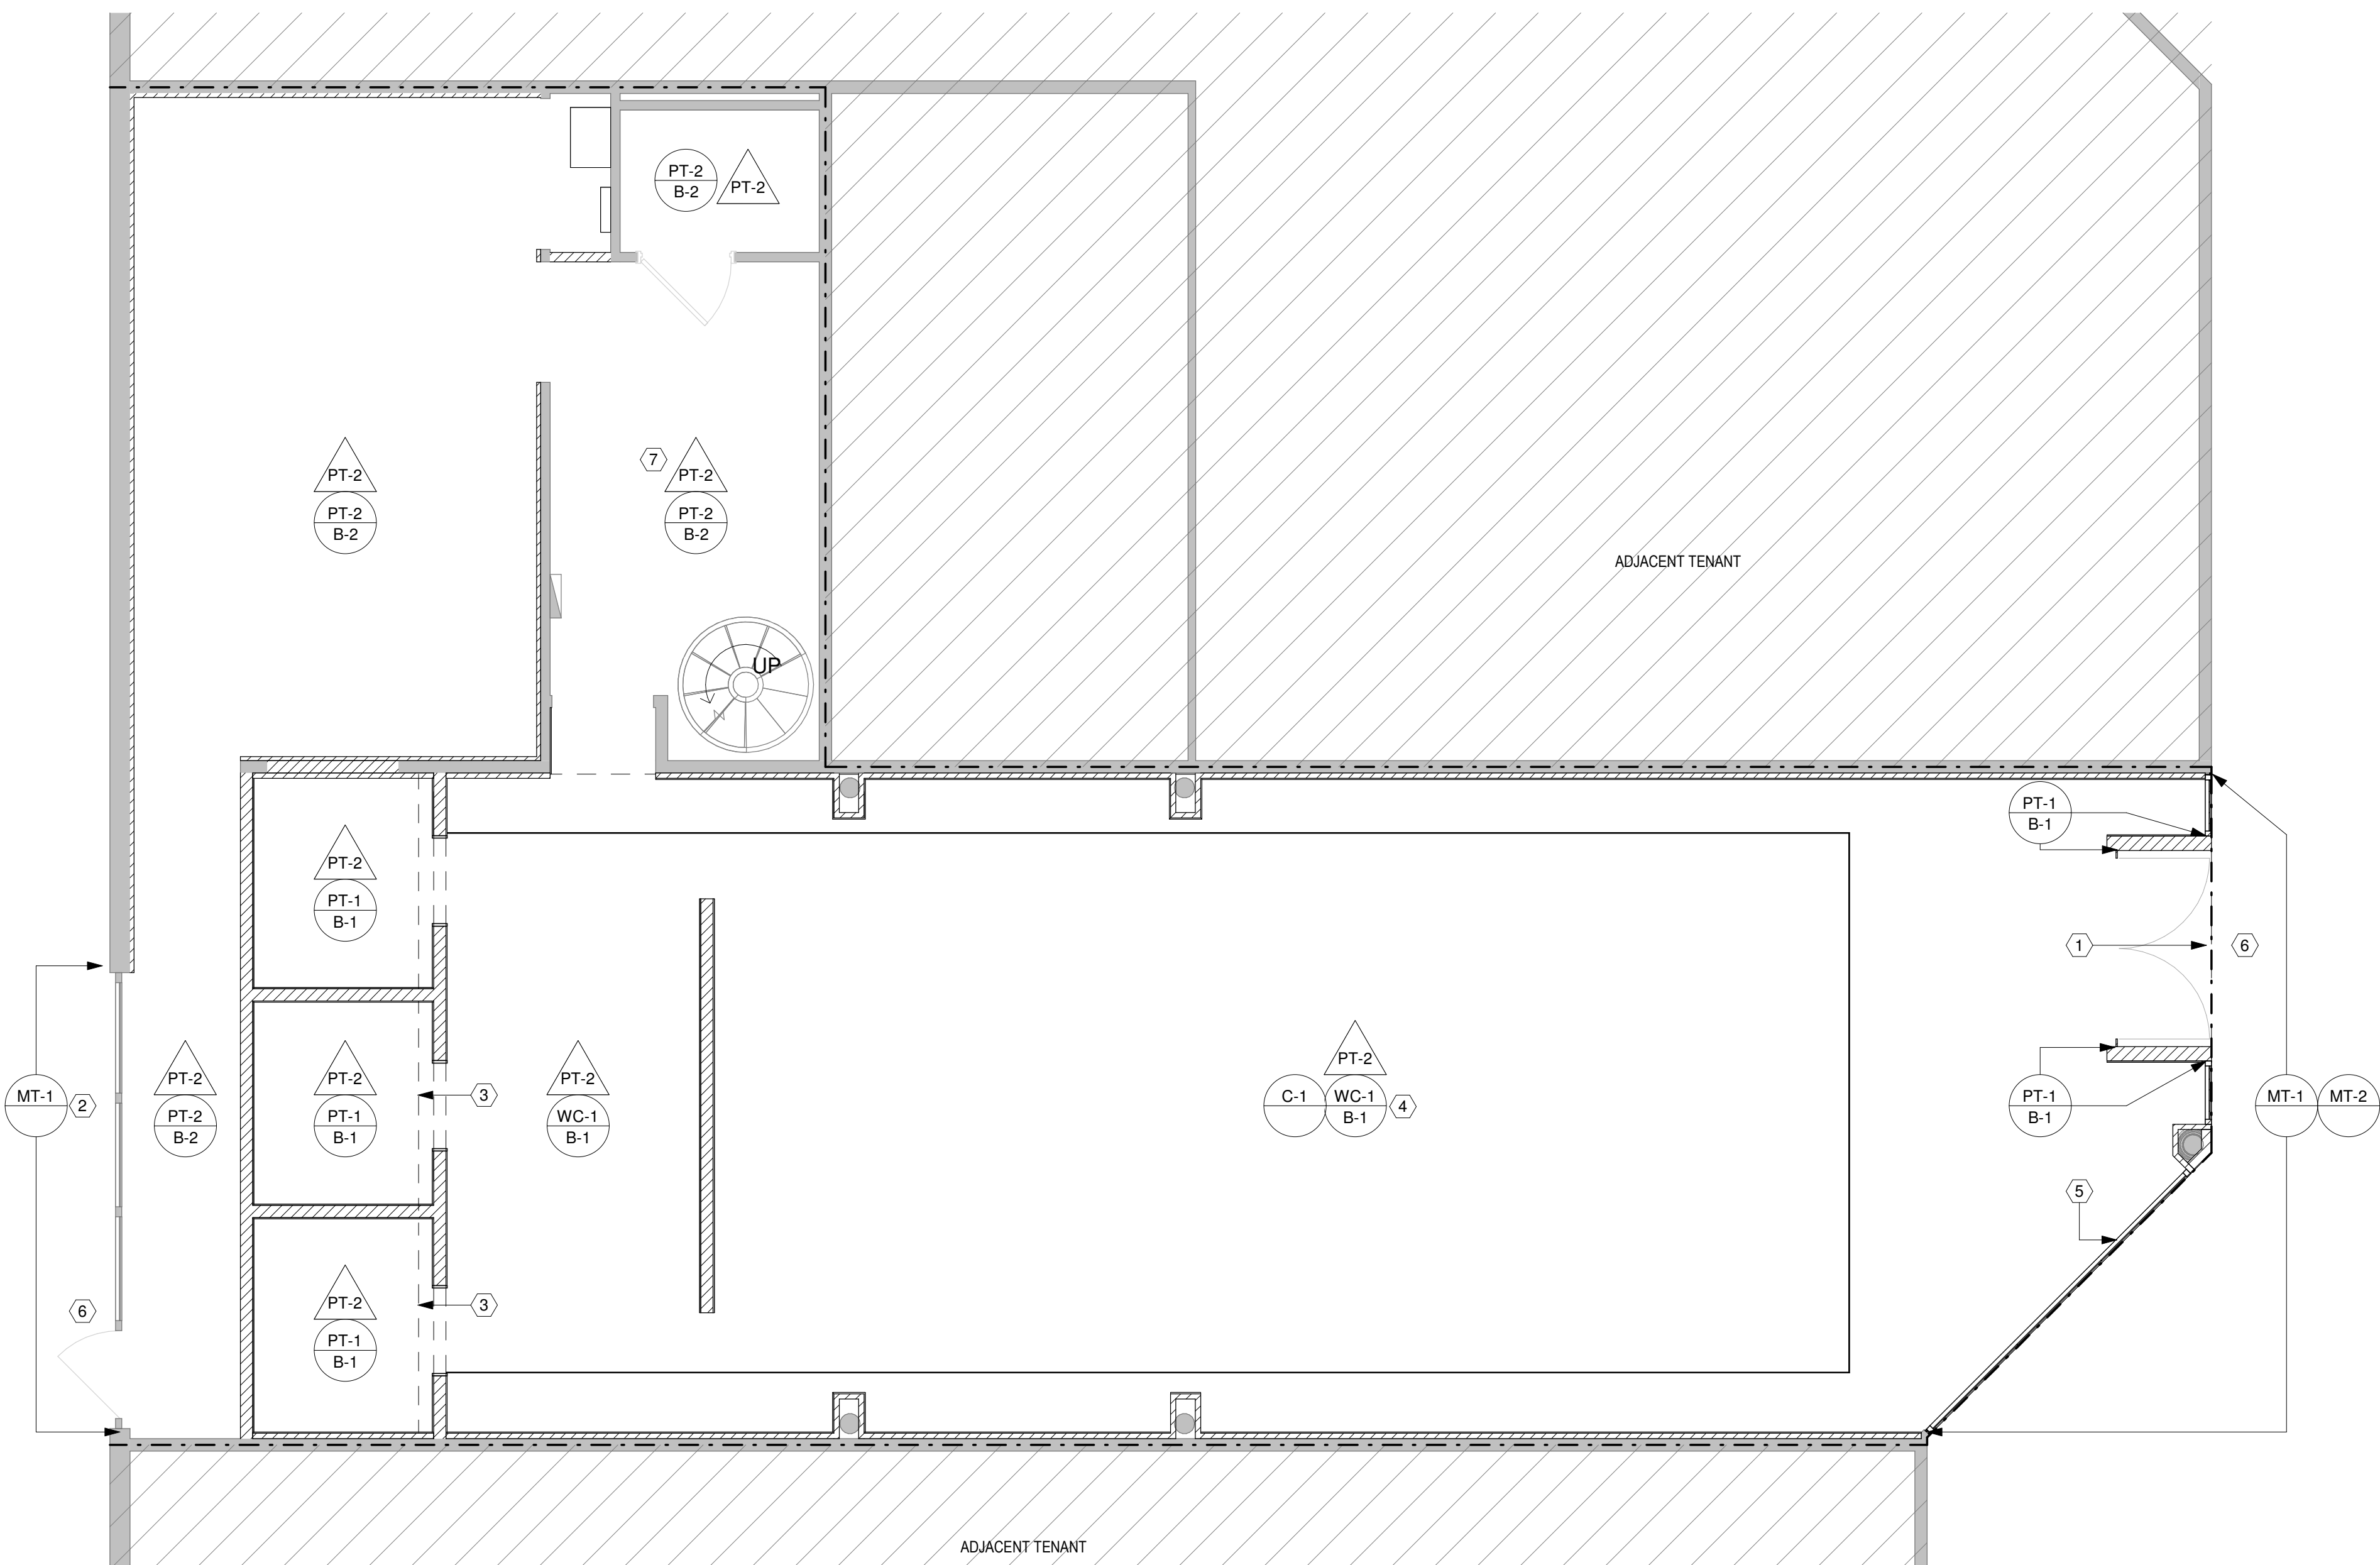

2 MEZZANINE FINISH PLAN
SCALE: 1/4" = 1'-0"

1 WALL FINISH PLAN
SCALE: 1/4" = 1'-0"

WALL & CEILING FINISH PLAN LEGEND (GC TO PROVIDE MATERIAL SAMPLES FOR ARCHITECT APPROVAL)

SYMBOL	DESCRIPTION	PROVIDE / INSTALL	SYMBOL	DESCRIPTION	PROVIDE / INSTALL
	SALES WALL FINISH FULL HEIGHT WALL PANELING MANUFACTURER: ELITE TRIM WORKS MODEL NAME: STANDARD BEAD MODEL NUMBER: SB-MDF-SH-4-10-12-3 COLOR: PAINTED WITH PT-1 BENJAMIN MOORE DOVE WING OC-18 LOCATION: THROUGHOUT ENTIRE SALES NOTE: FOLLOW MANUFACTURER'S INSTRUCTIONS FOR INSTALL	GC / GC		BASE FINISH: BENJAMIN MOORE DOVE WING OC-18 LOCATION: SALES FRONT OF HOUSE THROUGHOUT NOTE: STANDARD BASE THROUGHOUT, APPLY OVER WC-1	GC / GC
	SELECT WALLS ON SALES AS INDICATED MANUFACTURER: BENJAMIN MOORE FINISH: SATIN COLOR: DOVE WING OC-18 LOCATION: FITTING ROOMS NOTE: LEVEL 5 FINISH U.O.N. - SATIN FINISH. GC TO PROVIDE SUBMITTAL FOR APPROVAL.	GC / GC		BASE MANUFACTURER: ROPPE MODEL NAME: VINYL WALL BASE COLOR: MELTED BRONZE LOCATION: IN BOH NOTE: VINYL COVE BASE THROUGHOUT BOH	GC / GC
	WHITE PAINT THROUGHOUT MANUFACTURER: SHERWIN WILLIAMS FINISH: MATTE COLOR: SW 7005 PURE WHITE LOCATION: BOH AND CEILINGS NOTE: LEVEL 5 FINISH U.O.N. - SATIN FINISH. GC TO PROVIDE SAMPLE FOR ARCHITECT APPROVAL.	GC / GC		SIGNAGE FINISH MANUFACTURER: PRISMATIC POWDERS MODEL NUMBER: PPB-8034 FINISH: HIGH GLOSS POWDER COAT COLOR: MELTED BRONZE LOCATION: STOREFRONT SIGNAGE AND BACK STOREFRONT REFINISH FOR STOREFRONT FRAMING. NOTE: GC TO PROVIDE ARCHITECT SAMPLES FOR APPROVAL. POWER COAT OR APPROVED ELECTROSTATIC APPLICATION FOR REFINISH OF STOREFRONT FACING PARKING LOT. NEW STOREFRONT MULLIONS AND FRAMING TO HAVE MT-1 FINISH. FOLLOW MANUFACTURER'S INSTRUCTION FOR COATING. TOP COAT COLOR MUST BE APPLIED OVER BRIGHT SILVER SUBSTRATE TO ACHIEVE COLOR.	SIGNAGE BY VENDOR STOREFRONT REFINISH BY GC STOREFRONT BY GC/GC VENDOR
	STOREFRONT FINISH MANUFACTURER: TBD COLOR: WHITE LOCATION: STOREFRONT NOTE: FINISHED METAL PANEL WITH OVERLAPPING SEAMS. EXTERIOR IMPACT RESISTANT RATING TO MEET FIA CODE FOR HURRICANES. GC TO PROVIDE SAMPLE FOR ARCHITECT APPROVAL.	GC / GC		WALL CROWN MOULDING MANUFACTURER: RELIABILT MODEL NUMBER: L 49 8FJPM COLOR: BENJAMIN MOORE DOVE WING OC-18 SIZE: 9/16" T X 3-5/8" W LOCATION: UPPER WALL THROUGHOUT - SEE ELEVATIONS FOR MORE INFORMATION. NOTE: GC TO INSTALL OVER TOP OF WC-1. GC TO SUBMIT PROFILE SUBMITTAL FOR APPROVAL.	

WALL/CEILING FINISHES PLAN NOTES

- SAMPLES OF ALL FINISHES SPECIFIED SHALL BE SUBMITTED TO ARCHITECT FOR APPROVAL, IN TRIPLICATE, PRIOR TO COMMENCEMENT OF THE WORK.
- ALL WALLS (NEW AND EXISTING) SHALL BE PROPERLY PREPARED (SPACKLED, SANDED, ETC.) FOR PAINTING AND/OR WALL COVERING AS PER FINISH PLAN AND MANUFACTURER'S SPECIFICATIONS.
- ALL PAINTS SHALL BE APPLIED IN ACCORDANCE WITH MANUFACTURER'S SPECIFICATIONS FOR THE PARTICULAR SURFACE.
- ALL SURFACES WHICH ARE TO BE PAINTED SHALL RECEIVE (1) COAT OF PRIMER AND (2) COATS OF FINISH PAINT. (3) COATS TOTAL.
- ALL EXISTING GYPSUM BOARD CEILINGS THAT ARE PATCHED SHALL BE PAINTED IN THEIR ENTIRETY.
- GENERAL CONTRACTOR SHALL FLASH PATCH AND PREPARE ALL FLOORS AS REQUIRED TO RECEIVE SPECIFIED FLOORING MATERIAL.
- FLOORING CONTRACTOR SHALL INSPECT THE SUB-FLOOR PRIOR TO COMMENCEMENT OF WORK. THEY SHALL NOTIFY THE ARCHITECT IN WRITING OF ANY CONDITIONS WHICH WILL PREVENT THEM FROM PRODUCING SATISFACTORY FINISH WORK.
- FLOORING CONTRACTOR SHALL ASSUME FULL RESPONSIBILITY FOR ANY / UNACCEPTABLE FINISH WORK CAUSED BY SUB-FLOOR CONDITIONS.
- GENERAL CONTRACTOR SHALL INSTALL NEW WALL BASE ON ALL WALLS ACCORDING TO PLANS.
- GENERAL CONTRACTOR TO PROVIDE AND INSTALL ALL METAL TRANSITION ANGLES AND/OR REDUCING SADDLES PER DETAILS, IN ADDITION TO ANY FLOOR LEVELING AS MAY BE REQUIRED FOR SMOOTH TRANSITION AT ALL FLOORING MATERIAL TRANSITION POINTS.
- WHERE STONE OR POROUS FLOORING IS SPECIFIED, G.C. SHALL BE RESPONSIBLE FOR PROVIDING/APPLYING SEALANT AS SPECIFIED OR AS RECOMMENDED BY SUPPLIER, FOR A CLEAN, LASTING SURFACE.
- THE FLOORING CONTRACTOR SHALL COORDINATE WITH THE ELECTRICIANS REGARDING FLOOR OUTLETS FOR ELECTRICAL AND COMMUNICATION REQUIREMENTS. ALL PREP FOR FLOOR OUTLETS AND JUNCTION BOXES SHALL BE THE RESPONSIBILITY OF THE FLOORING CONTRACTOR.
- ALL CARPETS AND RUGS TO BE IN COMPLIANCE WITH LOCAL AND STATE CODES.
- ALL MATERIALS AND FINISHES MUST BE FIRE-RATED AND HAVE FLAME RESISTANCE COMPLYING WITH LOCAL AND STATE CODES.
- ALL SURFACES AT TRANSITIONS BETWEEN DIFFERENT OR EXISTING NEW MATERIALS TO BE FLUSH AND / OR ADA COMPLIANT.
- ALL CEILING ELEMENTS INCLUDING, BUT NOT LIMITED TO ACCESS PANELS AND SPEAKER GRILLES TO BE PAINTING TO MATCH SCHEDULED CEILING PAINT. REFER TO RCP FOR MORE INFORMATION.
- ALL FINISHES AND PAINTING REQUIREMENTS MUST BE AS PER FINISH SCHEDULE, ELEVATIONS AND SPECIFICATIONS.
- INSTALLATION OF FINISHES AND FIXTURES TO BE COORDINATED BETWEEN G.C., F.C., AND ALL VENDORS.
- G.C. TO FIELD VERIFY ALL EXISTING CONDITIONS AND INFORM ARCHITECT OF ANY DISCREPANCIES IMMEDIATELY.

WALL/CEILING FINISHES PLAN KEYNOTES (#)

- LINE OF STOREFRONT SOFFIT ABOVE. SOFFIT SURROUND TO BE STUCCO FINISH BY GC AS SCHEDULED.
- EXTERIOR STOREFRONT TO BE REFRESHED AS REQUIRED. GC TO COORDINATE WITH LANDLORD ON FINISH AND APPROVAL.
- DASHED LINE INDICATES OPTING HEIGHT TRANSITION ABOVE.
- BEADBOARD WALL FINISH THROUGHOUT SALES AREA BY GC. REFER TO FINISH SCHEDULE FOR SPECS.
- EXISTING MALL FLOOR FINISH TILE TO REMAIN. PROTECT IN PLACE OR TO PATCH/REPAIR/REMOVE ONLY AS REQUIRED UP TO NEW STOREFRONT FINISH. FLUSH & SEAMLESS TRANSITION BETWEEN FLOORING FINISHES WITH BRASS SCHLUTER OR SEAL. GC TO PROVIDE SAMPLES AS REQUIRED FOR APPROVAL. REFER TO DETAILS ON A-403.
- GC RESPONSIBLE TO REPAIR ANY DAMAGED EXTERIOR MALL TILE/PAVERS UP TO TENANT STOREFRONT AND ENTRY DOOR CLOSURE. COORDINATE WITH OWNER FOR LL VENDOR AND SPECIFICATION. VERIFY IN FIELD EXTENTS, IF ANY.
- EXISTING BOH CEILING TO REMAIN. PATCH AND REPAIR AS REQUIRED TO RECEIVE NEW PAINT FINISH.

LANDLORD FINISH PLAN NOTES

STOREFRONT AND INTERIOR MATERIALS & FINISHES MUST BE APPROVED PRIOR TO INSTALLATION. PROVIDE A MATERIAL FINISH SAMPLE BOARD TO LL FOR REVIEW.



LEVEL 5 FINISHES REQUIRED (TYPICAL).

MALL TILE MUST BE EXTENDED UP TO TENANT STOREFRONT AND ENTRY DOOR CLOSURE POINTS. TENANT FLOOR FINISH ON MALL SIDE OF RECESSED ENTRY IS NOT PERMITTED.

FINISH FLOOR ELEVATION AT STORE ENTRANCE(S) TO BE AT THE SAME ELEVATION AS MALL FLOOR.

VINYL TILE AND BASE NOT PERMITTED IN SALES AREA.

NO VISIBLE PLATES ALLOWED ON FINISH FLOOR AT DOORS. IF REQUIRED, THEY MUST BE INSTALLED BELOW FINISH FLOOR.

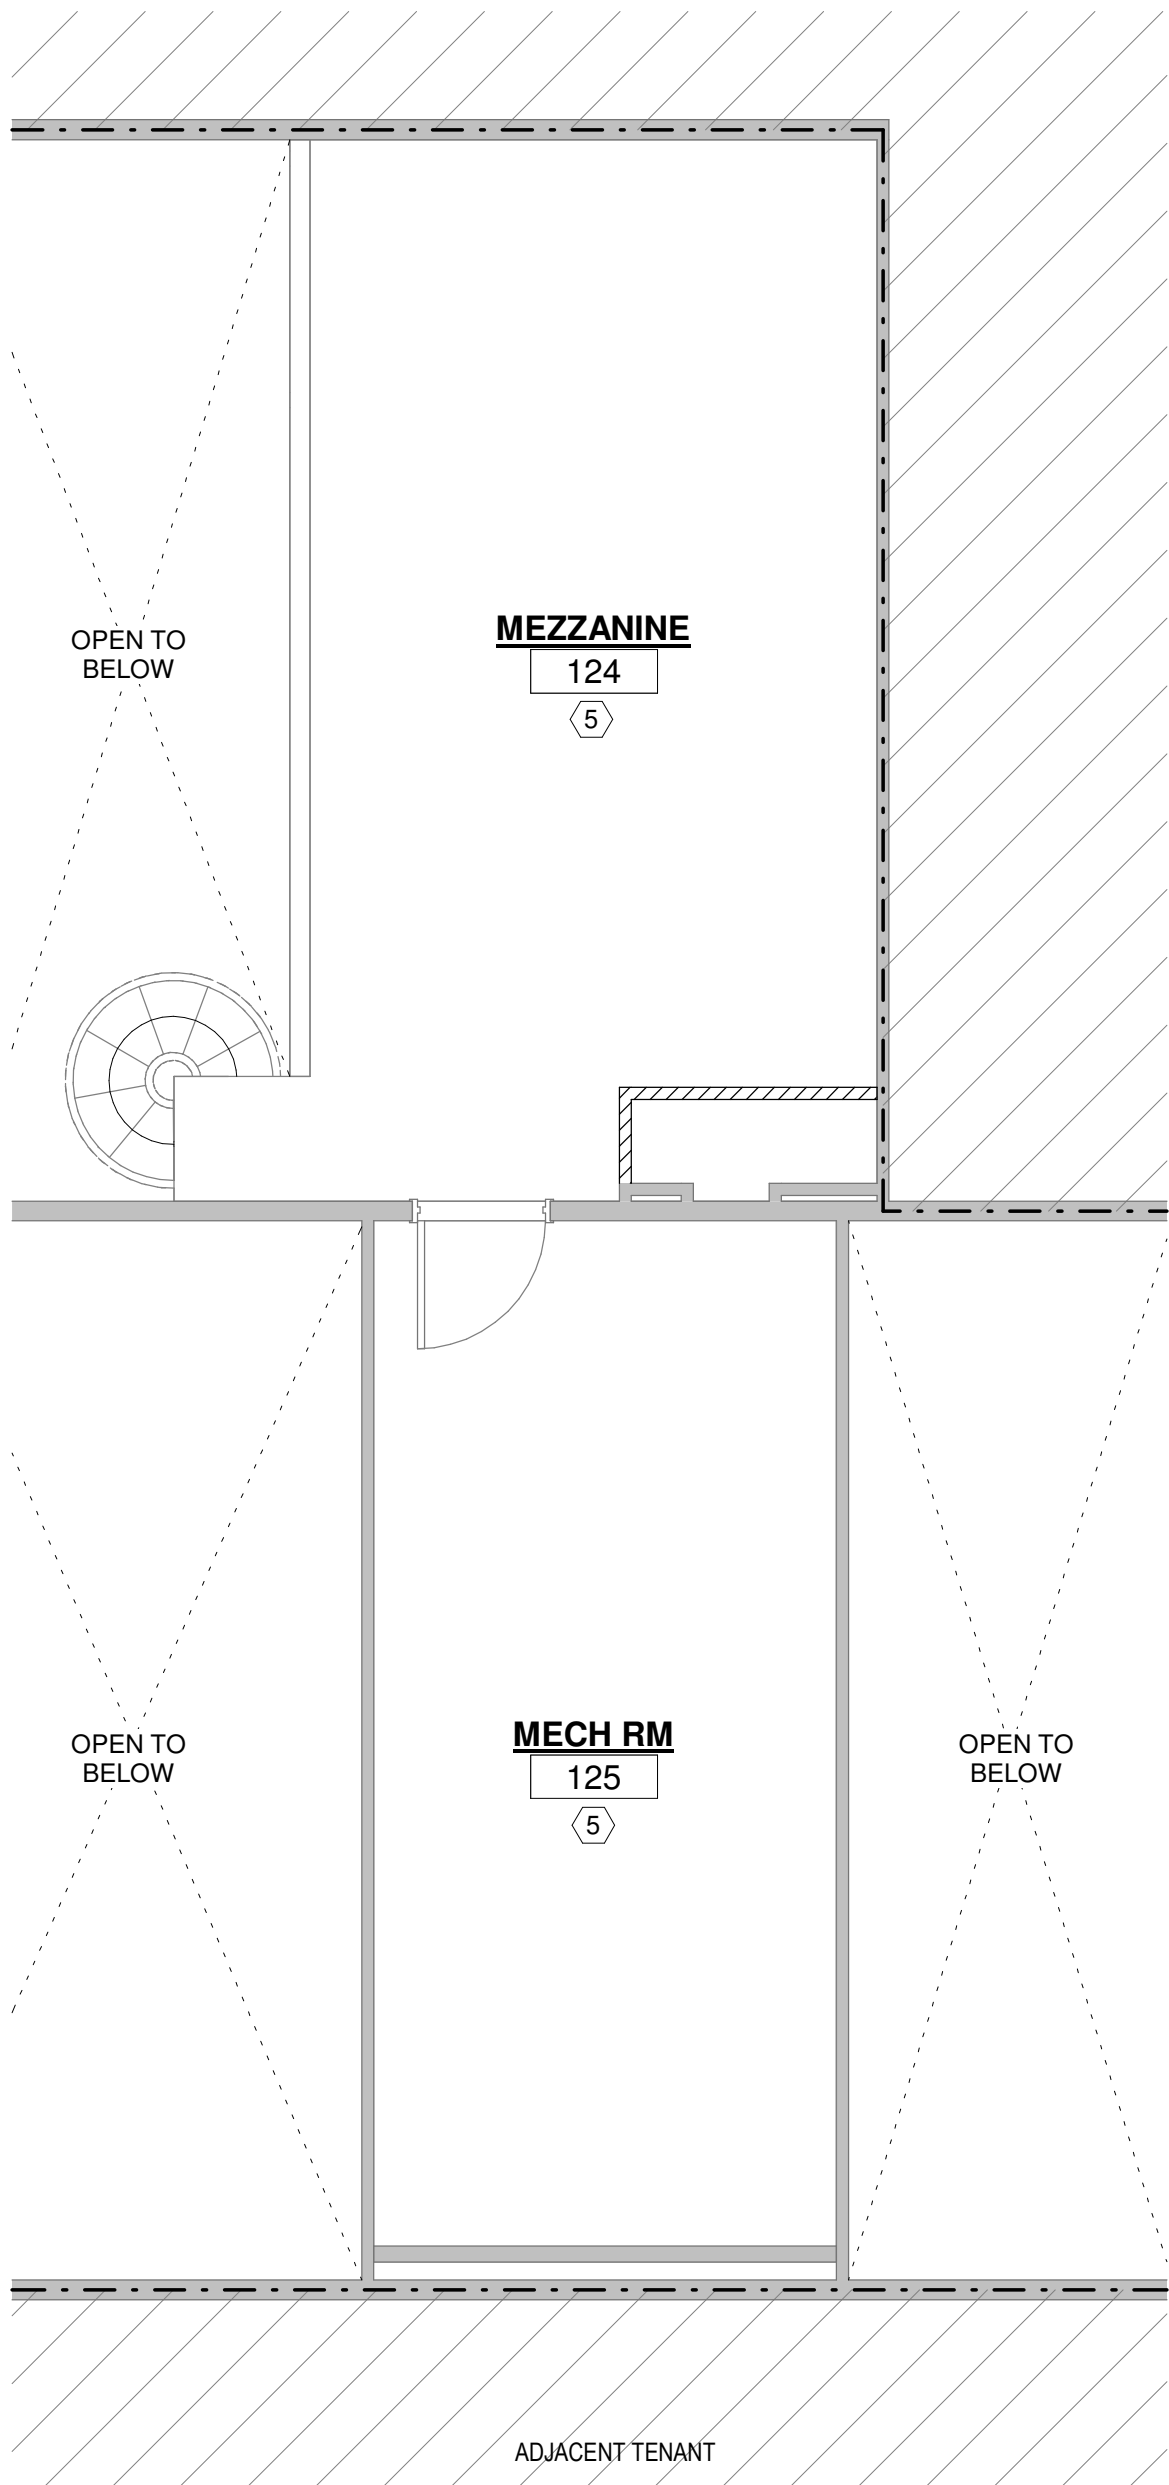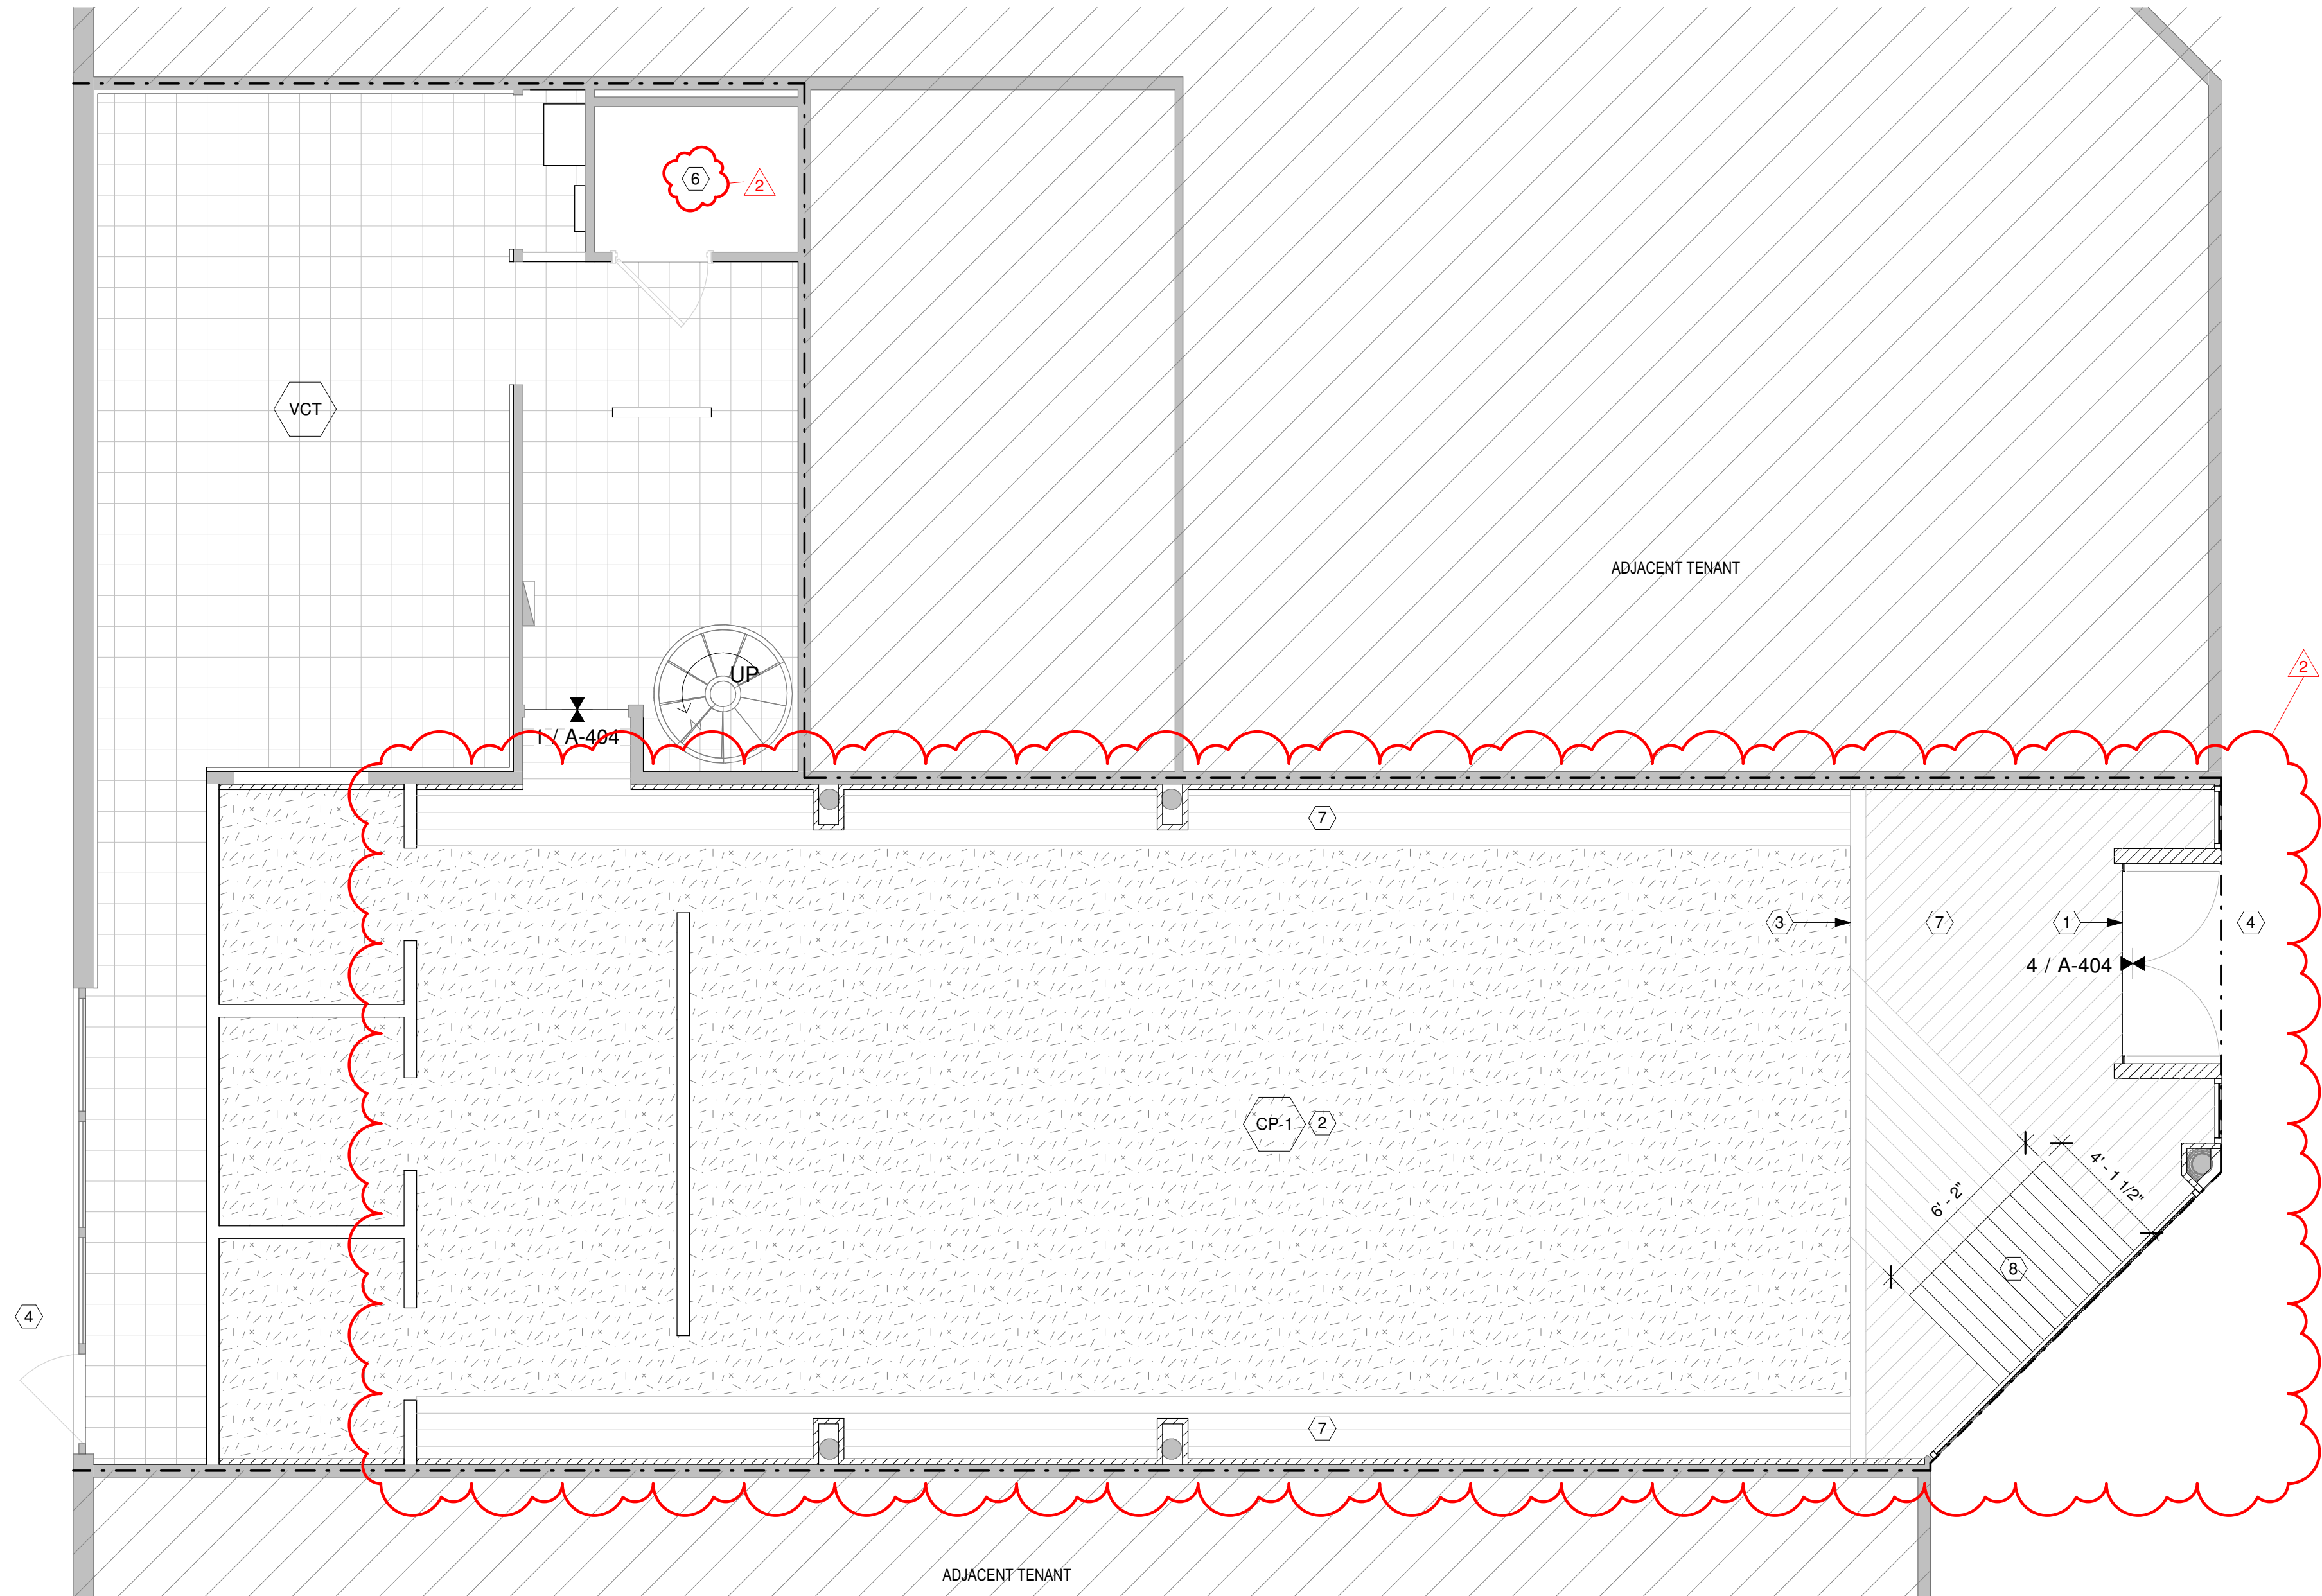

2 MEZZANINE FLOOR FINISH PLAN
SCALE: 1/4" = 1'-0"

1 FLOOR FINISH PLAN
SCALE: 1/4" = 1'-0"

LANDLORD FINISH PLAN NOTES

STOREFRONT AND INTERIOR MATERIALS & FINISHES MUST BE APPROVED PRIOR TO INSTALLATION. PROVIDE A MATERIAL FINISH SAMPLE BOARD TO LL FOR REVIEW.

LEVEL 5 FINISHES REQUIRED (TYPICAL).

MALL TILE MUST BE EXTENDED UP TO TENANT STOREFRONT AND ENTRY DOOR CLOSURE POINTS. TENANT FLOOR FINISH ON MALL SIDE OF RECESSED ENTRY IS NOT PERMITTED.

FINISH FLOOR ELEVATION AT STORE ENTRANCE(S) TO BE AT THE SAME ELEVATION AS MALL FLOOR.

VINYL TILE AND BASE NOT PERMITTED IN SALES AREA.

NO VISIBLE PLATES ALLOWED ON FINISH FLOOR AT DOORS. IF REQUIRED, THEY MUST BE INSTALLED BELOW FINISH FLOOR.

FLOOR FINISH PLAN GENERAL NOTES

WHERE IT OCCURS, THE SCHEDULED FLOOR FINISH TO CARRY UNDER WALL BASE. NO VISIBLE GAPS AT WALL BASE EDGE AND FLOOR FINISH WILL BE PERMITTED.

GC TO PROTECT FINISHED FLOORING REGARDLESS OF PHASING.

GC TO PATCH/REPAIR DAMAGE TO EXTERIOR STOREFRONT LINE OF CLOSURE AS REQUIRED. FLUSH, SEAMLESS TRANSITION TO TENANT'S FLOORING AND FLOOR FINISH, VIF.

FLOOR FINISH PLAN LEGEND

SYMBOL	DESCRIPTION	PROVIDE / INSTALL
CP-1	SISAL FLOORING MANUFACTURER: FIBREWORKS MODEL NAME: BOTANICAL BLENDS COLOR: 606 SPRING TWINE LOCATION: THROUGHOUT NOTE: CARPET TO GO THROUGHOUT SALES AND FITTING. PROVIDED SCHLUTER TRANSITION STRIP TO BOH FLOORING IN BRASS. FLOORING TO BE LEVEL TO MALL EXTERIOR ENTRY.	OWNER / OWNER
VCT	BOH VCT FLOORING THROUGHOUT MANUFACTURER: ARMSTRONG MODEL NAME: STANDARD EXCELRON IMPERIAL TEXTURE COLOR: SOFT WARM GRAY 51861 LOCATION: BOH NOTE: GC TO PROVIDE SAMPLE FOR ARCHITECT APPROVAL.	GC / GC
⌂	FLOORING TRANSITION	
⌂	FLOORING FINISH START POINT	
→	FINISH GRAIN DIRECTION	

FLOOR FINISH PLAN KEY NOTES (#)

- TRANSITION FROM LL EXTERIOR FLOOR TO NEW TENANT FLOOR TO REMAIN FLUSH. GC TO INFILL NEW AREA WITH LL FINISH AS REQUIRED UP TO SCHLUTER LINE BETWEEN NEW TENANT FINISH AND LL FINISH.
- FLOORING TO RUN FACE OF WALL TO FACE OF WALL. WALL BASE TO SIT ON TOP OF FINISH FLOORING.
- GC TO RECESS CARPET AS REQUIRED TO ALIGN WITH ADJACENT WOOD FLOOR TO REMAIN ADA COMPLIANT. PROVIDE BRUSHED SS SCHLUTER STRIP BETWEEN WOOD AND CARPET.
- GC RESPONSIBLE TO REPAIR ANY DAMAGED EXTERIOR MALL TILE/PAVERS UP TO TENANT STOREFRONT AND ENTRY DOOR CLOSURE. COORDINATE WITH OWNER FOR LL VENDOR AND SPECIFICATION. VERIFY IN FIELD EXTENTS, IF ANY.
- NO CHANGES TO MEZZANINE OR MECHANICAL ROOM FLOORING. GC TO CLEAN AS REQUIRED.
- EXISTING RESTROOM FLOOR TO REMAIN.
- EXISTING WOOD FLOOR FINISH TO REMAIN. GC TO PROTECT IN PLACE FOR DURATION OF CONSTRUCTION.
- NEW WOOD FLOOR INFILL. SAND, RE-SEAL, AND FINISH TO ALIGN WITH AND MATCH EXISTING.



45 WEST 21st STREET, SUITE 403
NEW YORK, NY 10010

IN ASSOCIATION WITH THE ARCHITECT:
R H SWEERS II, PROPRIETOR
R H SWEERS ARCHITECT

ALL DRAWINGS AND WRITTEN MATERIAL APPEARING HEREIN CONSTITUTE ORIGINAL AND UNPUBLISHED WORK OF THE ARCHITECT AND MAY NOT BE DUPLICATED, USED OR DISCLOSED WITHOUT WRITTEN CONSENT OF THE ARCHITECT. THIS DOCUMENT IS INTENDED SOLELY FOR THE CONSTRUCTION OF THE PROJECT NAMED HEREIN AND SHALL NOT BE USED BY ANY OTHER CONSTRUCTION WITHOUT WRITTEN CONSENT OF THE ARCHITECT.

THIS DRAWING WAS PREPARED UNDER MY SUPERVISION AND I DISCLAIM ANY RESPONSIBILITY FOR THE EXISTING BUILDING CONSTRUCTION ELEMENTS, SITE CONDITIONS, OR ANY DOCUMENTS WHICH DO NOT BEAR MY SEAL.

SEAL

ISSUE FOR BID

DRAWINGS ISSUED

No.	Rev	Date	Description
1		06.18.26	LL REVIEW SET
2		06.24.26	ISSUE FOR PERMIT
3		07.02.26	ISSUE FOR BID
4	1	07.28.26	BID ADDENDUM #1
5	2	08.27.26	BID ADDENDUM #2

PROJECT NAME:
TWP NAPLES

TWP

PROJECT ADDRESS:
WATERSIDE SHOPS
5455 TAMIAMI TRL N
NAPLES, FL 34108

DRAWING TITLE:
FLOOR FINISH PLAN

SCALE: AS SHOWN

Project No. 26TWP05

Scale: 1/4" = 1'-0"

Date: 08-20-2026

Drawn By: 212

Checked BY: 212

DRAWING NO:

A-403



45 WEST 21st STREET, SUITE 403
NEW YORK, NY 10010

IN ASSOCIATION WITH THE ARCHITECT:
R H SWEERS II, PROPRIETOR
R H SWEERS ARCHITECT

ALL DRAWINGS AND WRITTEN MATERIAL APPEARING HEREIN
CONSTITUTE ORIGINAL AND UNPUBLISHED WORK OF THE
ARCHITECT AND MAY NOT BE DUPLICATED, USED OR DISCLOSED
WITHOUT WRITTEN
CONSENT OF THE ARCHITECT. THIS DOCUMENT IS INTENDED
SOLELY FOR THE CONSTRUCTION OF THE PROJECT NAMED HEREIN
AND SHALL NOT BE USED BY ANY OTHER CONSTRUCTION WITHOUT
WRITTEN CONSENT OF THE ARCHITECT.

THIS DRAWING WAS PREPARED UNDER MY SUPERVISION AND I
DISCLAIM ANY RESPONSIBILITY FOR THE EXISTING BUILDING
CONSTRUCTION ELEMENTS, SITE CONDITIONS, OR ANY DOCUMENTS
WHICH DO NOT BEAR MY SEAL.

SEAL

ISSUE FOR BID

DRAWINGS ISSUED

No.	Rev	Date	Description
1		06.18.26	LL REVIEW SET
2		06.24.26	ISSUE FOR PERMIT
3		07.02.26	ISSUE FOR BID
5	2	08.27.26	BID ADDENDUM #2

PROJECT NAME:

TWP NAPLES

TWP

PROJECT ADDRESS:

WATERSIDE SHOPS
5455 TAMIAMI TRL N
NAPLES, FL 34108

DRAWING TITLE:


FLOOR FINISH DETAILS

SCALE: AS SHOWN

Project No.	26TWP05
Scale:	6" = 1'-0"
Date:	08-20-2026
Drawn By:	212
Checked BY:	212

DRAWING NO:

A-404

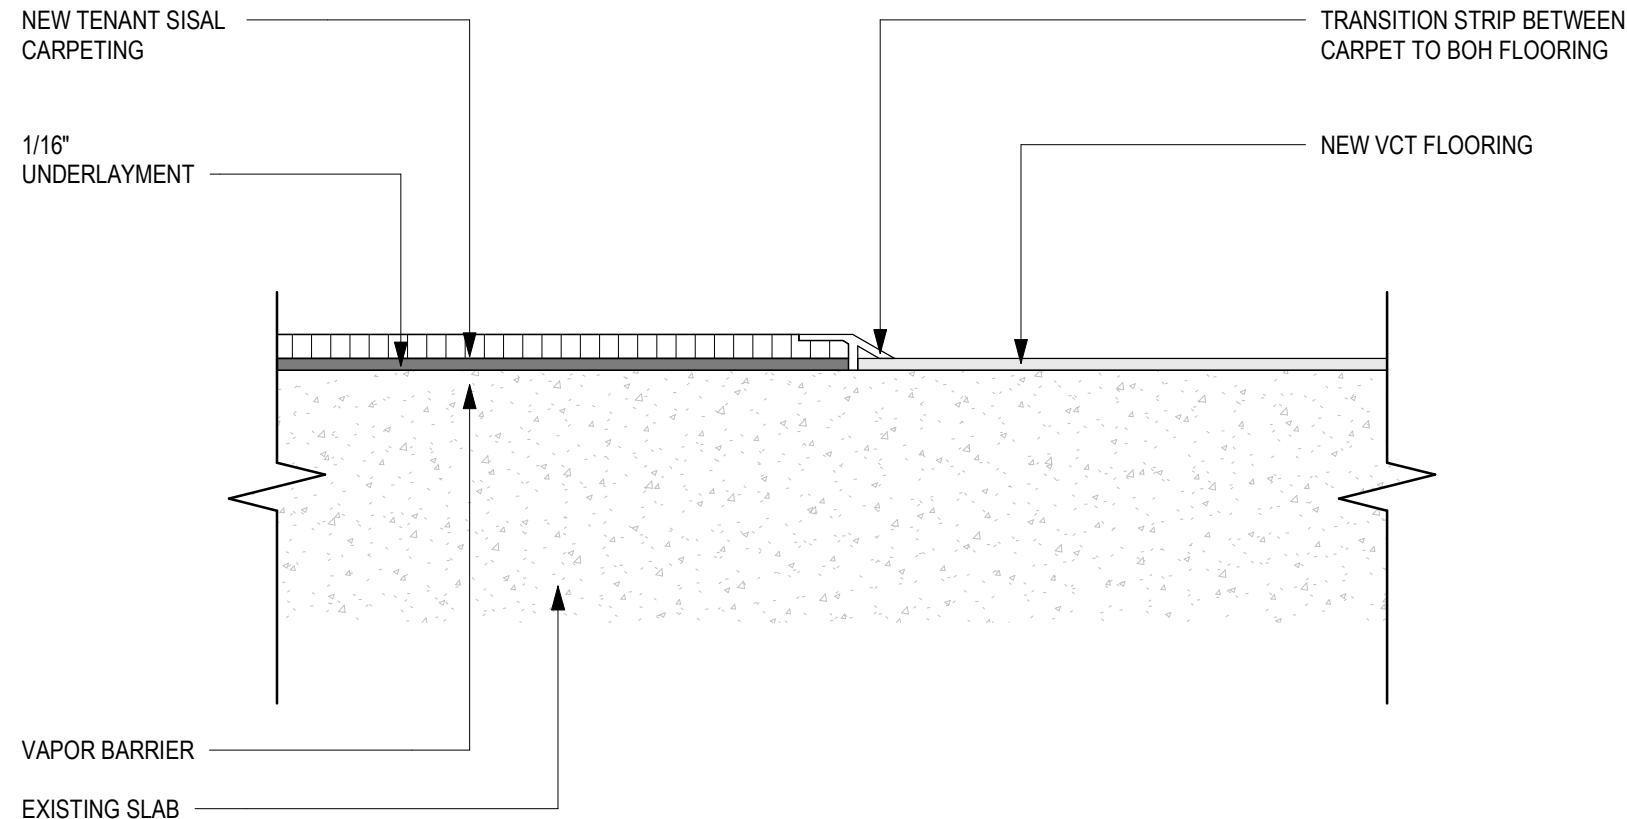

1 FLOOR TRANSITION - BOH FLOOR TO SALES
SCALE: 6" = 1'-0"

NOTES:

G.C. TO INSTALL CARPET AND SUBSTRATE LAYERS PER MANUFACTURER REQUIREMENTS AND SPECIFICATIONS.


TRANSITION STRIPS TO ALIGN AND BE FLUSH WITH FINISH LEVELS OF ADJACENT FLOORING MATERIALS.

PROVIDE MAPESEL T 100%-SILICONE SEALANT FOR HEAVY TRAFFIC AND MOVEMENT JOINTS AS MANUFACTURED BY MAPEI AT WALL TO FLOOR JOINTS. REFER TO WALL BASE DETAILS FOR MORE INFORMATION.


G.C. TO FINALIZE LOCATION WITH ARCHITECT AND LANDLORD FOR SCHLUTER ALIGNMENT.

STORE ENTRY


STORE SALES

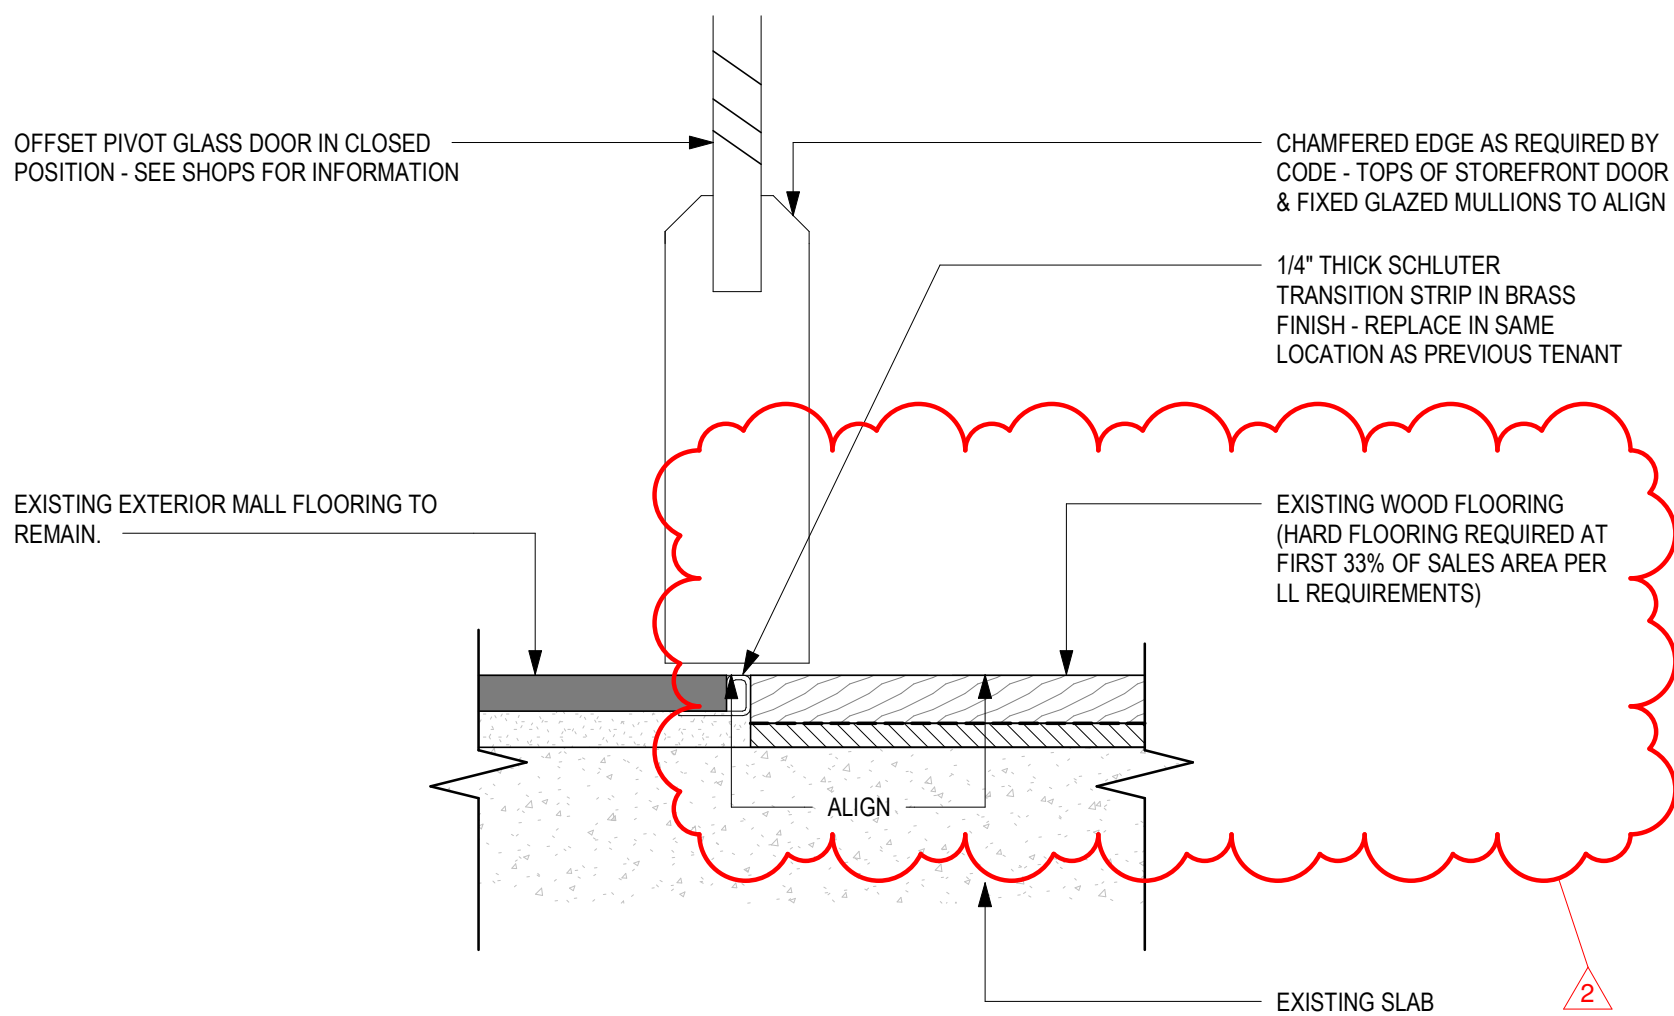

4 FLOOR TRANSITION - MALL FLOOR TO WOOD (ENTRY)
SCALE: 6" = 1'-0"

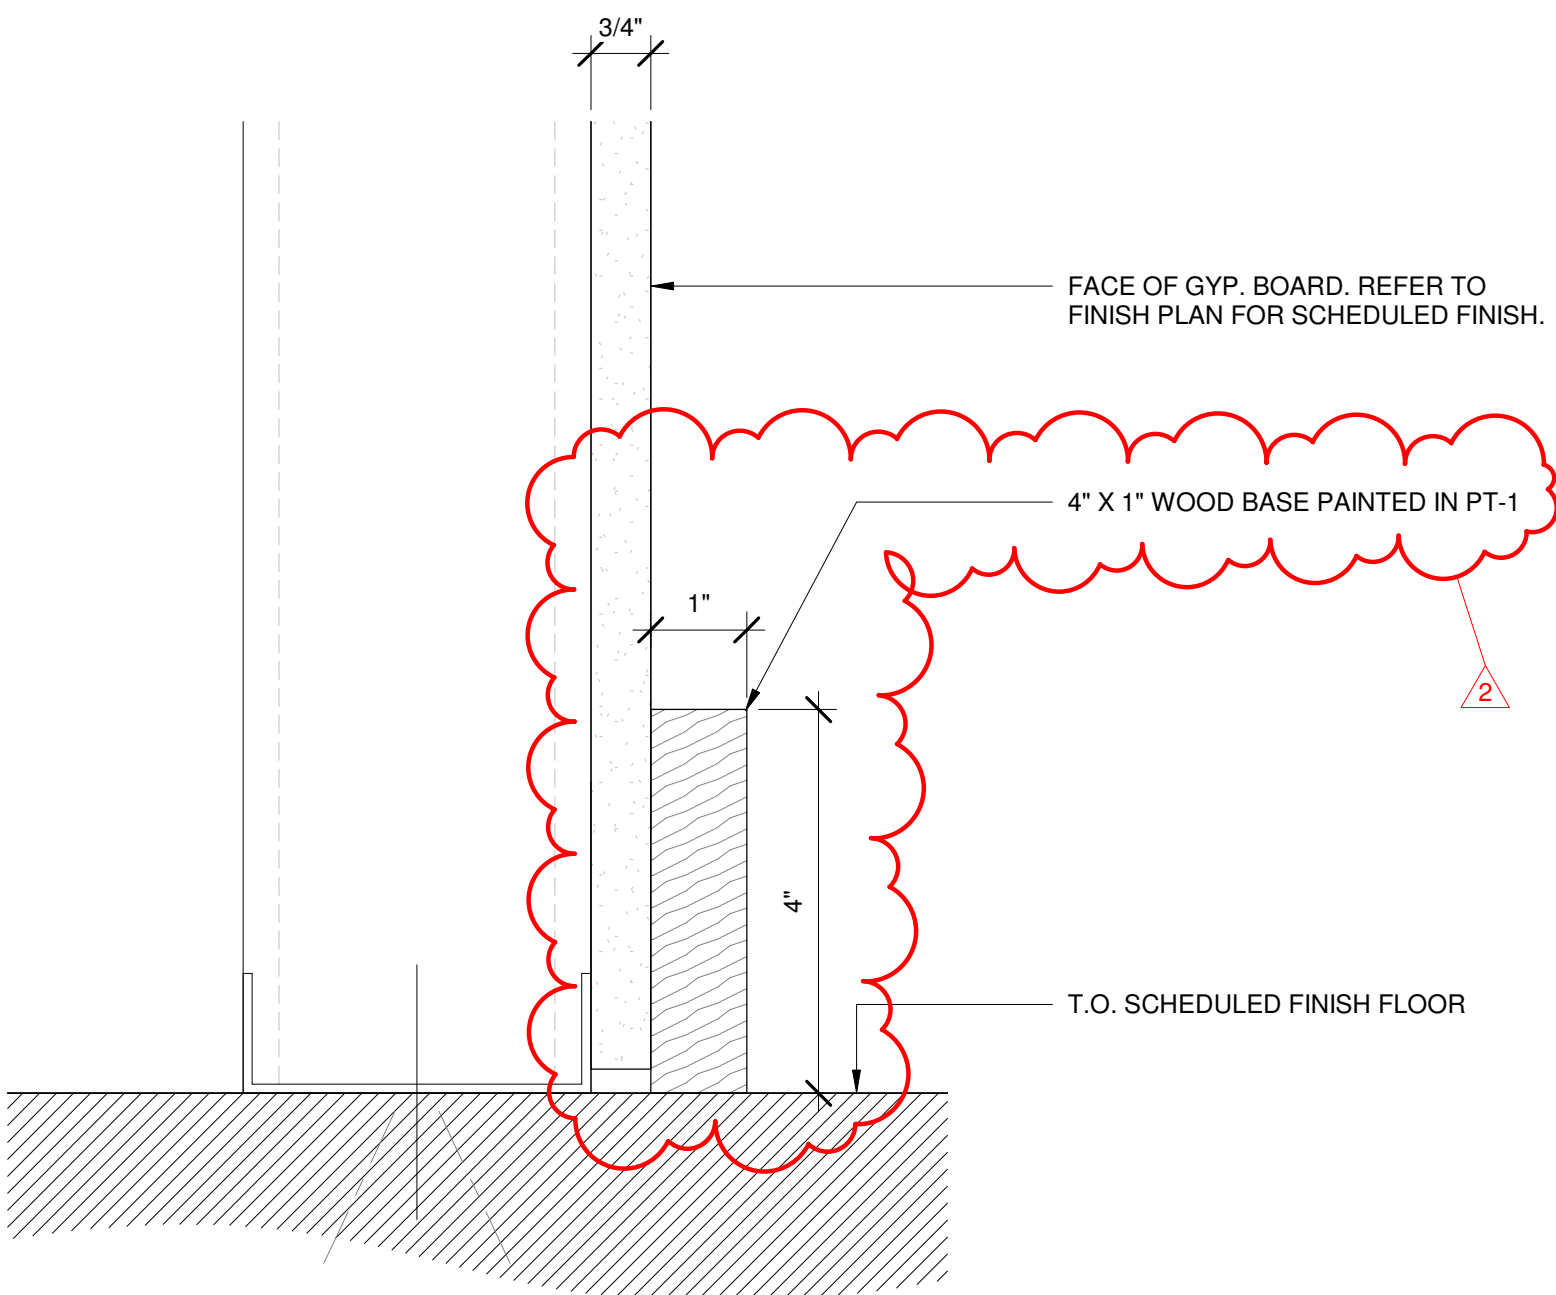

2 WALL BASE
SCALE: 6" = 1'-0"

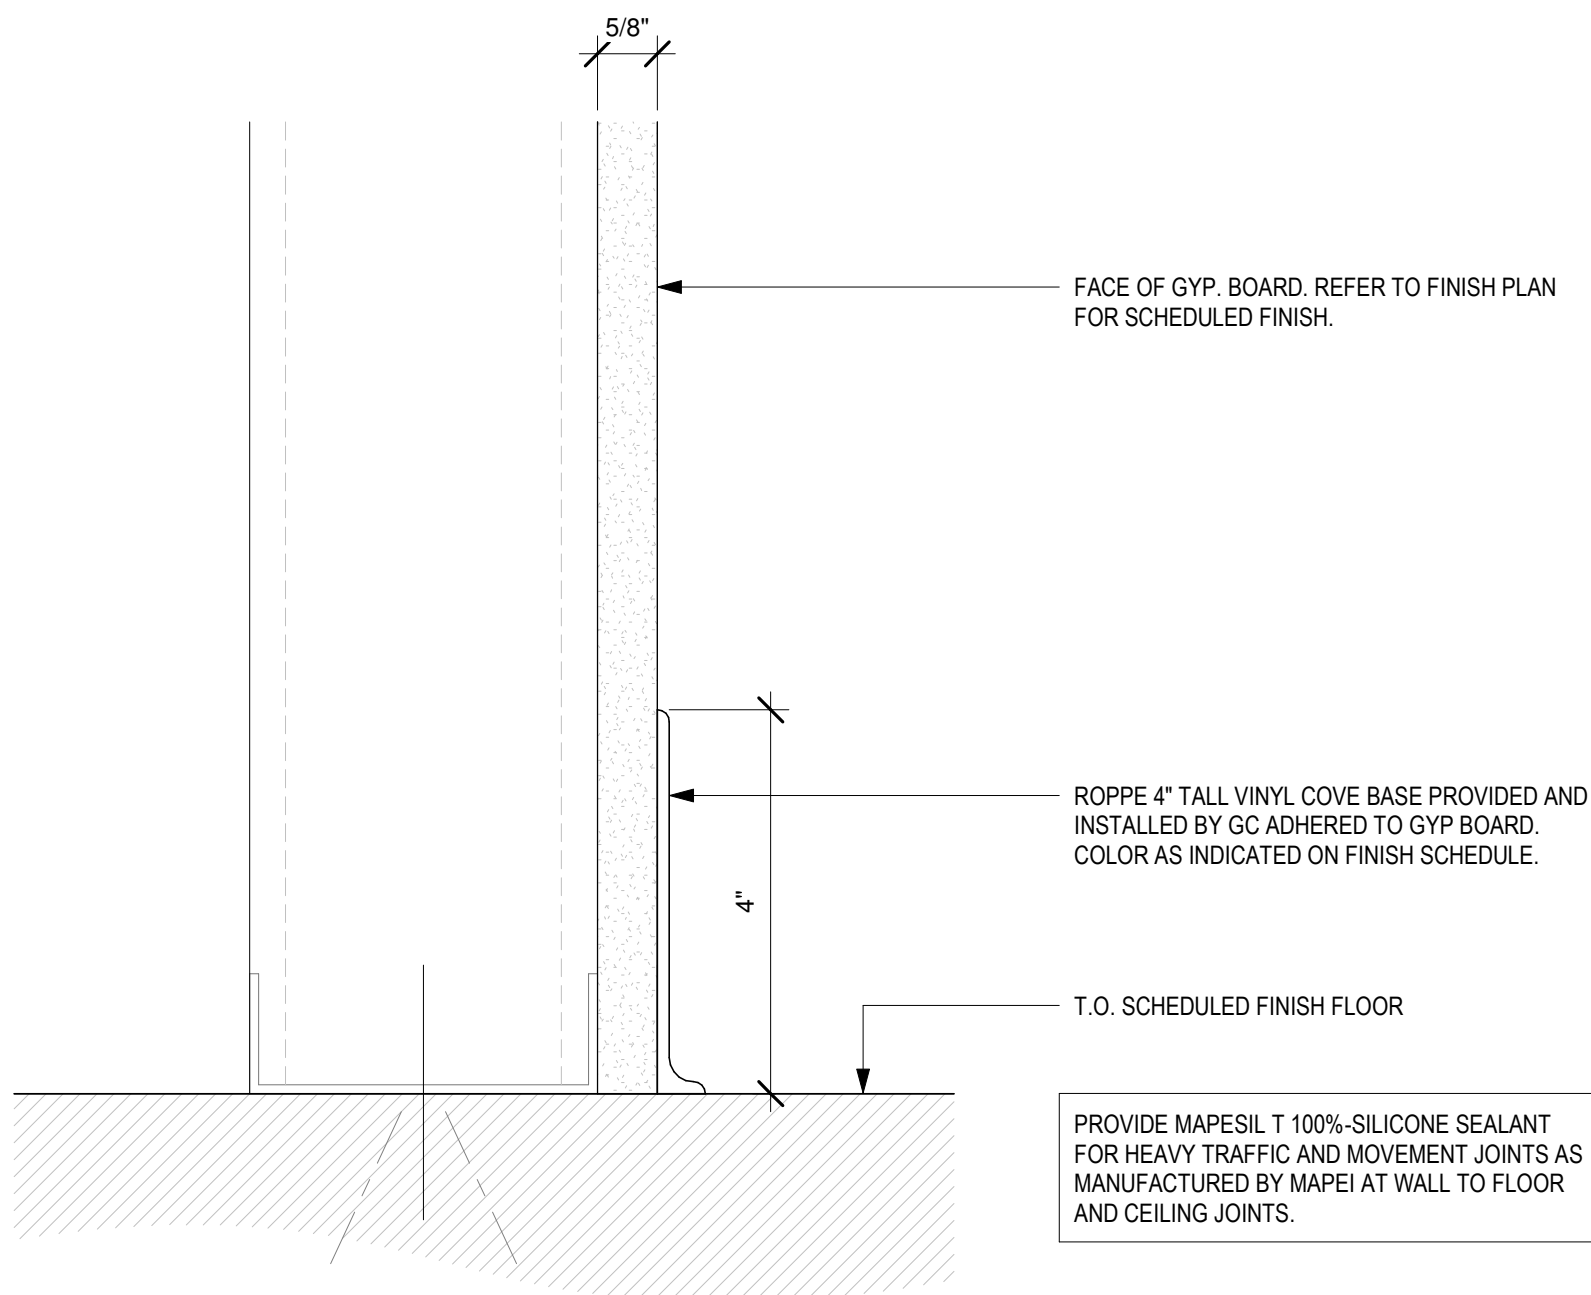

3 WALL APPLIED VINYL COVE BASE
SCALE: 6" = 1'-0"



45 WEST 21st STREET, SUITE 403
NEW YORK, NY 10010

IN ASSOCIATION WITH THE ARCHITECT:
R H SWEERS II, PROPRIETOR
R H SWEERS ARCHITECT

ALL DRAWINGS AND WRITTEN MATERIAL APPEARING HEREIN
CONSTITUTE ORIGINAL AND UNPUBLISHED WORK OF THE
ARCHITECT AND MAY NOT BE DUPLICATED, USED OR DISCLOSED
WITHOUT WRITTEN
CONSENT OF THE ARCHITECT. THIS DOCUMENT IS INTENDED
SOLELY FOR THE CONSTRUCTION OF THE PROJECT NAMED HEREIN
AND SHALL NOT BE USED BY ANY OTHER CONSTRUCTION WITHOUT
WRITTEN CONSENT OF THE ARCHITECT.

THIS DRAWING WAS PREPARED UNDER MY SUPERVISION AND I
DISCLAIM ANY RESPONSIBILITY FOR THE EXISTING BUILDING
CONSTRUCTION ELEMENTS, SITE CONDITIONS, OR ANY DOCUMENTS
WHICH DO NOT BEAR MY SEAL.

SEAL

ISSUE FOR BID

DRAWINGS ISSUED

No.	Rev	Date	Description
1		06.18.26	LL REVIEW SET
2		06.24.26	ISSUE FOR PERMIT
3		07.02.26	ISSUE FOR BID
5	2	08.27.26	BID ADDENDUM #2

PROJECT NAME:
TWP NAPLES

TWP


PROJECT ADDRESS:
WATERSIDE SHOPS
5455 TAMIAMI TRL N
NAPLES, FL 34108

DRAWING TITLE:
FIXTURE PLAN

SCALE: AS SHOWN

Project No.	26TWP05
Scale:	1/4" = 1'-0"
Date:	08-20-2026
Drawn By:	212
Checked By:	212
DRAWING NO:	

A-501

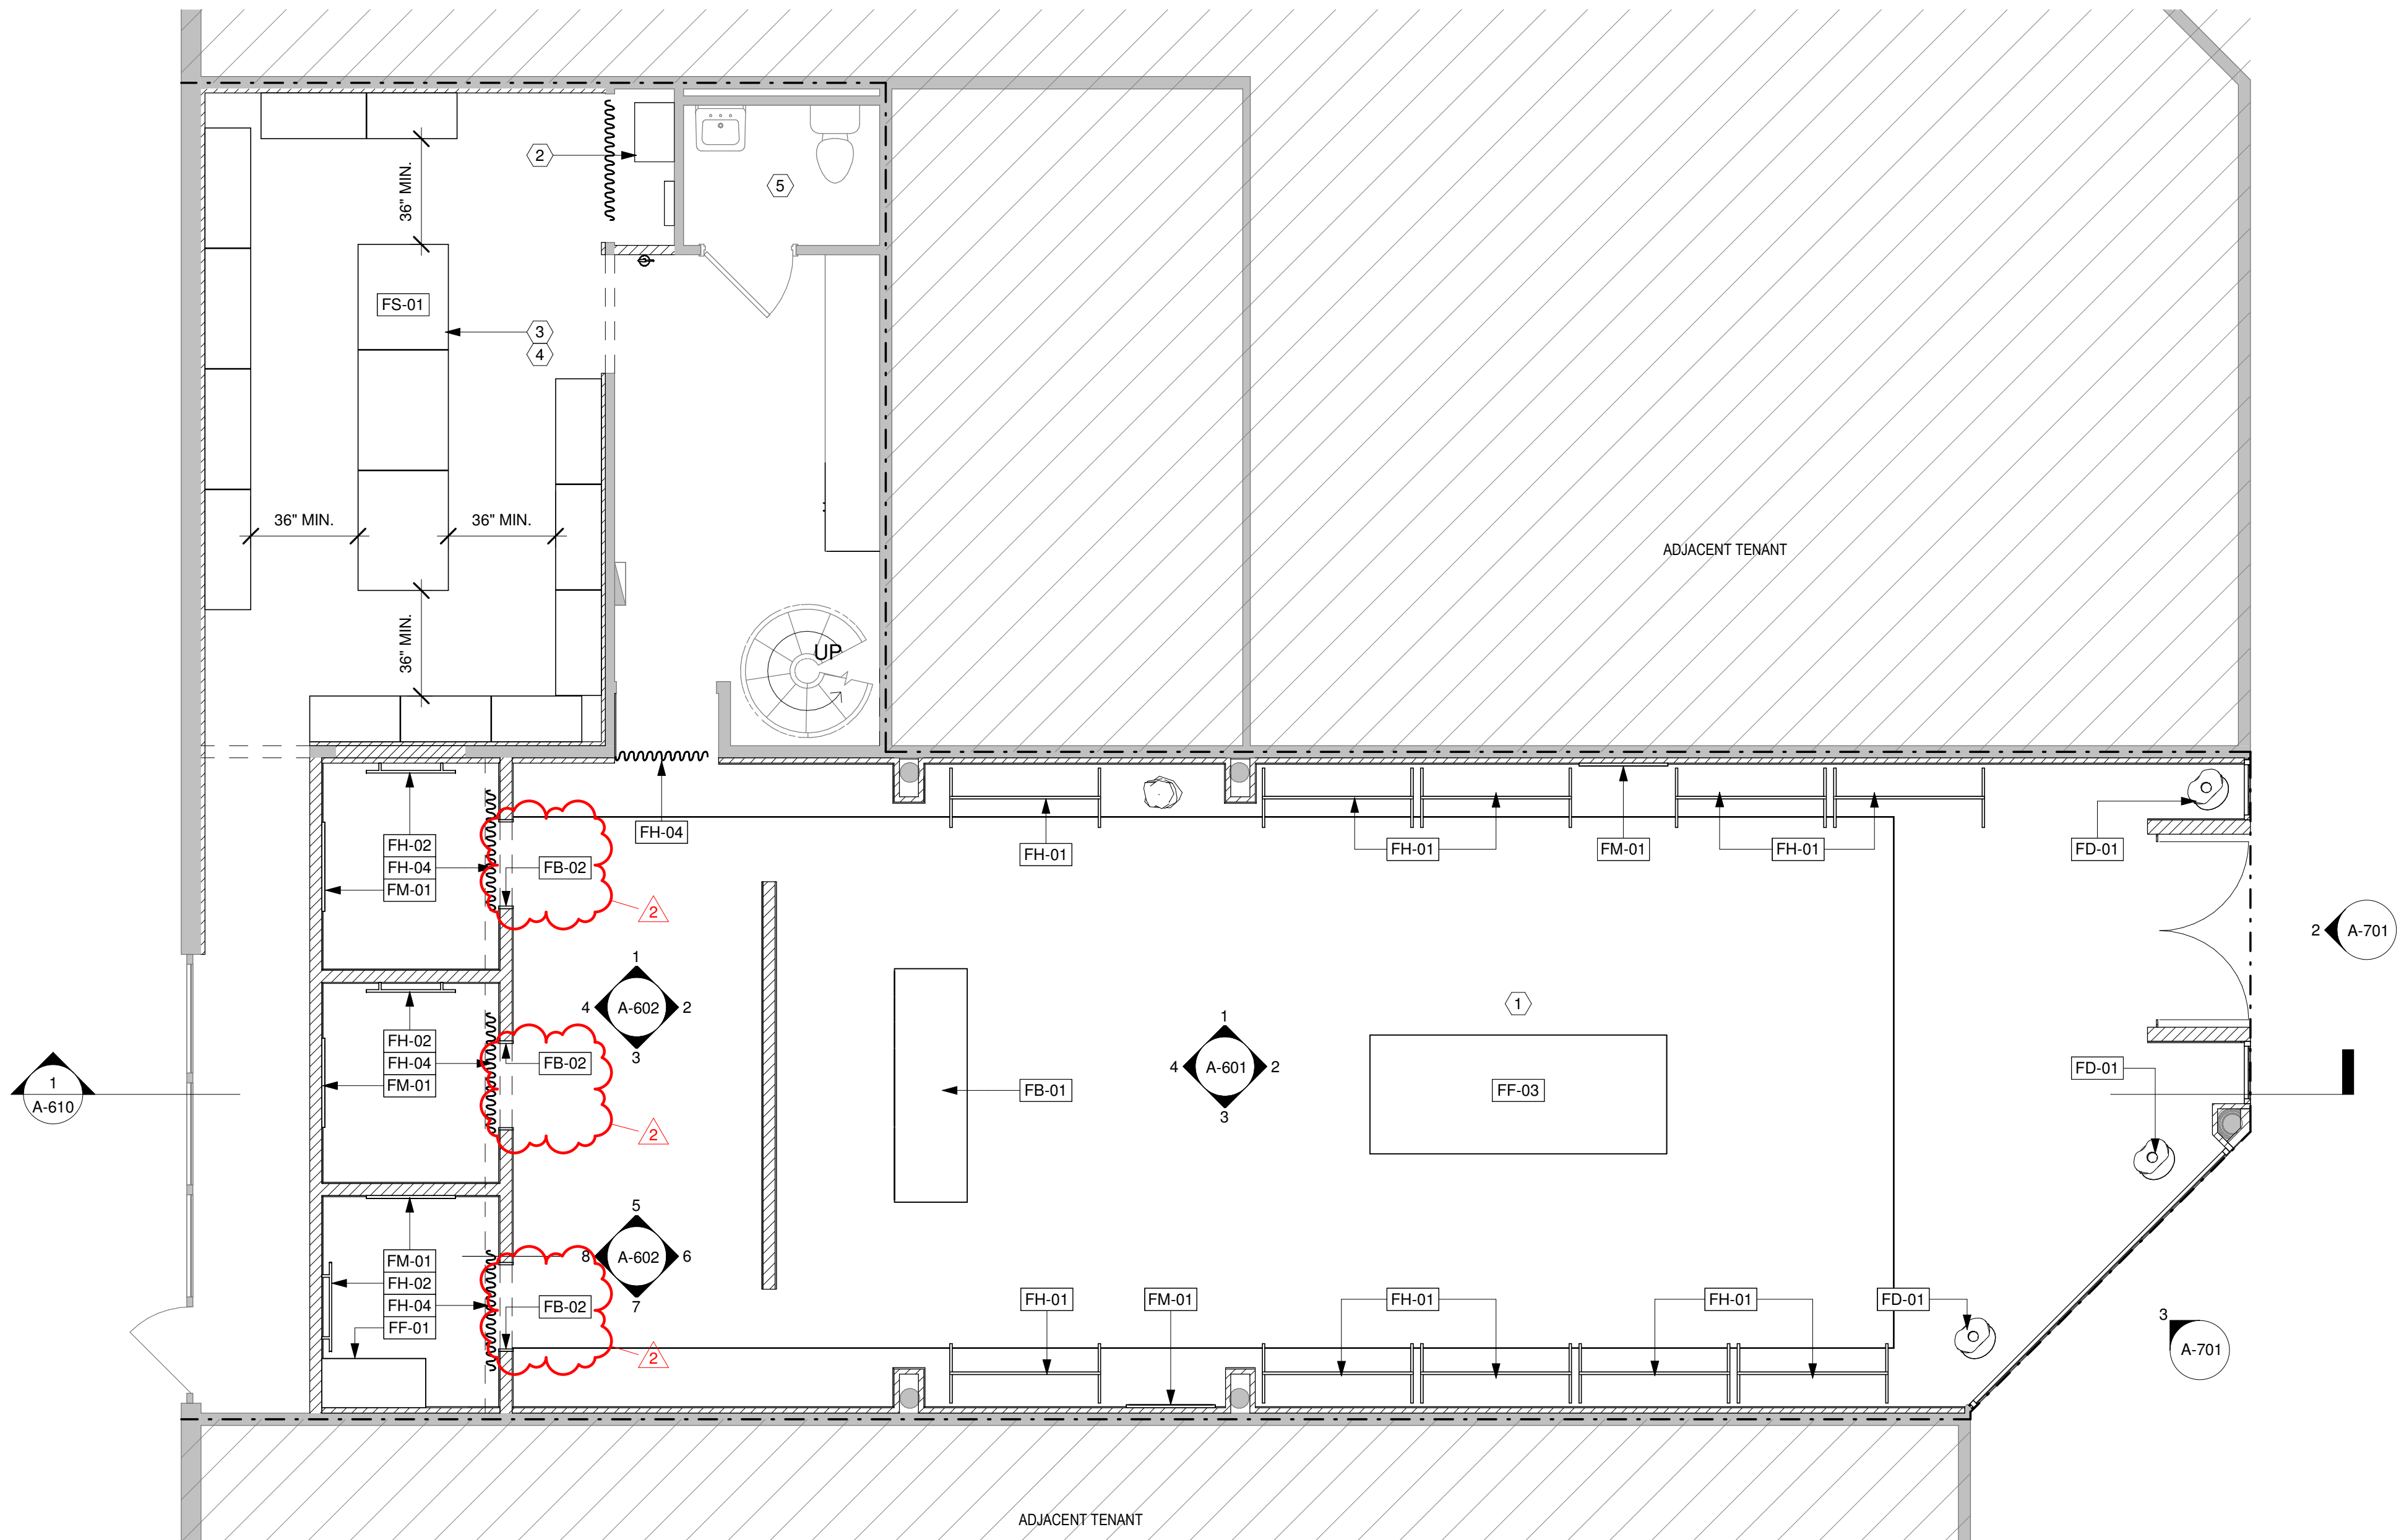

1
FIXTURE PLAN
SCALE: 1/4" = 1'-0"

MILLWORK, FIXTURE, AND FURNITURE SCHEDULE

TAG	QUANTITY	DESCRIPTION	PROVIDED BY	INSTALLED BY	NOTES
FIXTURE BUILT-IN					
FB-01	1	CASH DESK	MILLWORKER	GC	REFER TO POWER PLANS FOR REQUIRED POWERED POWER TO BE PROVIDED IN RATED ELECTRICAL BOXES. GC TO PULL CABLING AS REQUIRED. OWNER TO PROVIDE POS EQUIPMENT. COUNTER HEIGHT TO BE AT ACCESSIBLE LEVEL AND PROVIDE 5FT CLEAR IN FRONT.
FB-02	3	TRIM - WOOD CASING AT WALL OPENING	MILLWORKER	GC	POPLAR WOOD CASING AROUND INSIDE OF WALL OPENING
FD-01	3	MANNEQUIN	OWNER	GC	MANNEQUIN FOR FLOOR DISPLAY
FM-01	5	SALES FLOOR WALL MOUNTED MIRRORS	OWNER	GC	WALL MOUNTED MIRRORS - GC TO PROVIDE BLOCKING AS REQUIRED.
FIXTURE SHELVING					
FS-01	1	BOH SHELVING	OWNER'S VENDOR	OWNER'S VENDOR	BOH STORAGE. 8FT AND 7FT SHELVING. VENDOR TO PROVIDE AND INSTALL. GC TO COORDINATE ANY ADDITIONAL REQUIREMENTS FROM VENDOR.
HANGING FIXTURE					
FH-01	10	FIXTURE HANG BAR ON SALES	MILLWORKER	GC	GENERAL HANG BAR DISPLAYS 5FT FINISHED IN MT-1
FH-02	4	FIXTURE HANG BAR IN FITTING ROOMS	MILLWORKER	GC	MT-1 FINISH, SQUARED EDGES. GC TO PROVIDE BLOCKING AS REQUIRED.
FH-04	5	GENERAL CURTAINS FOR FITTING ROOM	MILLWORKER	GC	GC TO PROVIDE CURTAIN TRACK. PROVIDE BLOCKING AS REQUIRED. CURTAINS REQUIRED TO BE FIRE RATED PER FLORIDA FIRE CODE. PROVIDE SAMPLE FOR LL.
OWNER'S FURNITURE / FIXTURES					
FF-01	1	ADA FITTING ROOM BENCH	MILLWORKER	GC	ADA BENCH. GC TO MAINTAIN CLEARANCES AS NOTED. 30"X48" ADJACENT AND 60" CLEAR TURNING.
FF-03	1	LARGE DISPLAY TABLE	OWNER	GC	DISPLAY TABLE PROVIDED BY OWNER. CENTERED ON SPACE.

FIXTURE PLAN GENERAL NOTES

1. REFER TO FINISH SCHEDULE FOR FINISH DESCRIPTIONS AND SPECIFICATIONS.
2. G.C. AND FIXTURE CONTRACTOR TO COORDINATE THE CONSTRUCTION AND INSTALLATION MATERIALS, METHODS, AND SCHEDULING OF FIXTURES.
3. ALL DIMENSIONS ARE TO FINISHED WALL SURFACE. G.C. TO LAY OUT ALL WALLS IN FIELD FOR VERIFICATION AND APPROVAL PRIOR TO CONSTRUCTION. CONTACT ARCHITECT'S OFFICE WITH ANY CONFLICTS.
4. G.C. TO PROVIDE ELECTRICAL POWER AND FINAL HOOK-UP FOR ALL FIXTURES THAT CONTAIN ELECTRICAL ELEMENTS / LIGHTING. G.C. TO COORDINATE WITH SHOP DRAWINGS TO BE PROVIDED BY THE FIXTURE CONTRACTOR.
5. U.L. LISTING: G.C. AND F.C. ARE RESPONSIBLE FOR U.L. LISTING OF ALL FIXTURES. SEE LIGHTING AND FIXTURE DRAWINGS FOR DETAILS.
6. FINISHES TO BE RATED AS REQUIRED BY STATE / LOCAL BUILDING CODES.
7. FOR ALL WALL TYPES SPECIFIED, G.C. TO COORDINATE AND / OR SUPPLY METAL SHEETS OR PLYWOOD AS NECESSARY BEHIND MILLWORK. COORDINATE CONSTRUCTION DETAILS AND DIMENSIONS WITH FIXTURE PLANS AND FIXTURE SHOP DRAWINGS.
8. FIRE-STOPPING MATERIALS: FURNISH MATERIALS FOR PENETRATIONS IN THE TIME-RATED FLOOR. WALL AND PARTITION ASSEMBLIES CAPABLE OF PREVENTING PASSAGE OF FLAME, SMOKE, AND HOT GASES.
9. FIXTURES AND FURNITURE SUPPLIED BY MILLWORKER AND INSTALLED BY MILLWORK INSTALLER. G.C. TO REVIEW ALL MILLWORK SHOP DRAWINGS AND SUPPLEMENTAL INSTALL INFORMATION. G.C. TO KEEP A RECORD SET OF SHOP DRAWINGS ON SITE AT ALL TIMES. IT IS THE RESPONSIBILITY OF THE GENERAL CONTRACTOR TO RECEIVE, OFFLOAD, UNCRATE, ASSEMBLE, AND INSTALL ALL OWNER FURNISHED ITEMS, INCLUDING BUT NOT LIMITED TO, MILLWORK, TILE, SIGNAGE, ETC.
10. REFERENCE FIXTURE PACKAGE FOR DETAILS AND INSTALL GUIDELINES AS REQUIRED. REFER TO ELEVATIONS FOR ADDITIONAL FIXTURE MOUNTING HEIGHTS AND SPACING DIMENSIONS IN ADDITION TO FIXTURE PLAN. GC TO REFERENCE MILLWORK SHOP DRAWINGS, INSTALLATION DIAGRAMS, TEMPLATES, ETC. IN CONJUNCTION WITH THESE DRAWINGS.
11. FIXTURES TO RECEIVE IN-WALL STRUCTURAL SUPPORTS (OUTRIGGERS), PROVIDED BY MILLWORKER AND INSTALLED BY GC. GC TO COORDINATE OUTRIGGER INSTALLATION WITH SHOP DRAWINGS AND PROVIDE BLOCKING FOR SUPPORT. REFER TO PARTITION TYPES FOR MORE INFORMATION.
12. G.C. TO PROVIDE BLOCKING AS REQUIRED TO SUPPORT FIXTURES AND TO ATTACH TO WALLS AS REQUIRED TO PREVENT OVERTURNING.

FIXTURE PLAN KEY NOTES (#)

1. REFERENCE FIXTURE PACKAGE FOR DETAILS AND INSTALL GUIDELINES. REFER TO ELEVATIONS FOR ADDITIONAL FIXTURE MOUNTING HEIGHTS AND SPACING DIMENSIONS IN ADDITION TO FIXTURE PLAN. G.C. TO REFERENCE MILLWORK SHOP DRAWINGS, INSTALLATION DIAGRAMS, TEMPLATES, ETC. IN CONJUNCTION WITH THESE DRAWINGS.
2. LOCATION OF IT RACK (W/ PATCH PANEL), AV RACK, AND ASSOCIATED EQUIPMENT. ALL ACCESSIBLE WITHIN CABINET W/ DOORS. GC TO PROVIDE RACKS AND PATCH PANEL. OWNER TO PROVIDE EQUIPMENT. GC TO COORDINATE AND PROVIDE POWER/DATA RECEPTACLES.
3. STORAGE SCHEDULED TO BE 8' TALL; SEE VENDOR DRAWINGS FOR ADDITIONAL DETAILS
4. BACK OF HOUSE MOBILE & FIXED STORAGE UNITS, SHIPPING DESK, AND WALL MOUNTED SHELVING PROVIDED BY OTHERS. THE CEILING HEIGHT IN AREAS WITH MOVEABLE & FIXED RACKS STORAGE WILL BE 12'-0" MIN. NO STORAGE SHALL BE KEPT ON THE TOP SHELF WITHIN 18 INCHES OF A CEILING SPRINKLER.
5. PLUMBING FIXTURES AND RESTROOM ACCESSORIES EXISTING TO REMAIN.



45 WEST 21st STREET, SUITE 403
NEW YORK, NY 10010

IN ASSOCIATION WITH THE ARCHITECT:
R H SWEERS II, PROPRIETOR
R H SWEERS ARCHITECT

ALL DRAWINGS AND WRITTEN MATERIAL APPEARING HEREIN
CONSTITUTE ORIGINAL AND UNPUBLISHED WORK OF THE
ARCHITECT AND MAY NOT BE DUPLICATED, USED OR DISCLOSED
WITHOUT WRITTEN
CONSENT OF THE ARCHITECT. THIS DOCUMENT IS INTENDED
SOLELY FOR THE CONSTRUCTION OF THE PROJECT NAMED HEREIN
AND SHALL NOT BE USED BY ANY OTHER CONSTRUCTION WITHOUT
WRITTEN CONSENT OF THE ARCHITECT.
THIS DRAWING WAS PREPARED UNDER MY SUPERVISION AND I
DISCLAIM ANY RESPONSIBILITY FOR THE EXISTING BUILDING
CONSTRUCTION ELEMENTS, SITE CONDITIONS, OR ANY DOCUMENTS
WHICH DO NOT BEAR MY SEAL.

SEAL

ISSUE FOR BID

DRAWINGS ISSUED

No.	Rev	Date	Description
1		06.18.26	LL REVIEW SET
2		06.24.26	ISSUE FOR PERMIT
3		07.02.26	ISSUE FOR BID
4	1	07.28.26	BID ADDENDUM #1
5	2	08.27.26	BID ADDENDUM #2

PROJECT NAME:
TWP NAPLES

TWP


PROJECT ADDRESS:
WATERSIDE SHOPS
5455 TAMIAMI TRL N
NAPLES, FL 34108

DRAWING TITLE:
INTERIOR ELEVATIONS


SCALE: AS SHOWN

Project No.	26TWP05
Scale:	1/2" = 1'-0"
Date:	08-20-2026
Drawn By:	212
Checked BY:	212
DRAWING NO:	

A-601

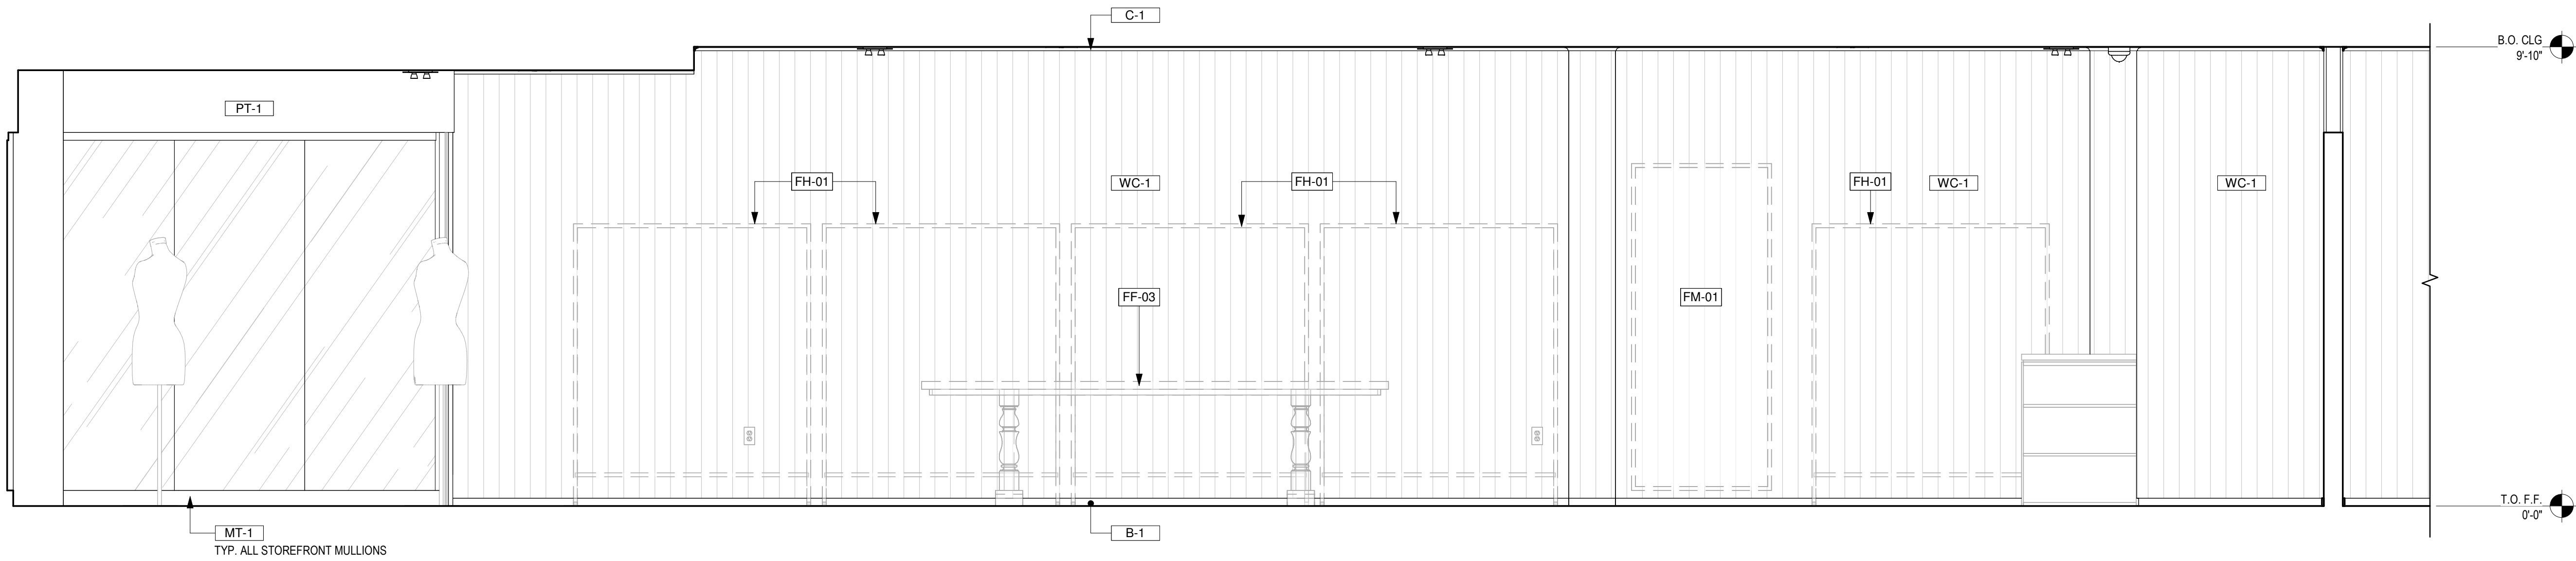


3 SALES - SOUTH ELEVATION
SCALE: 1/2" = 1'-0"

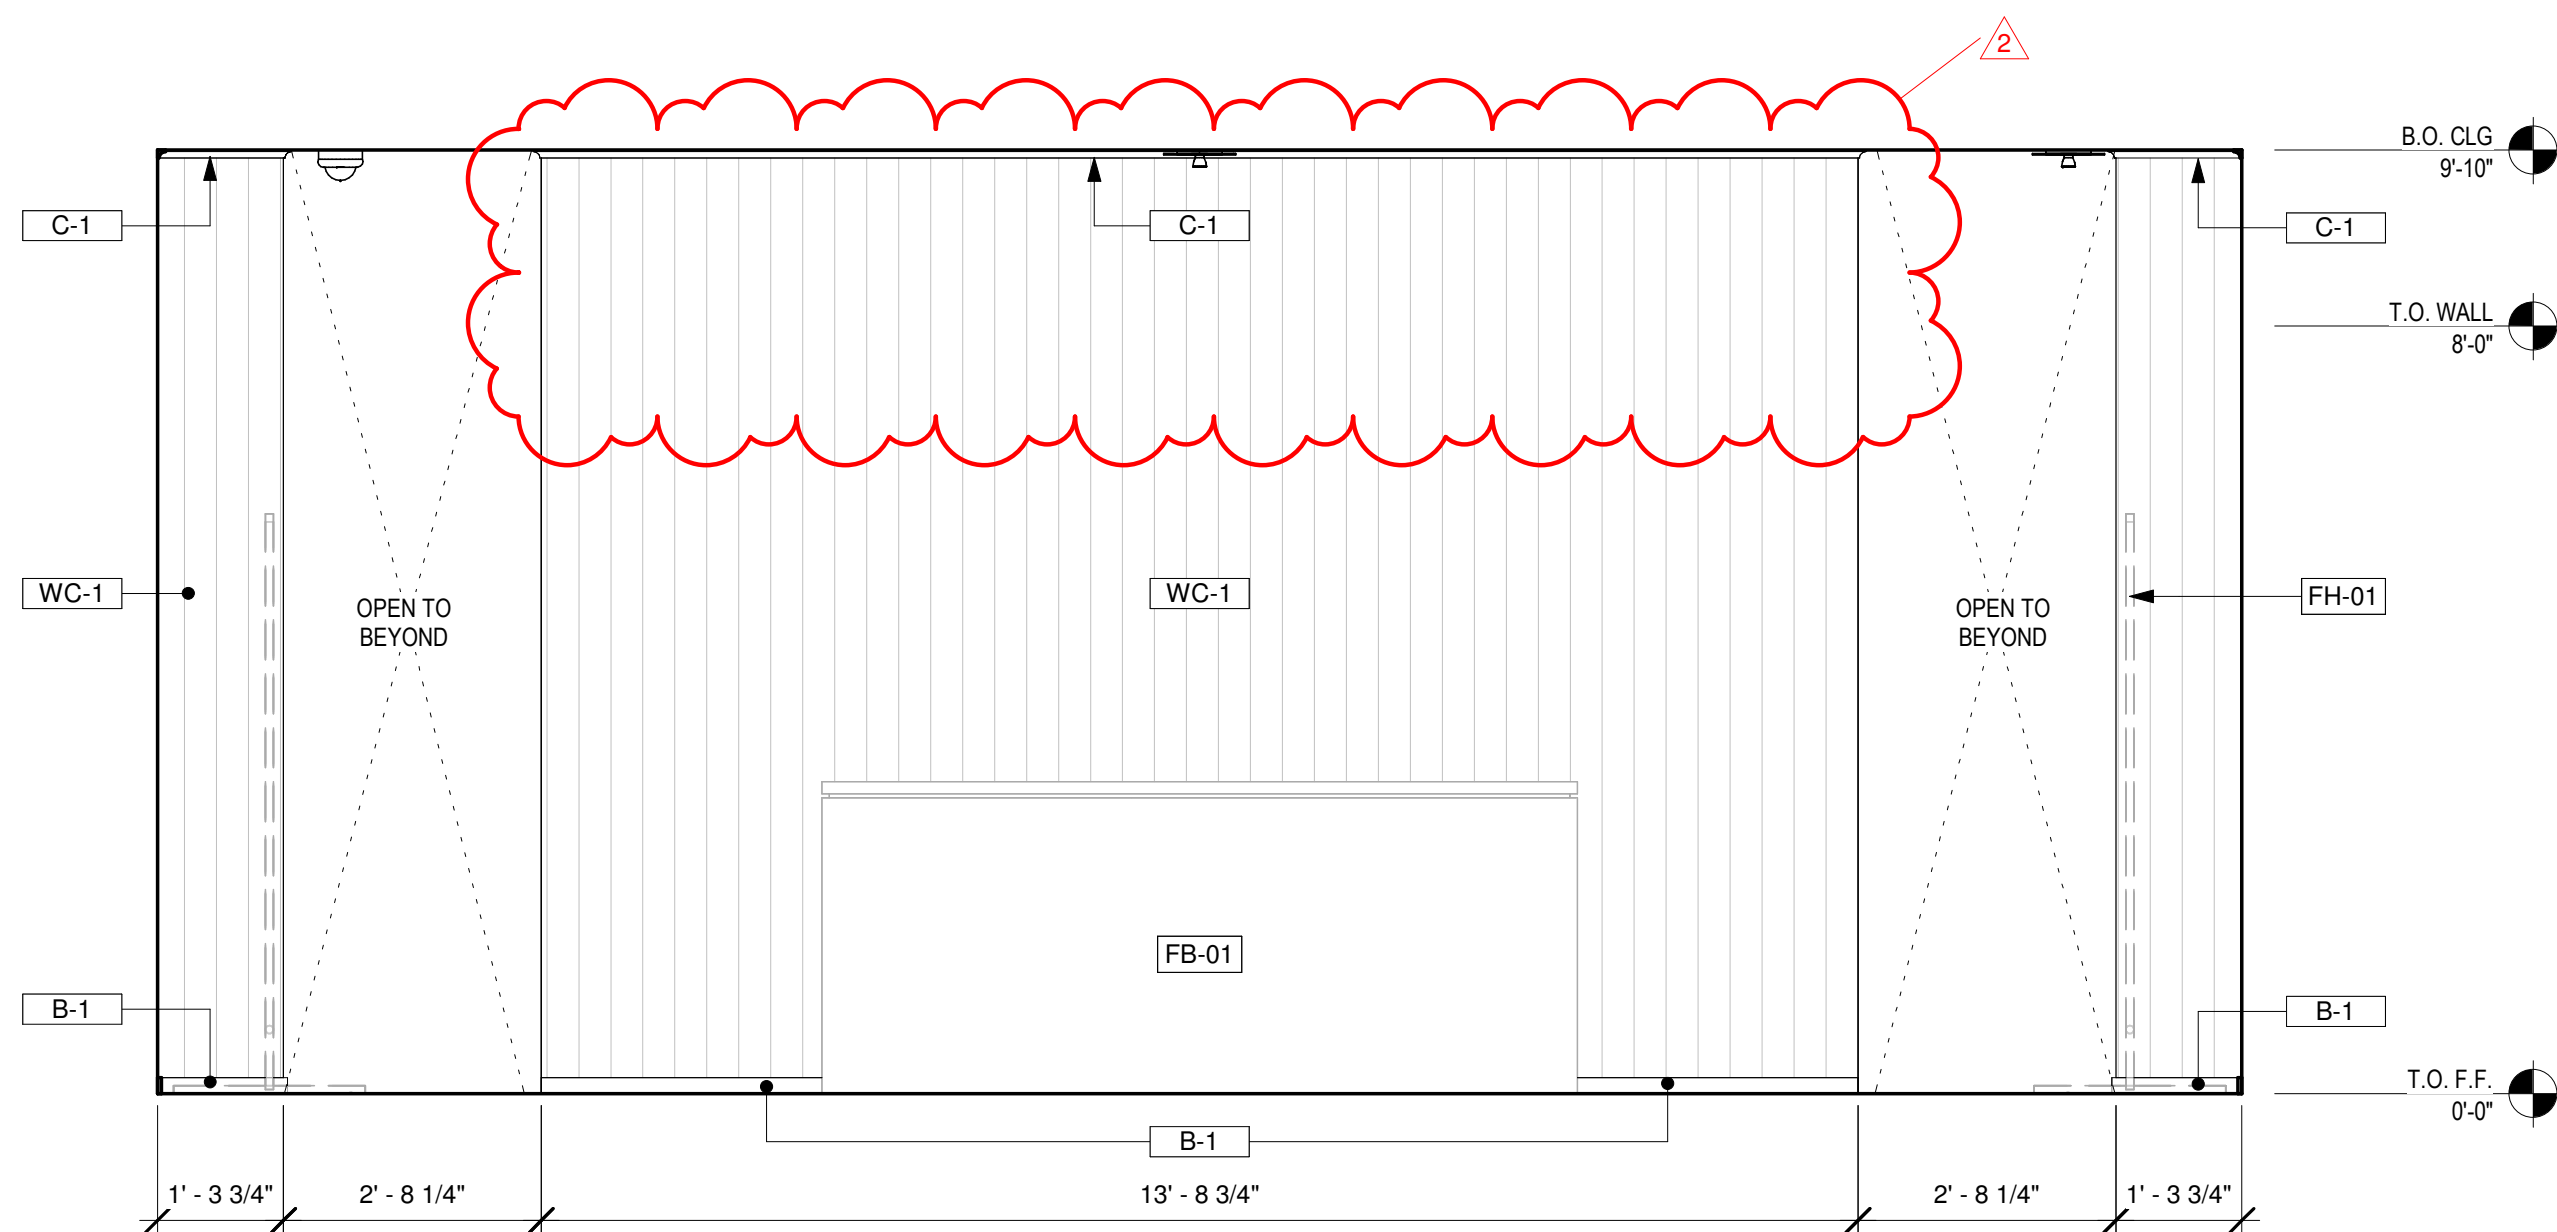


4 SALES - WEST ELEVATION
SCALE: 1/2" = 1'-0"


*SEE STOREFRONT PLANS FOR
MORE INFORMATION

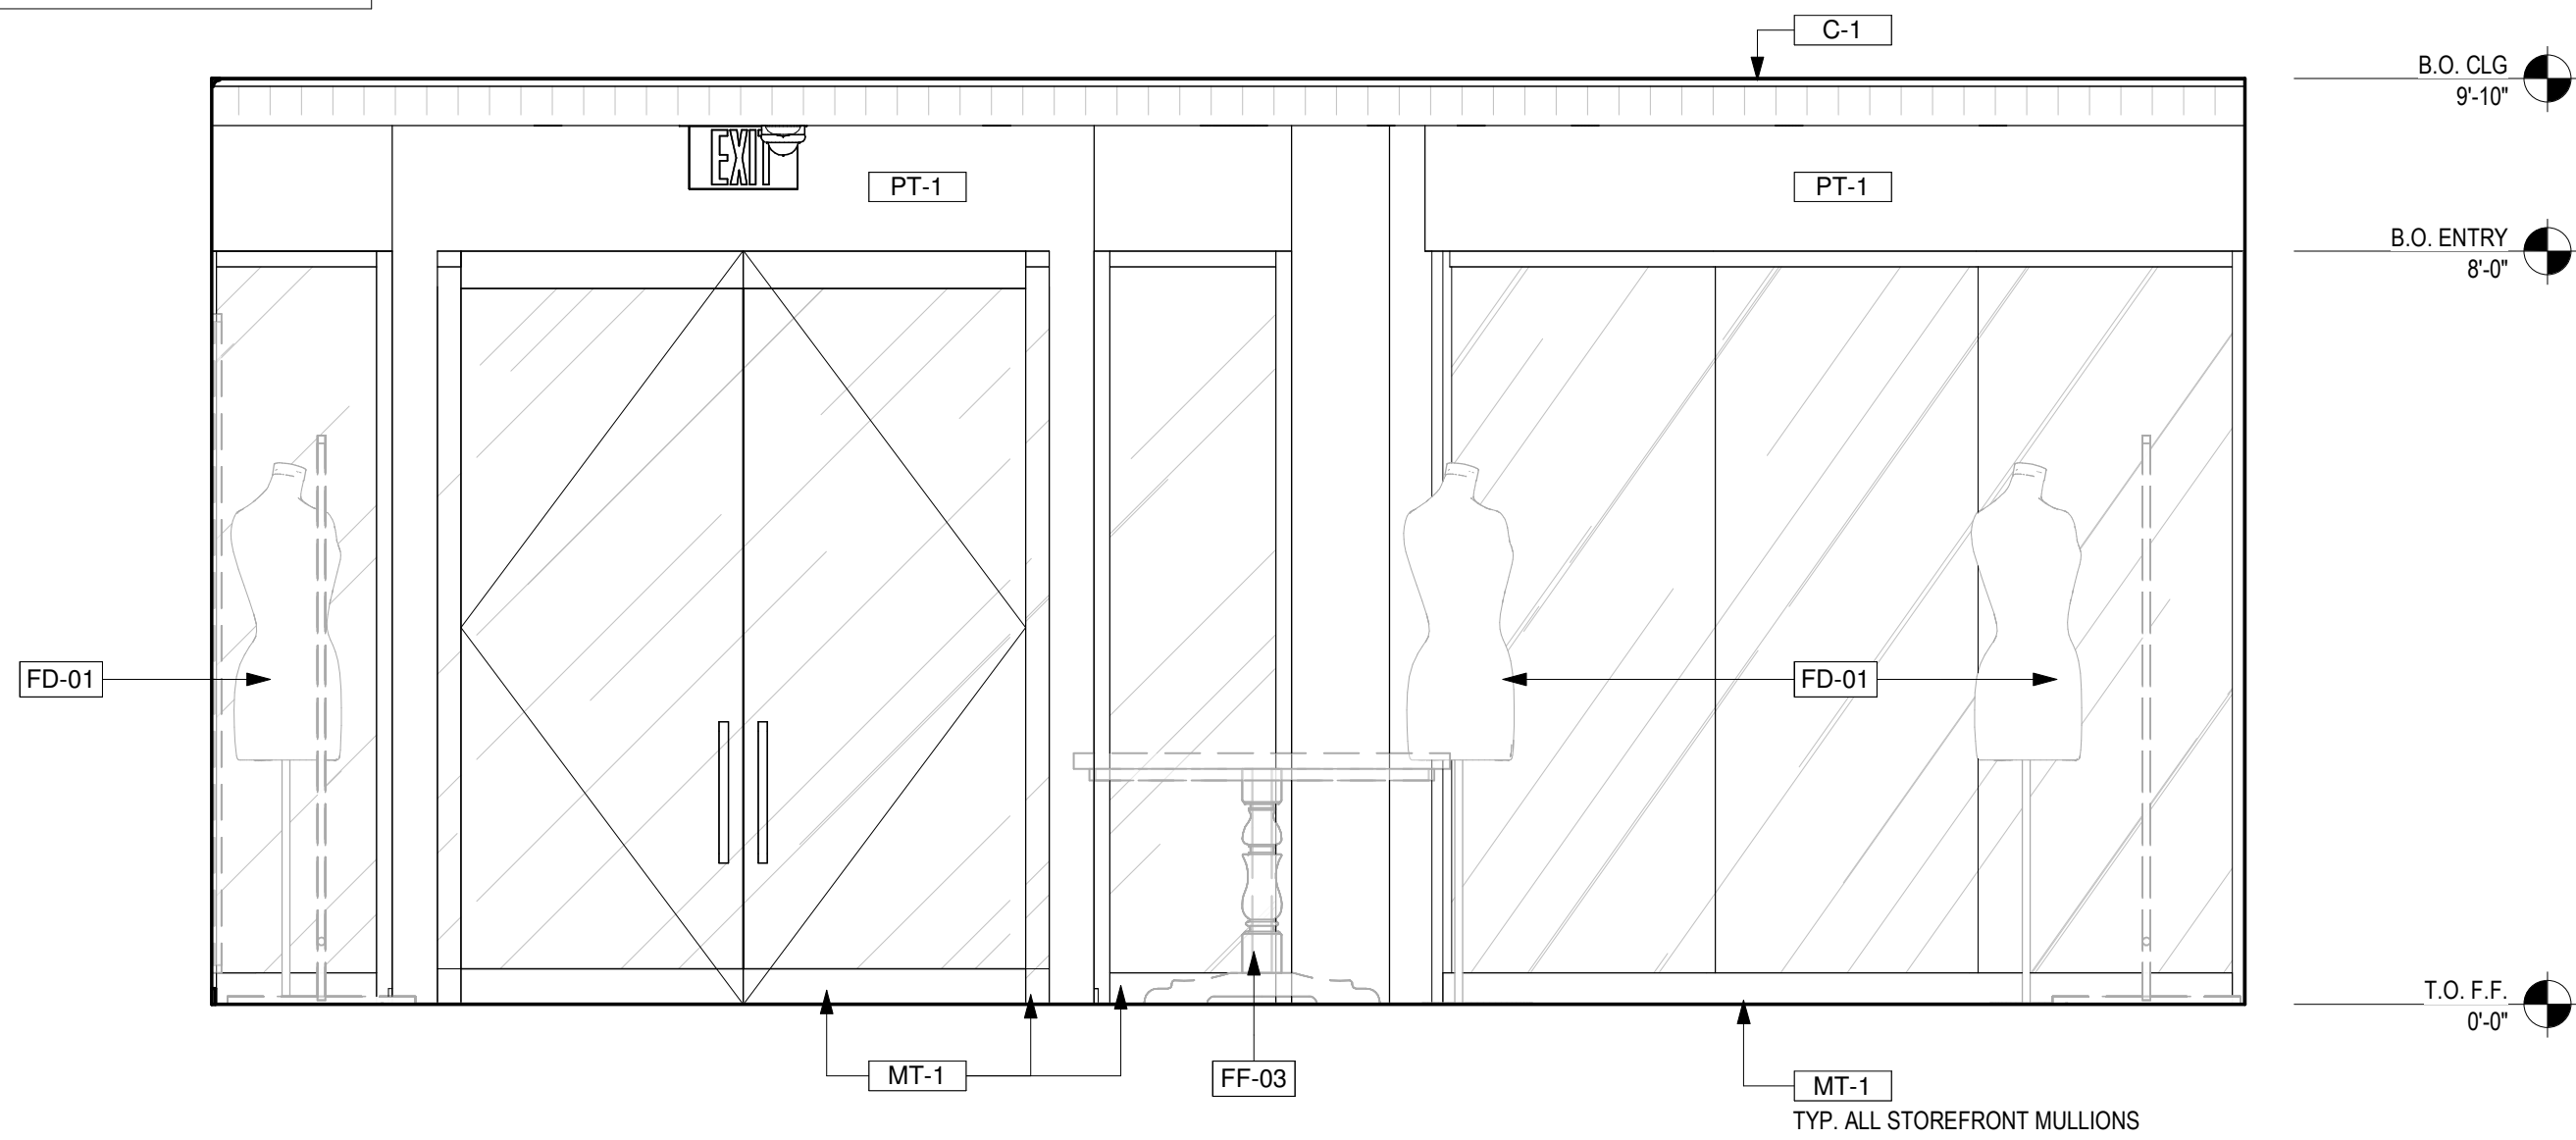

2 SALES - EAST ELEVATION
SCALE: 1/2" = 1'-0"

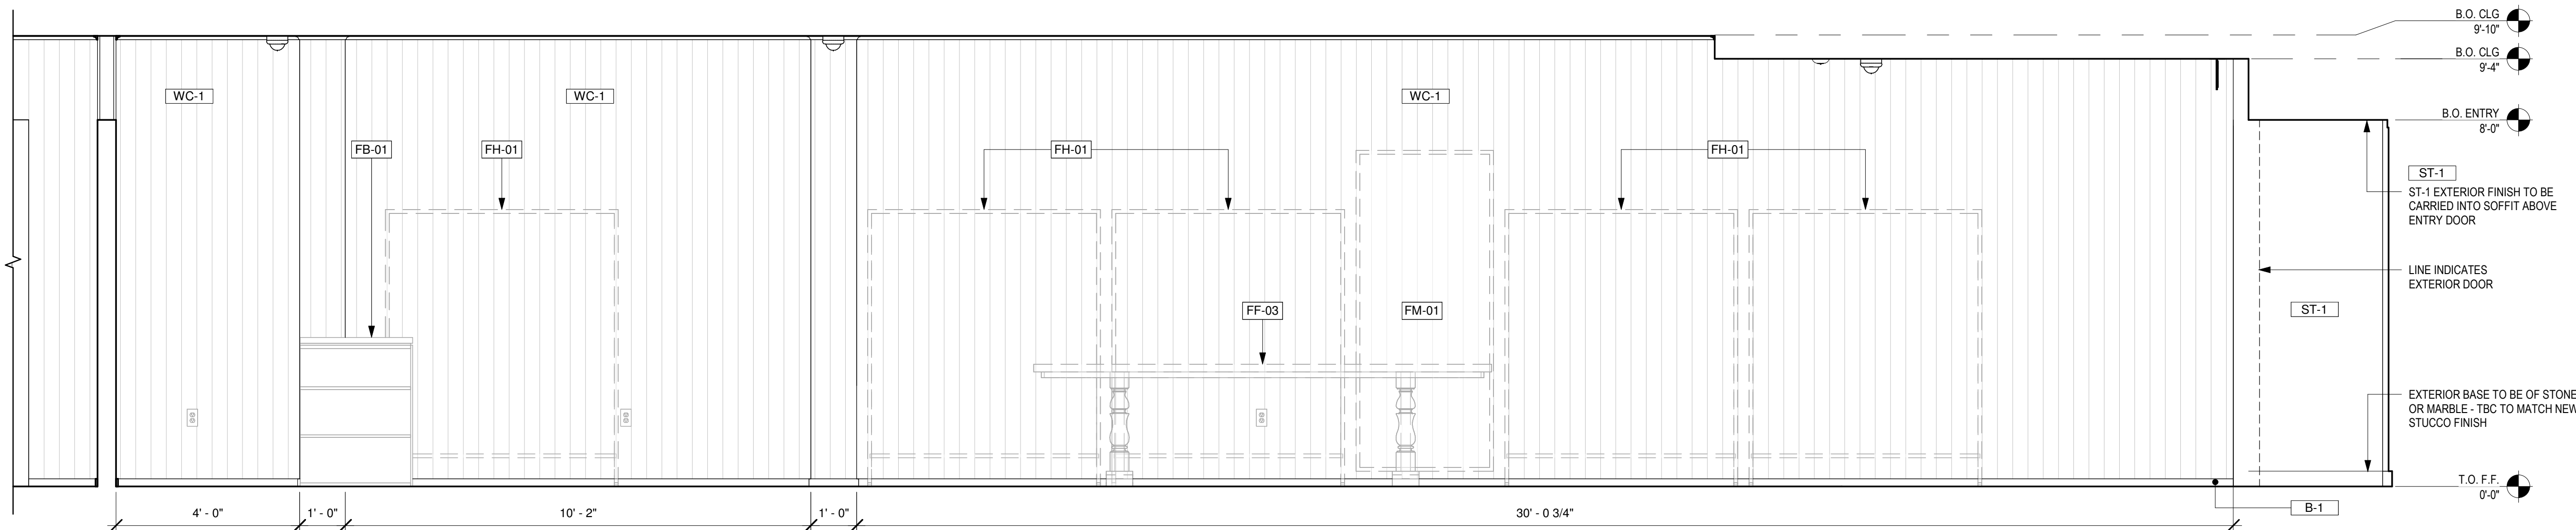

1 SALES - NORTH ELEVATION
SCALE: 1/2" = 1'-0"

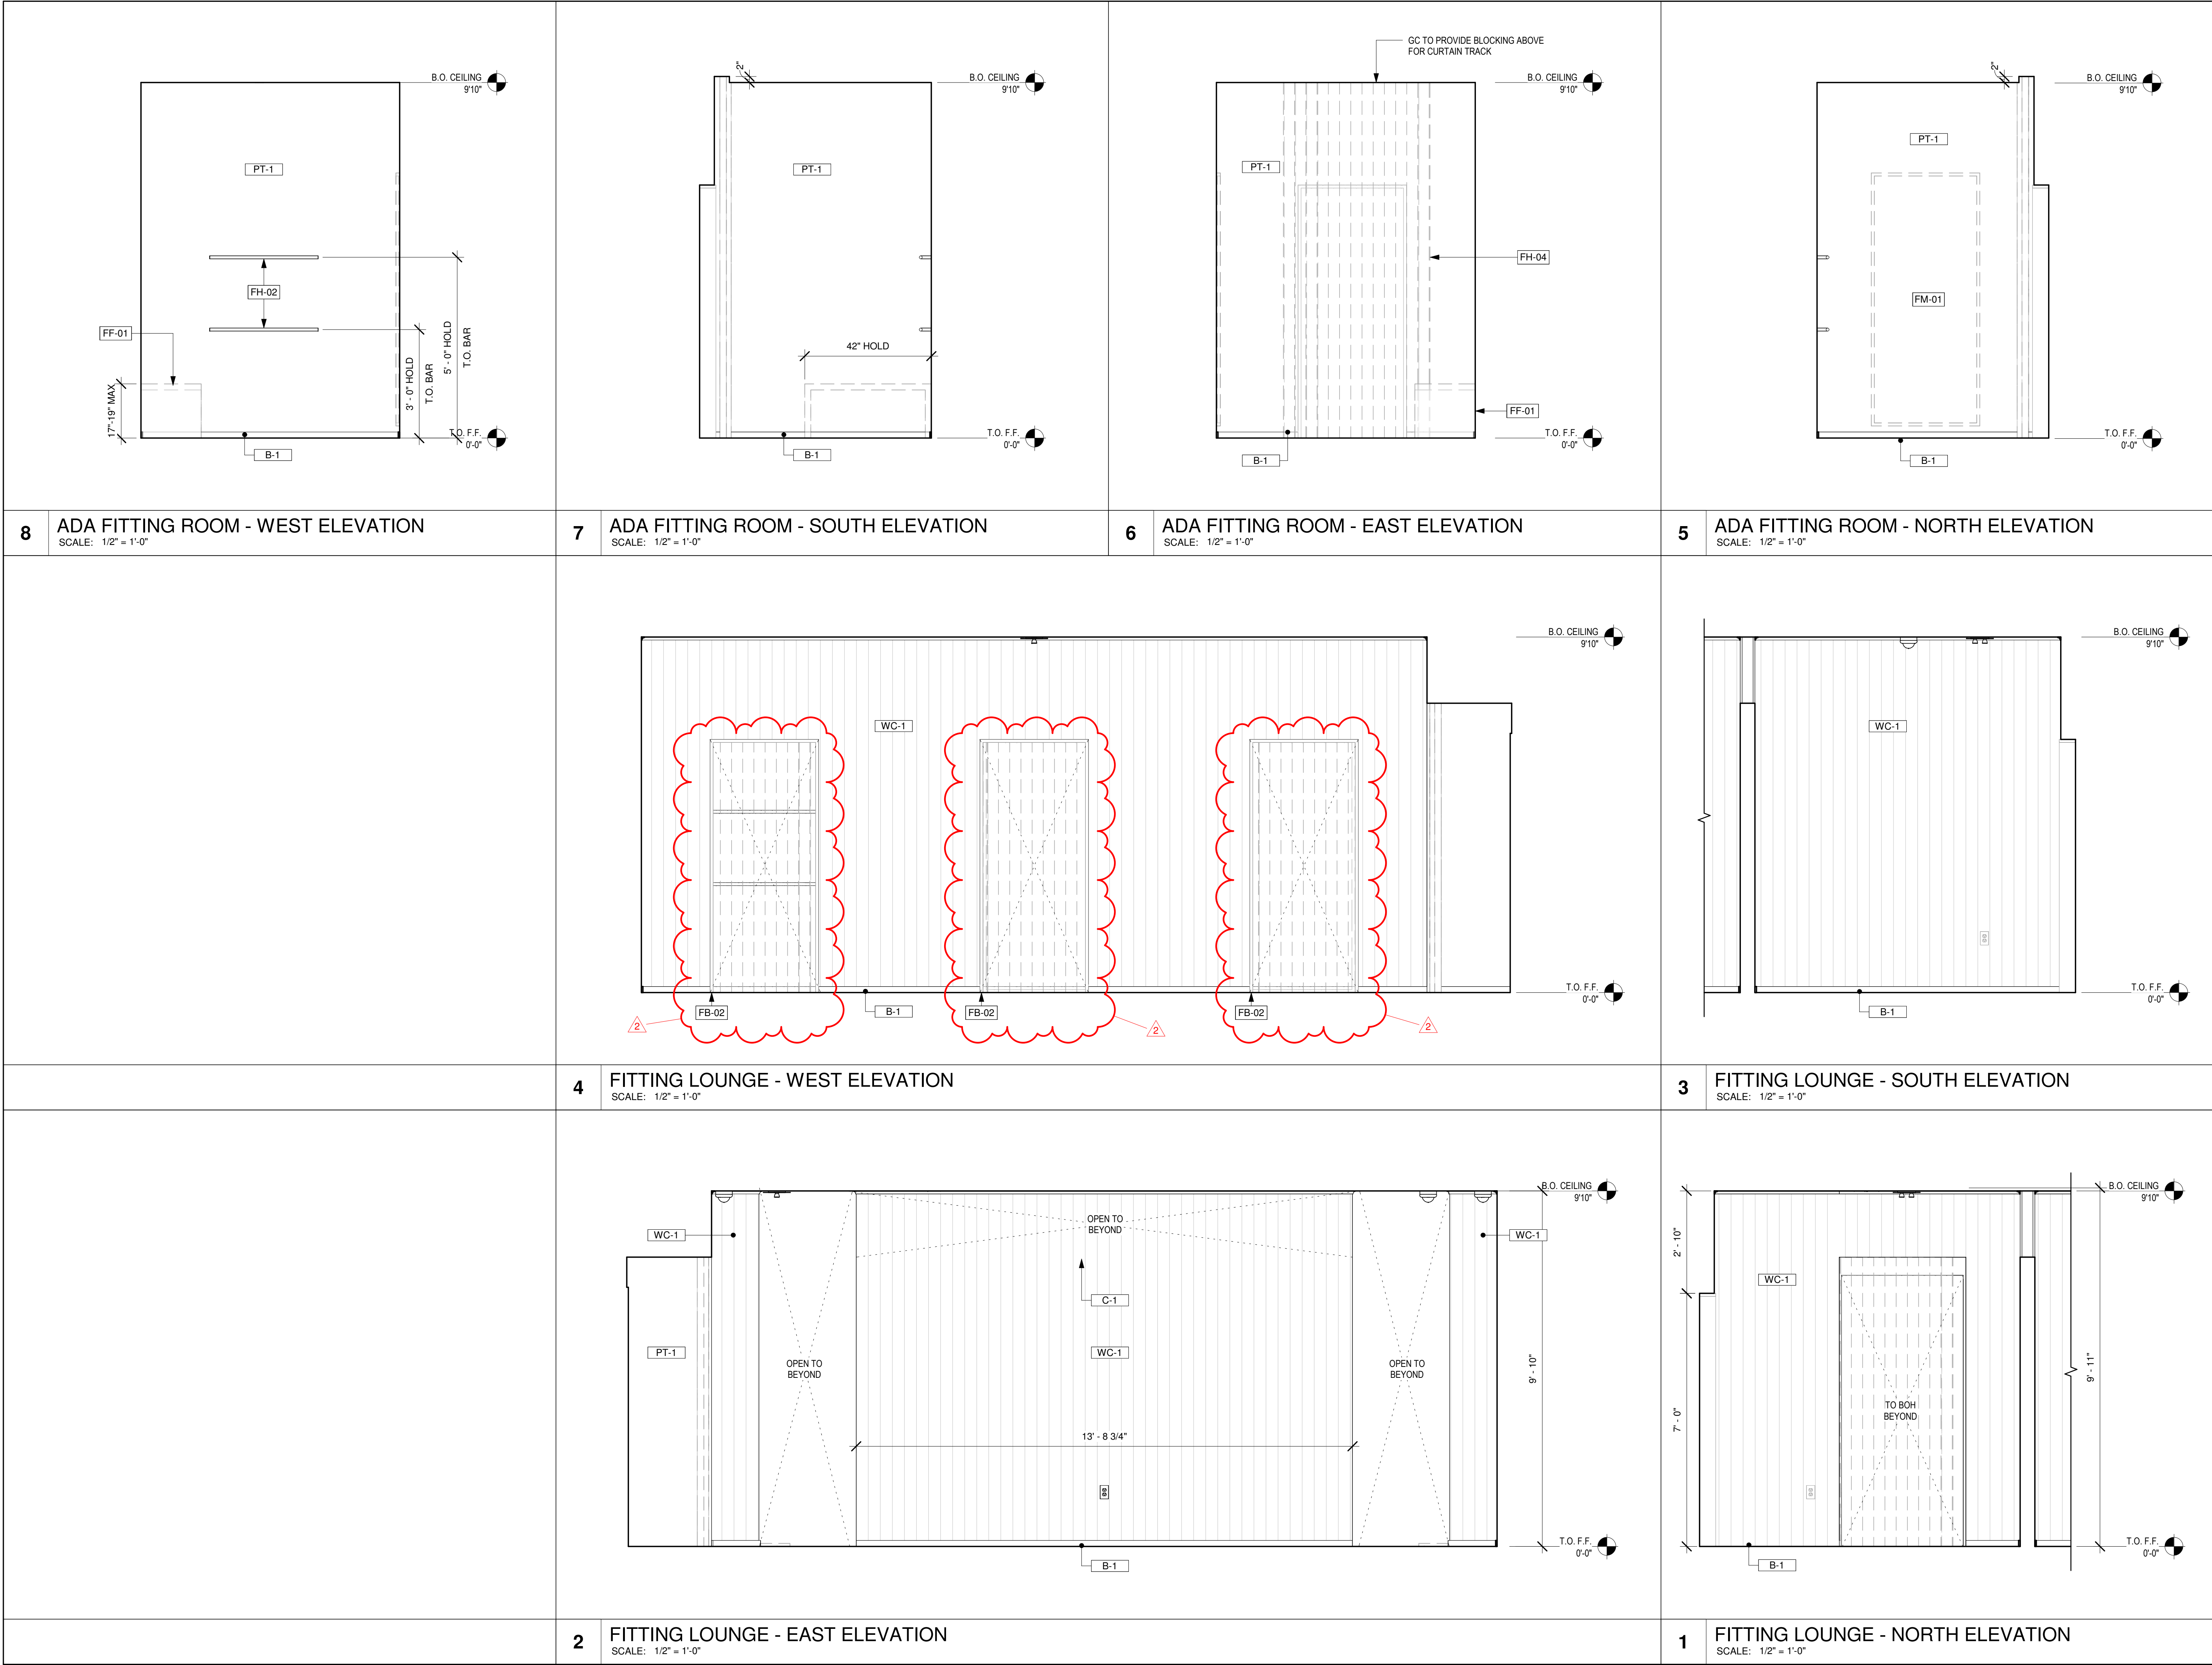

SEAL

ISSUE FOR BID

DRAWINGS ISSUED				
No.	Rev	Date	Description	
1		06.18.26	LL REVIEW SET	
2		06.24.26	ISSUE FOR PERMIT	
3		07.02.26	ISSUE FOR BID	
4	1	07.28.26	BID ADDENDUM #1	
5	2	08.27.26	BID ADDENDUM #2	


PROJECT NAME:
TWP NAPLES

TWP

PROJECT ADDRESS:
WATERSIDE SHOPS
5455 TAMIAMI TRL N
NAPLES, FL 34108

DRAWING TITLE:
INTERIOR ELEVATIONS

SCALE: AS SHOWN	
Project No.	26TWP05
Scale:	1/2" = 1'-0"
Date:	08-20-2026
Drawn By:	212
Checked By:	212
DRAWING NO:	

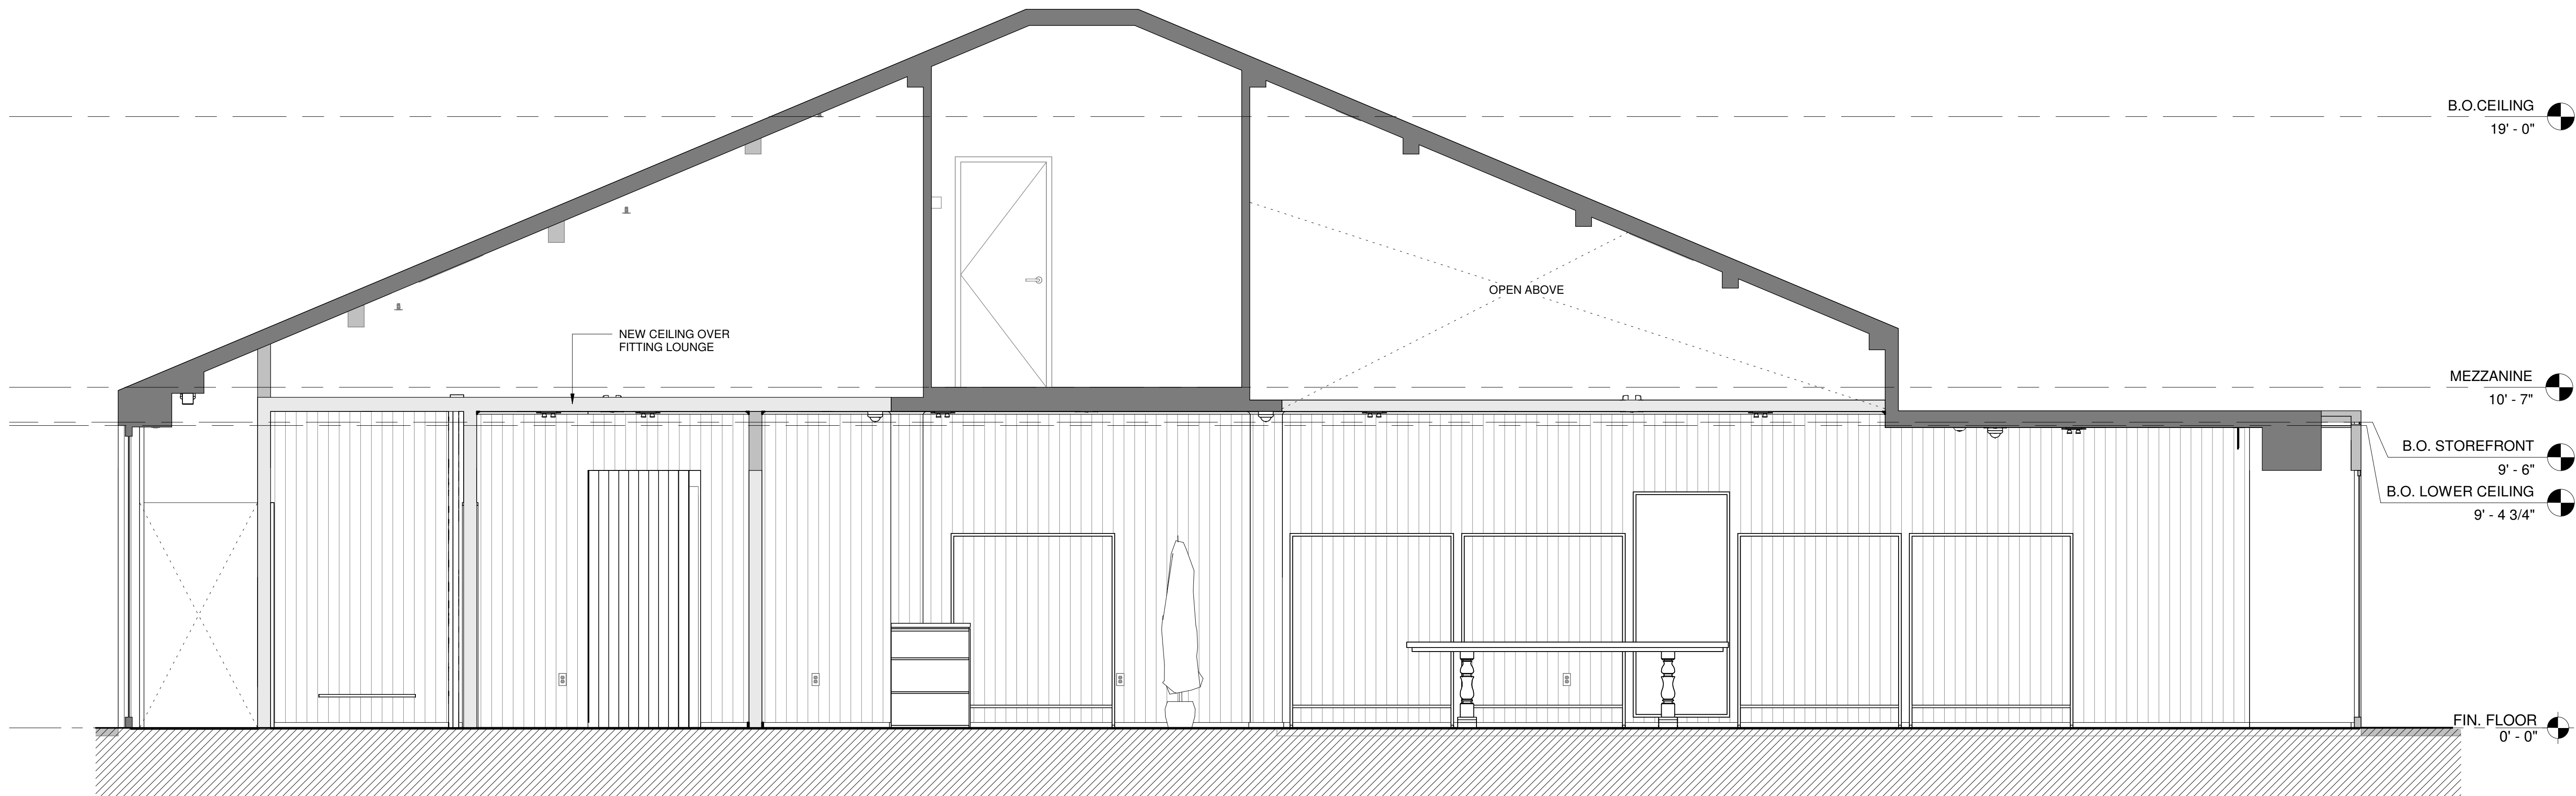

1 OVERALL BUILDING SECTION
SCALE: 3/8" = 1'-0"

ISSUE FOR BID

TWO ONE TWO

45 WEST 21st STREET, SUITE 403
NEW YORK, NY 10010

IN ASSOCIATION WITH THE ARCHITECT:

R H SWEERS II, PROPRIETOR

R H SWEERS ARCHITECT

ALL DRAWINGS AND WRITTEN MATERIAL APPEARING HEREIN
CONSTITUTE ORIGINAL AND UNPUBLISHED WORK OF THE
ARCHITECT AND MAY NOT BE DUPLICATED, USED OR DISCLOSED
WITHOUT WRITTEN
CONSENT OF THE ARCHITECT. THIS DOCUMENT IS INTENDED
SOLELY FOR THE CONSTRUCTION OF THE PROJECT NAMED HEREIN
AND SHALL NOT BE USED BY ANY OTHER CONSTRUCTION WITHOUT
WRITTEN CONSENT OF THE ARCHITECT.

THIS DRAWING WAS PREPARED UNDER MY SUPERVISION AND I
DISCLAIM ANY RESPONSIBILITY FOR THE EXISTING BUILDING
CONSTRUCTION ELEMENTS, SITE CONDITIONS, OR ANY DOCUMENTS
WHICH DO NOT BEAR MY SEAL.

SEAL

DRAWINGS ISSUED			
No.	Rev	Date	Description
1		06.18.26	LL REVIEW SET
2		06.24.26	ISSUE FOR PERMIT
3		07.02.26	ISSUE FOR BID


PROJECT NAME:
TWP NAPLES

TWP


PROJECT ADDRESS:
WATERSIDE SHOPS
5455 TAMIAMI TRL N
NAPLES, FL 34108

DRAWING TITLE:	
BUILDING SECTION	
SCALE: AS SHOWN	
Project No.	26TWP05
Scale:	3/8" = 1'-0"
Date:	08-20-2026
Drawn By:	212
Checked BY:	212
DRAWING NO:	


A-610

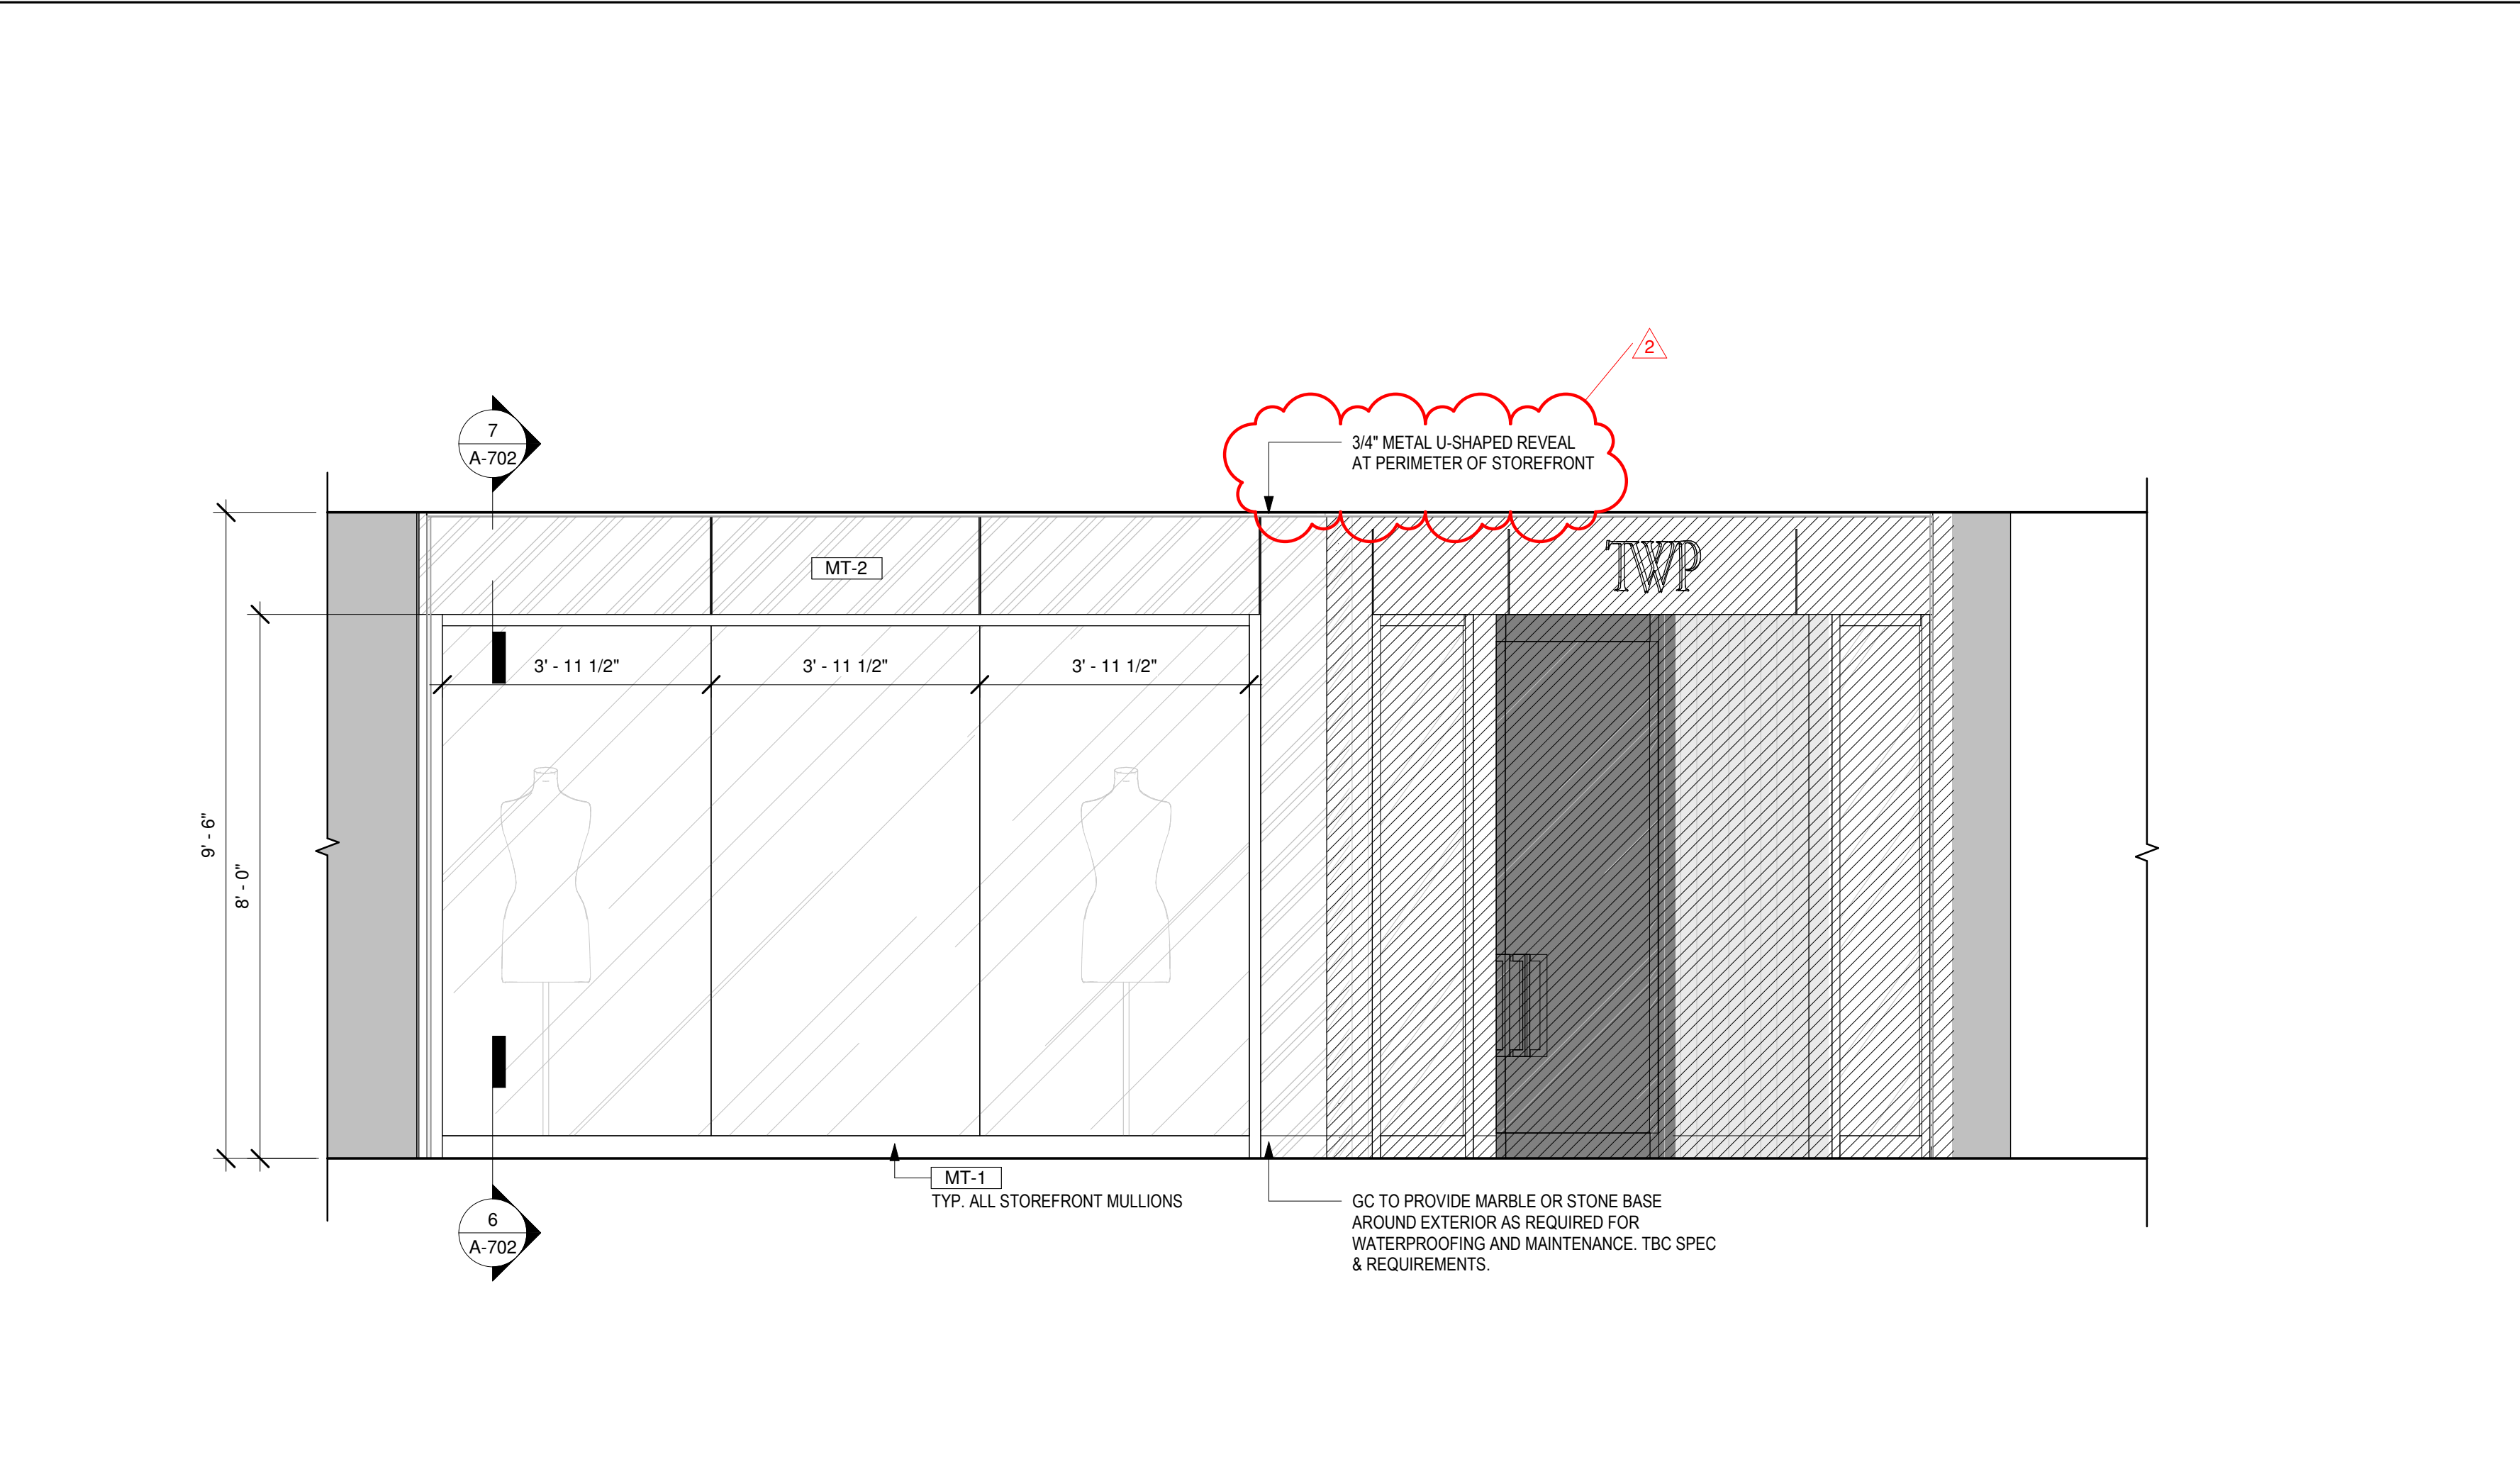

3 STOREFRONT ELEVATION - SOUTH
SCALE: 1/2" = 1'-0"

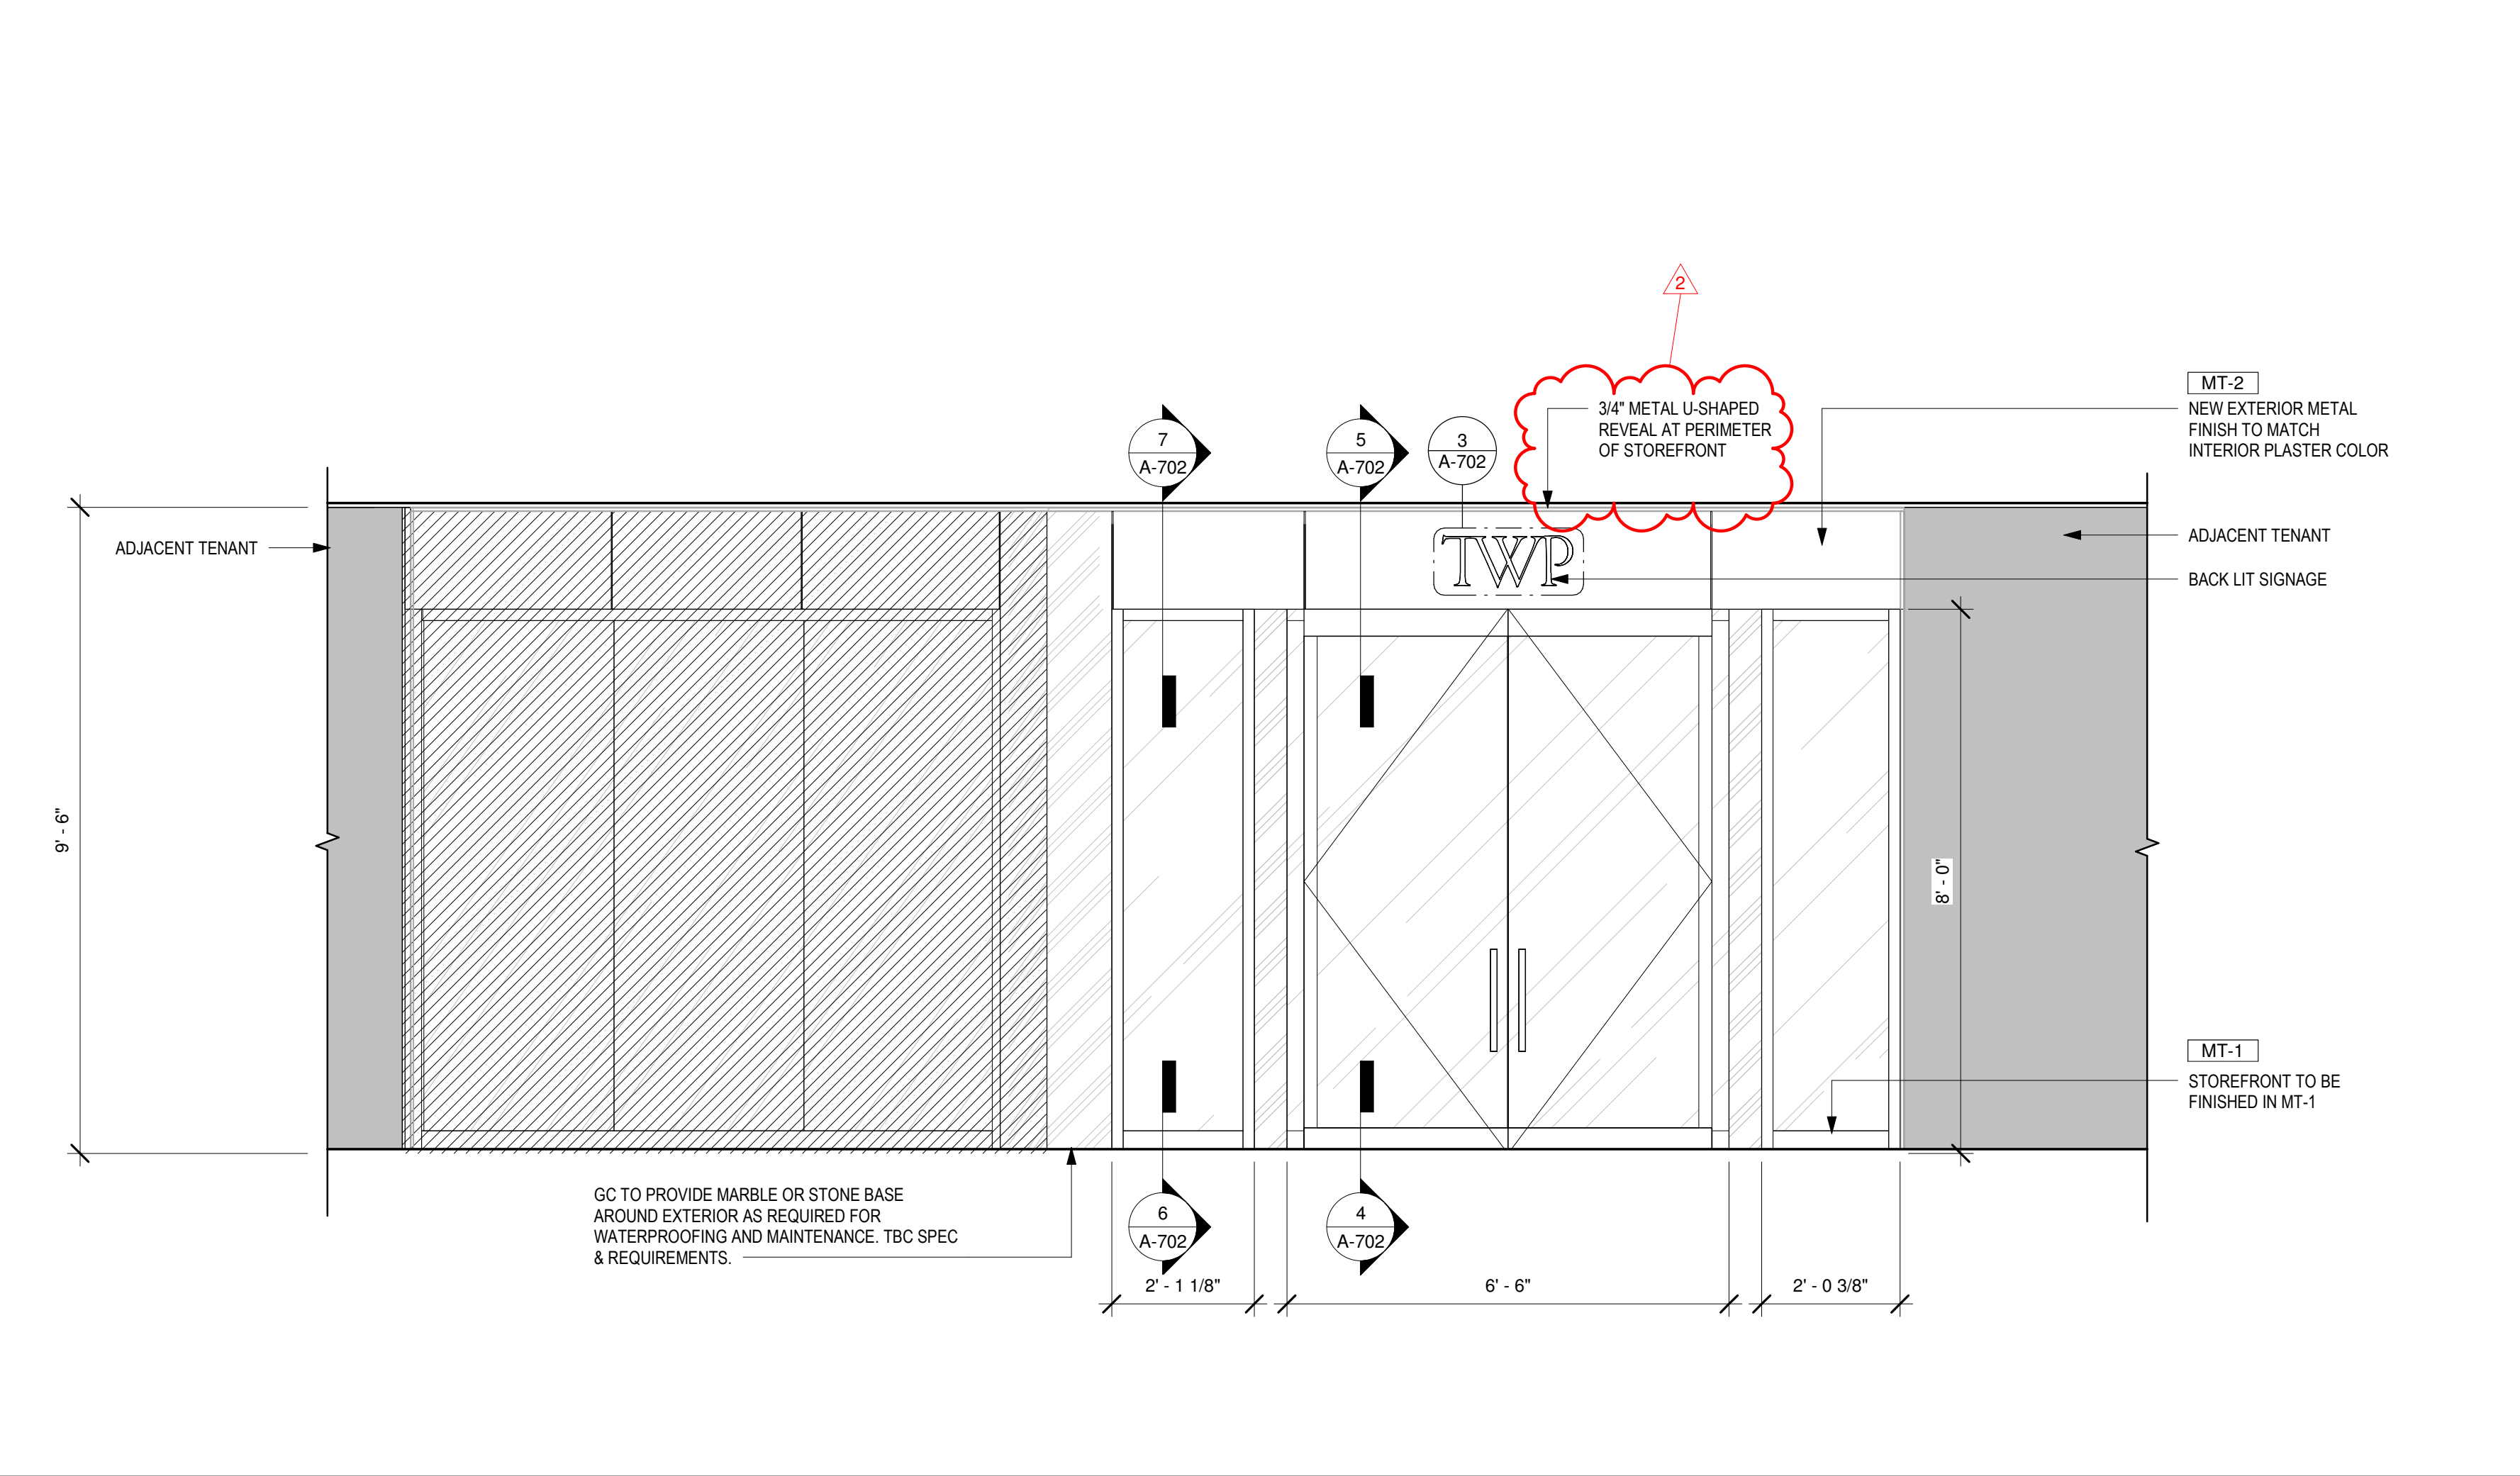

2 STOREFRONT ELEVATION - ENTRY
SCALE: 1/2" = 1'-0"

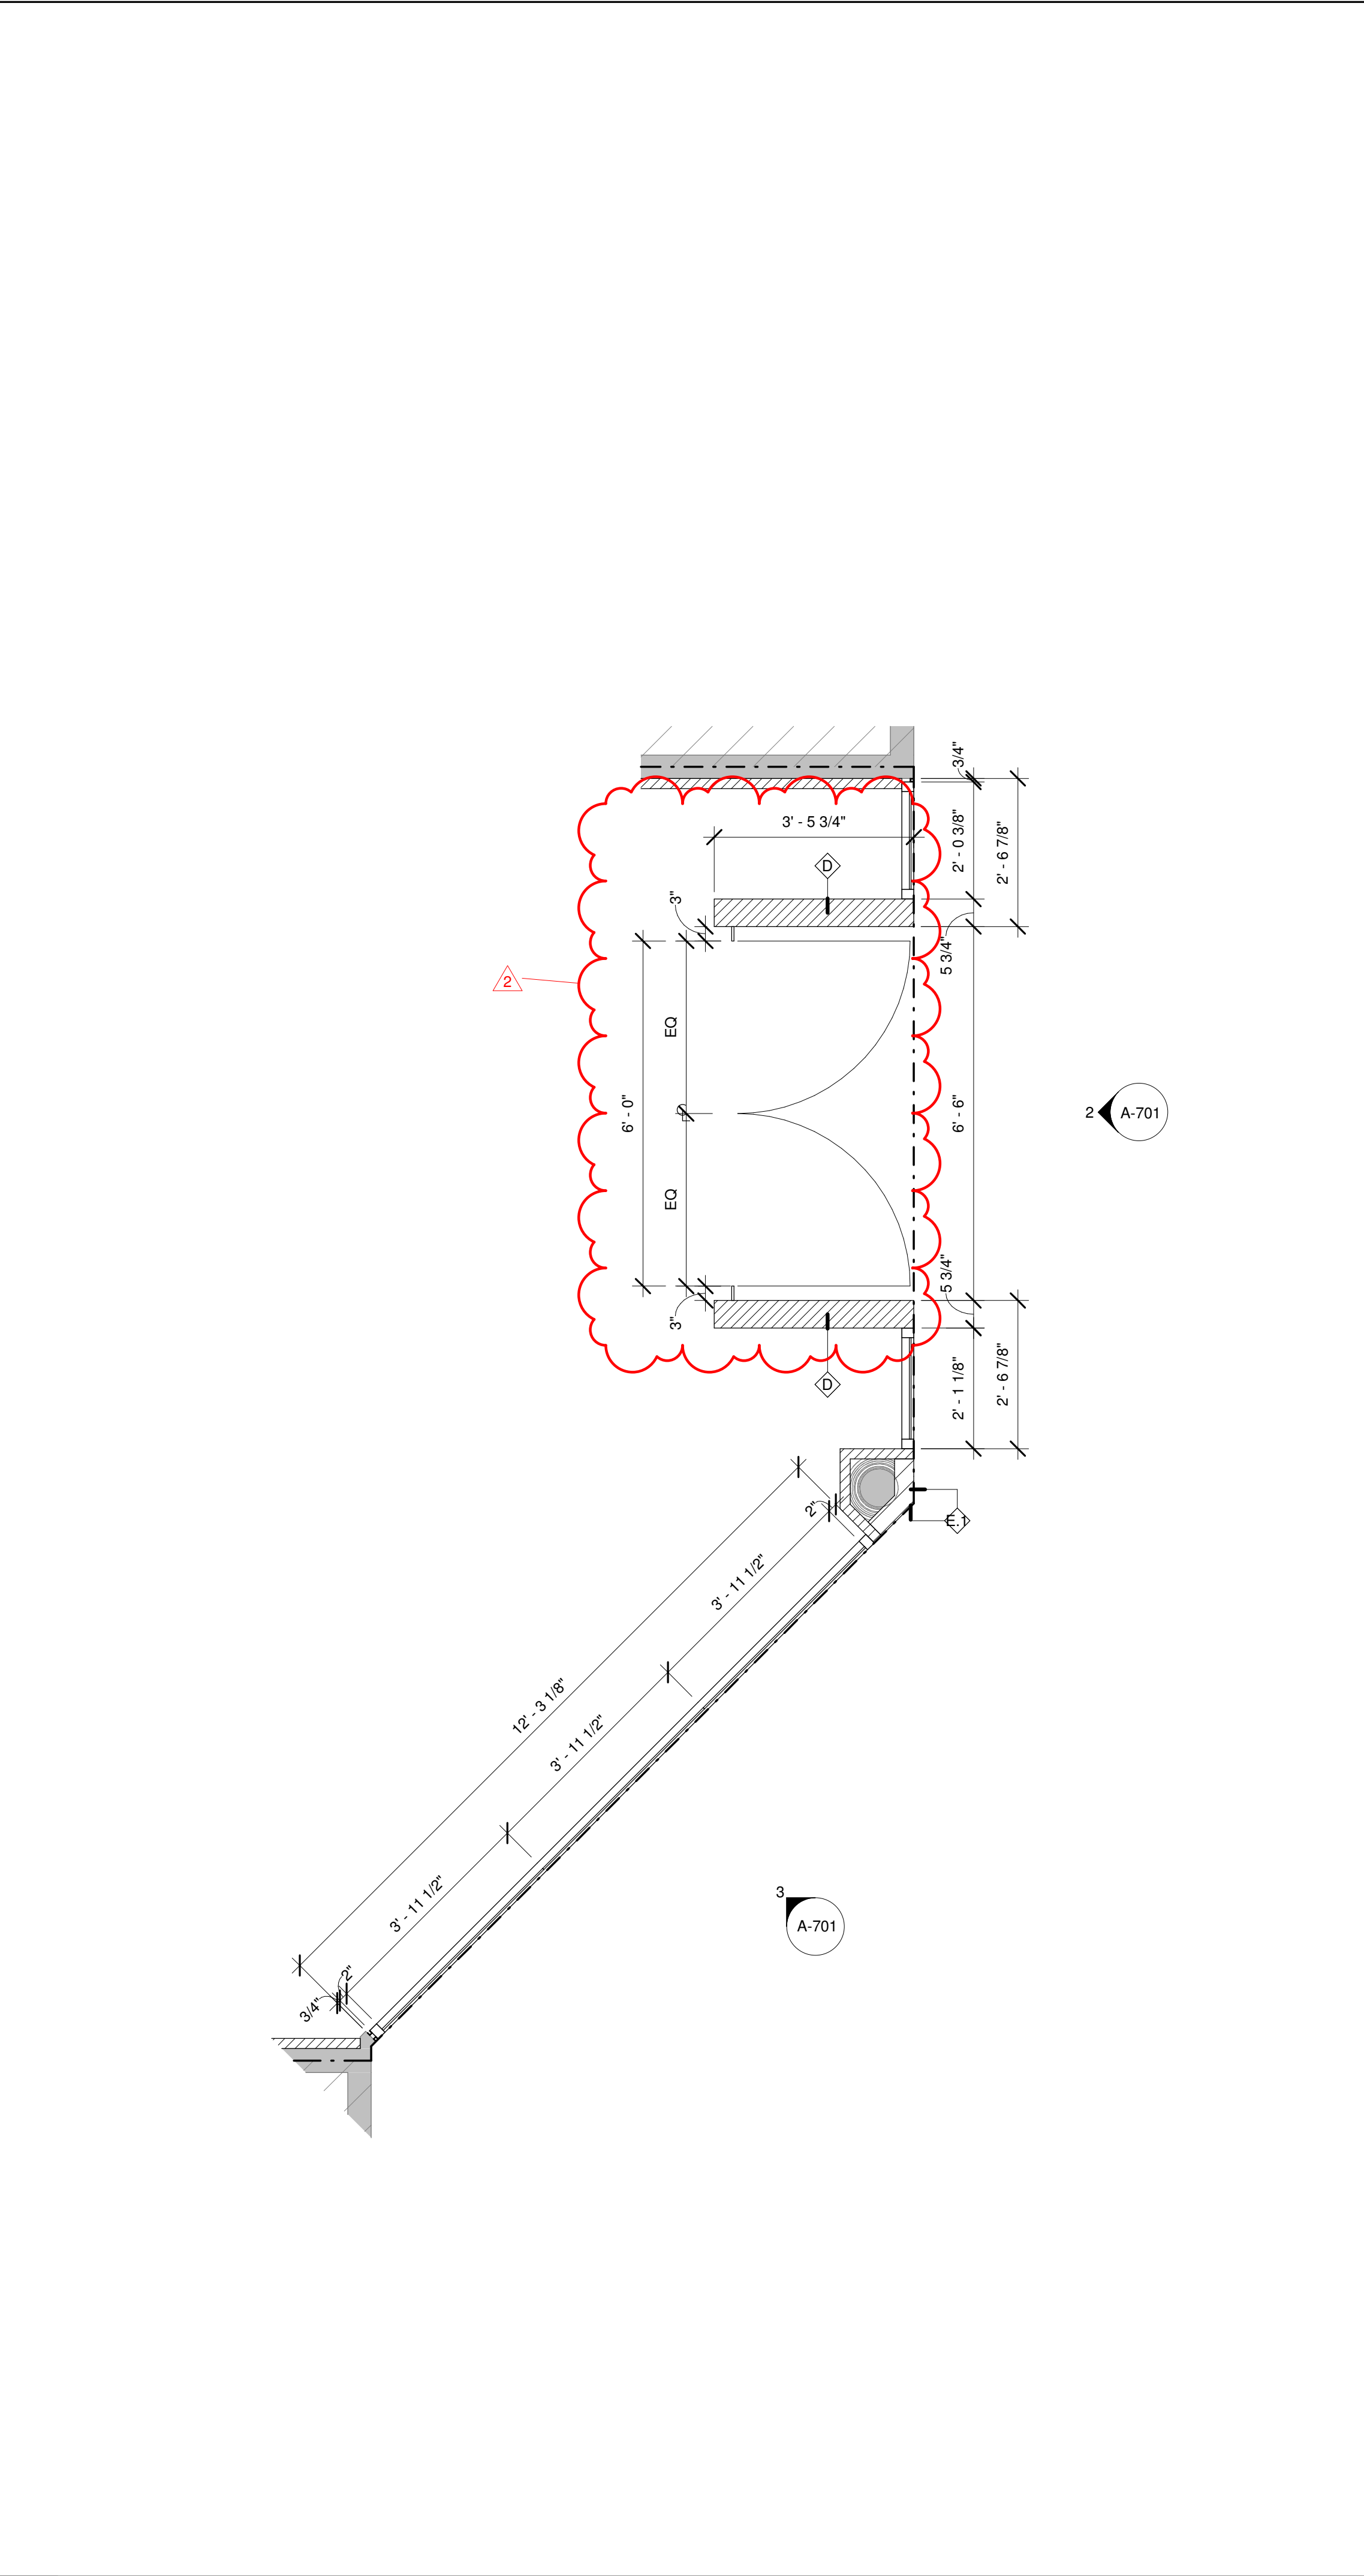

1 ENLARGED STOREFRONT PLAN
SCALE: 1/2" = 1'-0"

TWO ONE TWO

45 WEST 21st STREET, SUITE 403
NEW YORK, NY 10010

IN ASSOCIATION WITH THE ARCHITECT:

R H SWEERS II, PROPRIETOR

R H SWEERS ARCHITECT

ALL DRAWINGS AND WRITTEN MATERIAL APPEARING HEREIN
CONSTITUTE ORIGINAL AND UNPUBLISHED WORK OF THE
ARCHITECT AND MAY NOT BE DUPLICATED, USED OR DISCLOSED
WITHOUT WRITTEN
CONSENT OF THE ARCHITECT. THIS DOCUMENT IS INTENDED
SOLELY FOR THE CONSTRUCTION OF THE PROJECT NAMED HEREIN
AND SHALL NOT BE USED BY ANY OTHER CONSTRUCTION WITHOUT
WRITTEN CONSENT OF THE ARCHITECT.

THIS DRAWING WAS PREPARED UNDER MY SUPERVISION AND I
DISCLAIM ANY RESPONSIBILITY FOR THE EXISTING BUILDING
CONSTRUCTION ELEMENTS, SITE CONDITIONS, OR ANY DOCUMENTS
WHICH DO NOT BEAR MY SEAL.

SEAL

ISSUE FOR BID

DRAWINGS ISSUED

No.	Rev	Date	Description
1		06.18.26	LL REVIEW SET
2		06.24.26	ISSUE FOR PERMIT
3		07.02.26	ISSUE FOR BID
4	1	07.28.26	BID ADDENDUM #1
5	2	08.27.26	BID ADDENDUM #2

PROJECT NAME:

TWP NAPLES

TWP

PROJECT ADDRESS:

WATERSIDE SHOPS

5455 TAMIAMI TRL N

NAPLES, FL 34108

DRAWING TITLE:








STOREFRONT PLAN & ELEVATION

SCALE: AS SHOWN

Project No.	26TWP05
Scale:	1/2" = 1'-0"
Date:	08-20-2026
Drawn By:	212
Checked BY:	212

DRAWING NO:

A-701

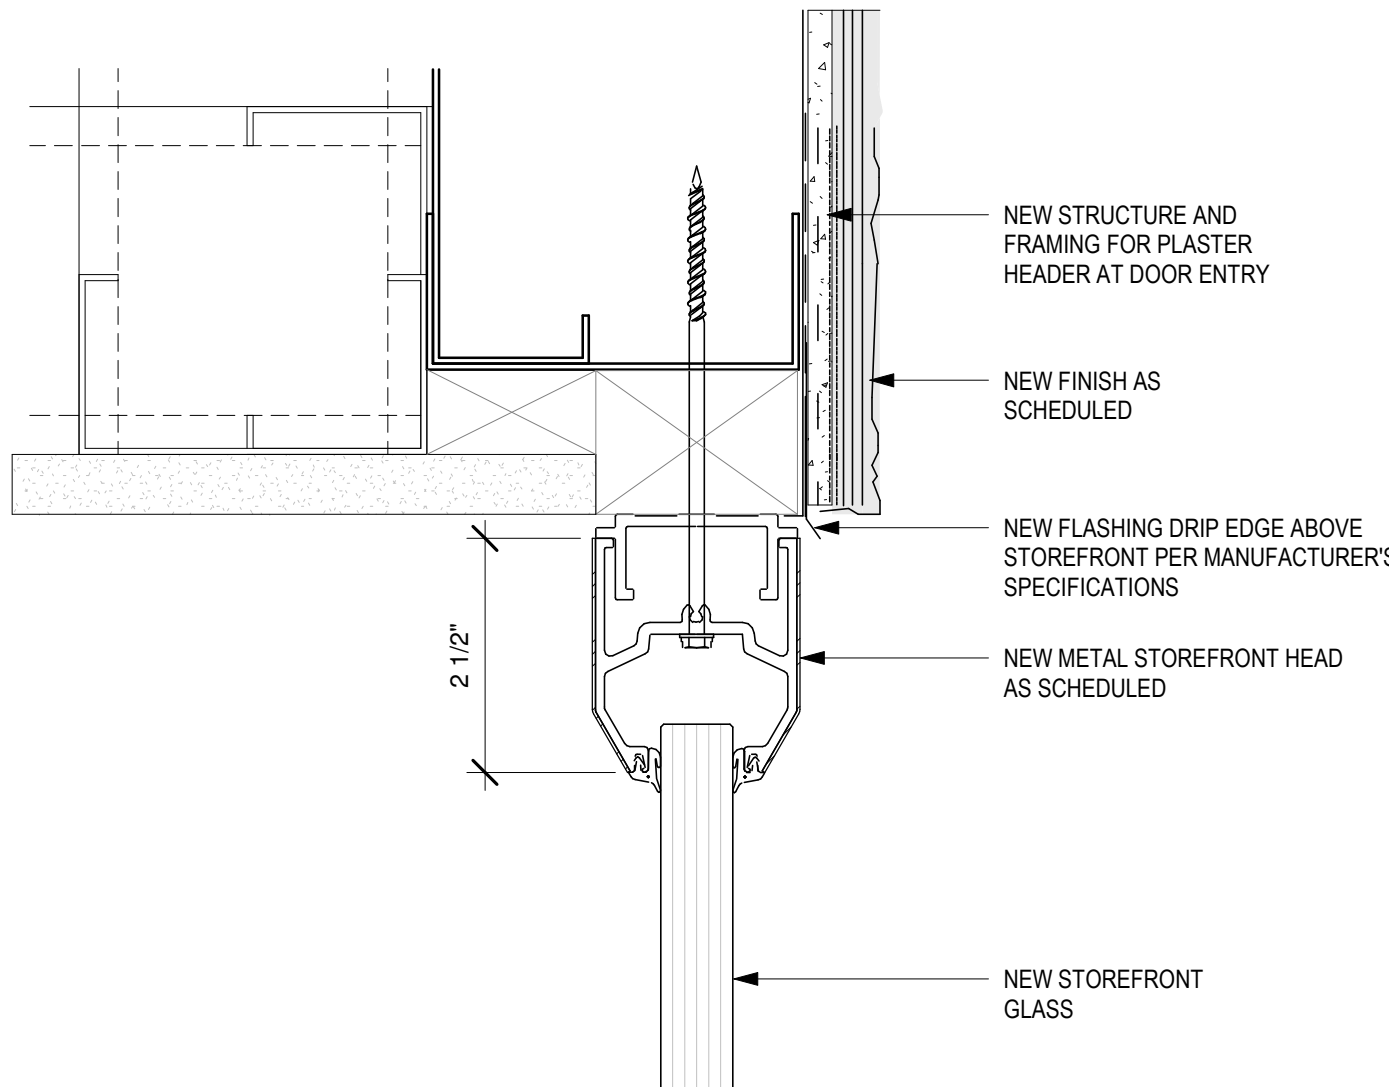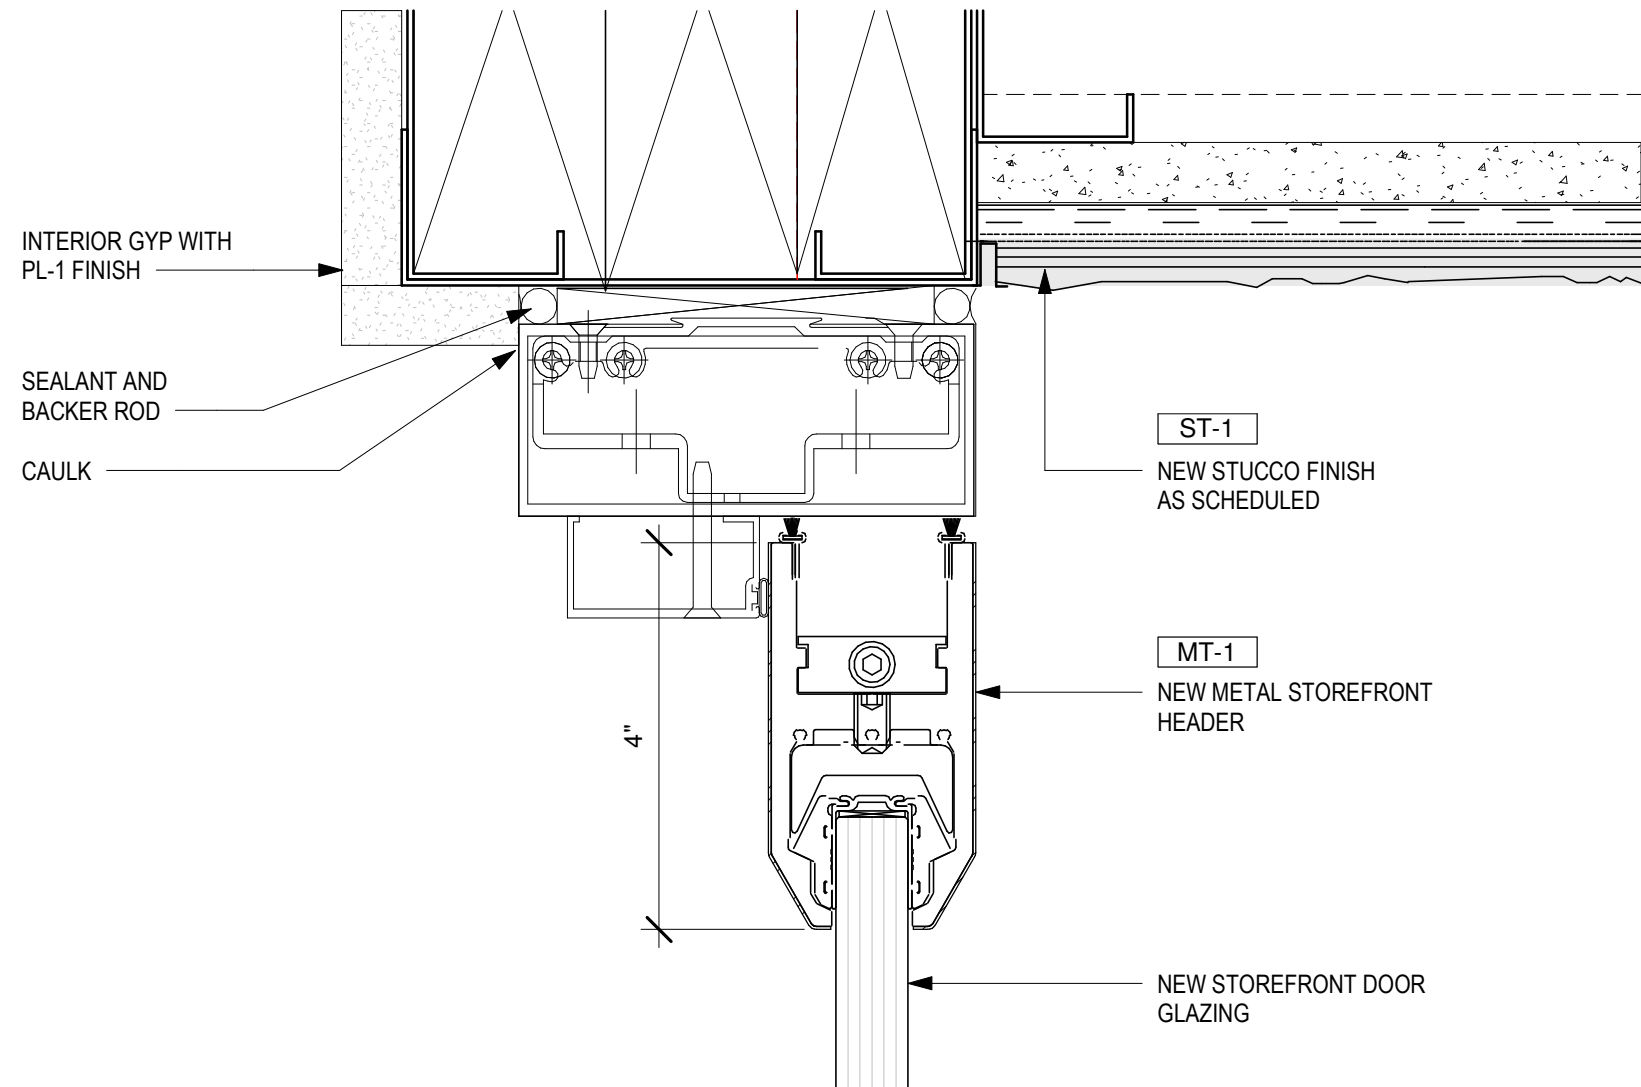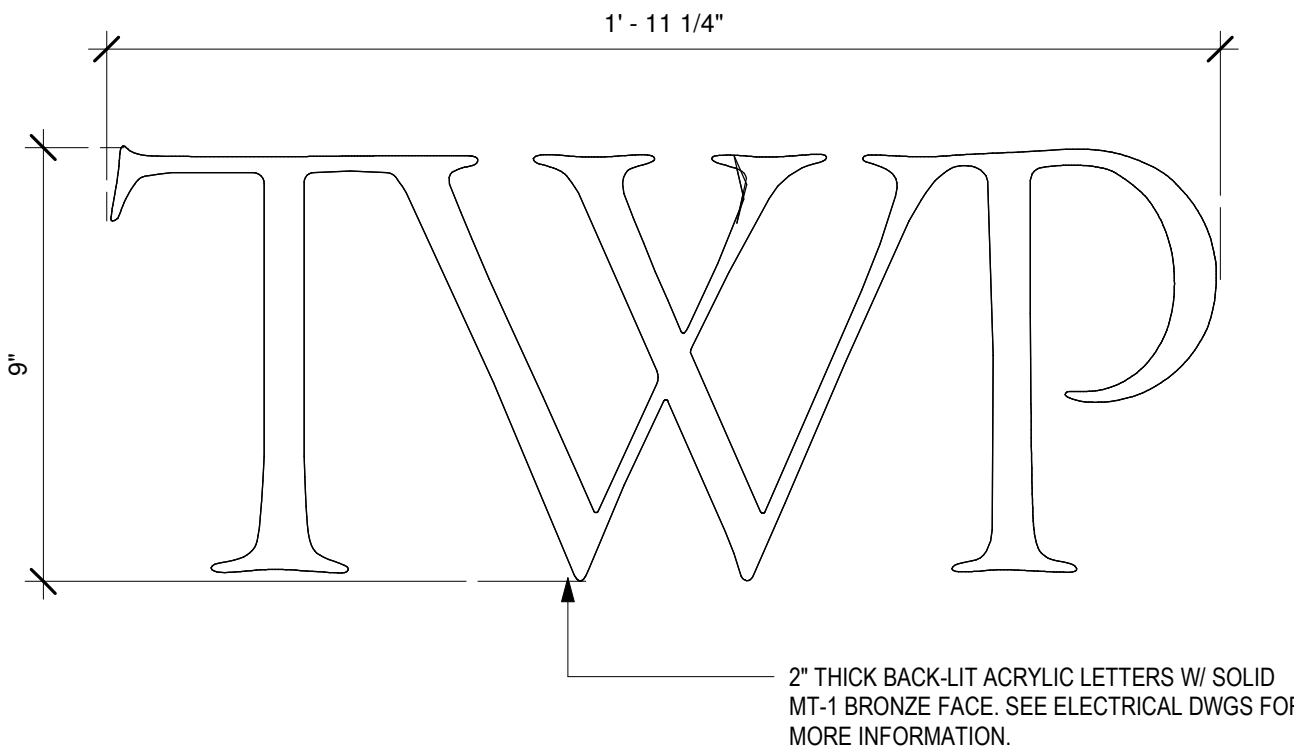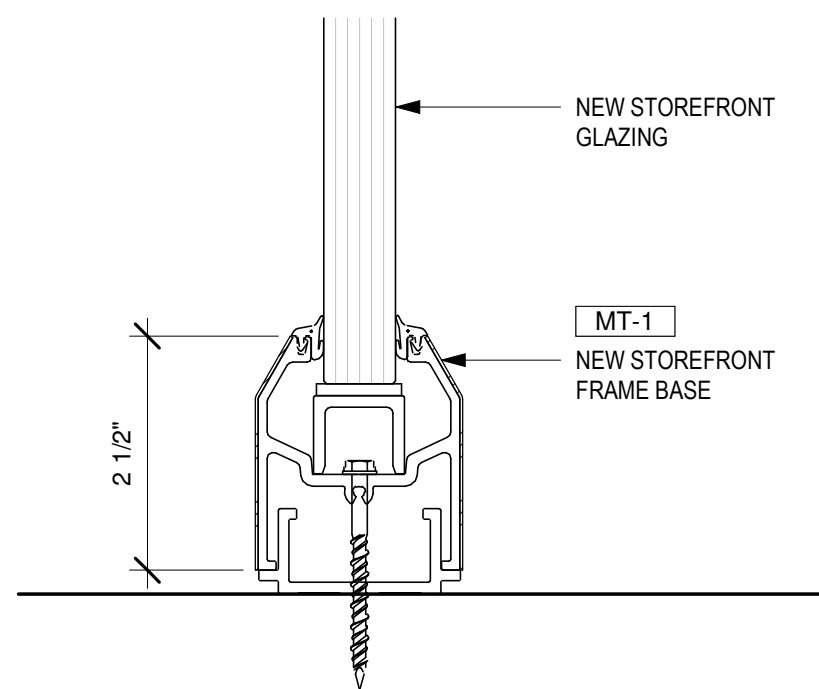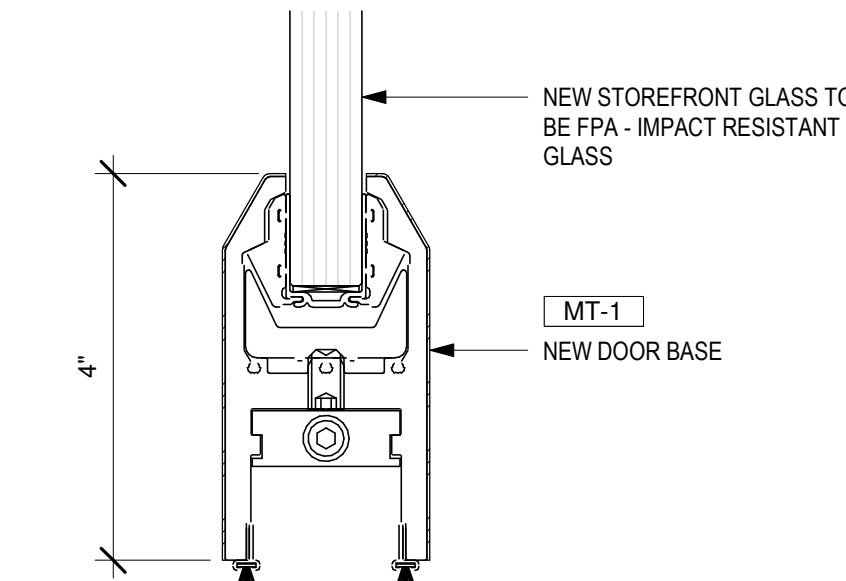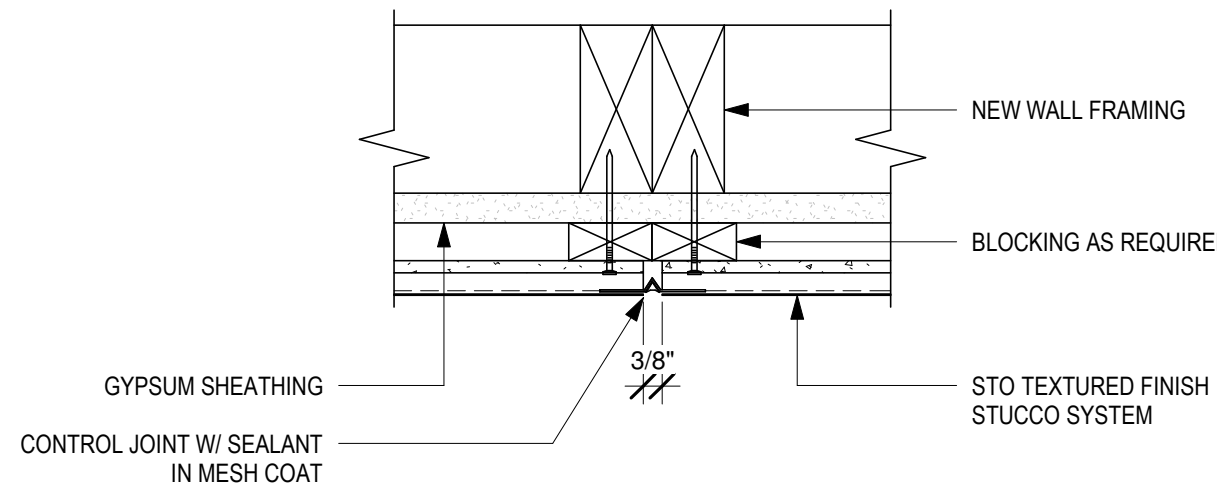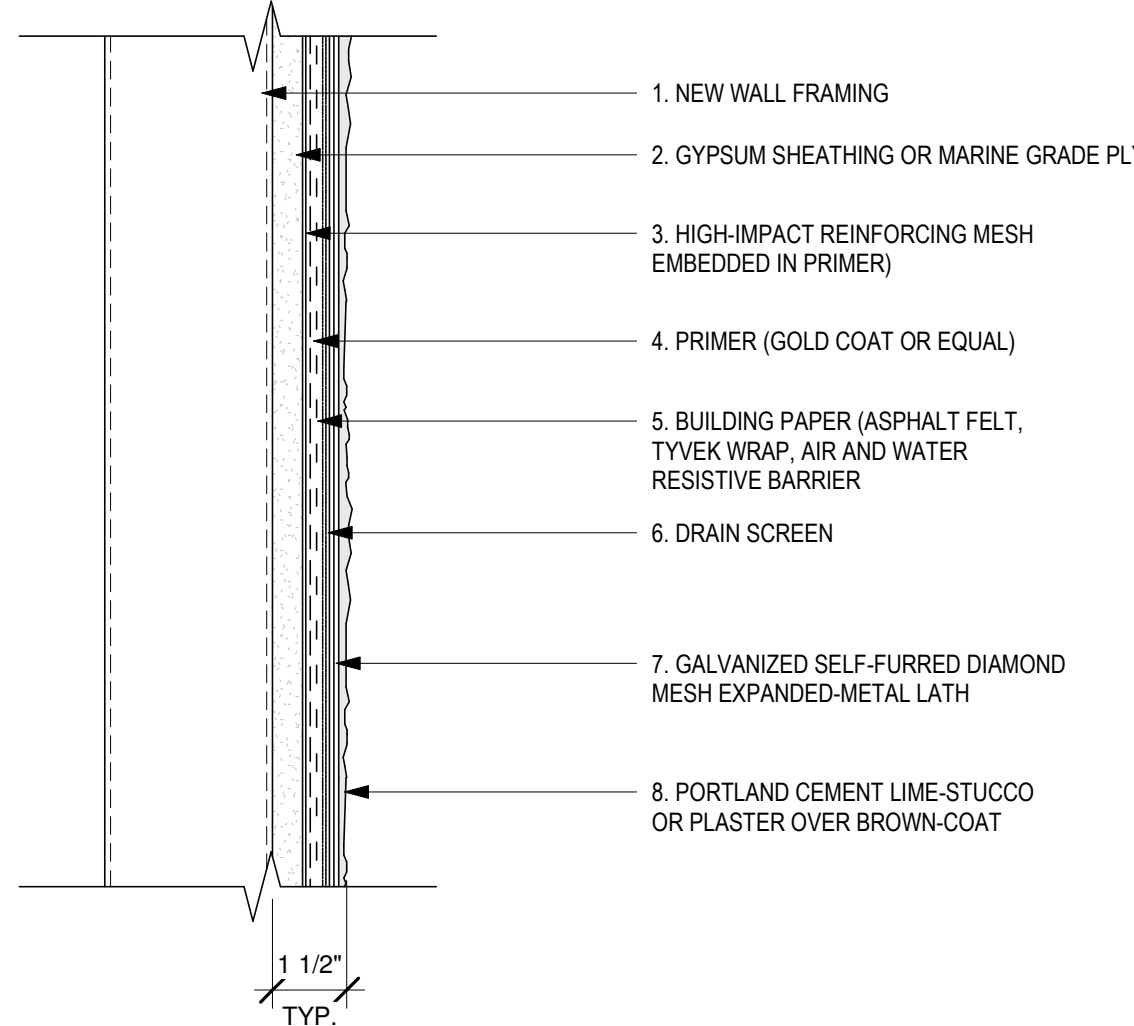					
7	DETAIL AT STOREFRONT GLASS HEADER SCALE: 6" = 1'-0"	5	DETAIL AT STOREFRONT DOOR HEADER SCALE: 6" = 1'-0"	3	DETAIL AT STOREFRONT SIGNAGE SCALE: 3" = 1'-0"
					
6	DETAIL AT STOREFRONT GLASS SILL SCALE: 6" = 1'-0"	4	DETAIL AT STOREFRONT DOOR SILL SCALE: 6" = 1'-0"	2	TYPICAL CONTROL JOINT DETAIL SCALE: 3" = 1'-0"
				<div>STO POWERWALL G/MG DRAIN SCREEN OR APPROVED EQUAL FOR HURRICANE IMPACT RESISTANCE AS REQUIRED BY THE FOA</div> 	
				1	TYPICAL STOREFRONT STUCCO DETAIL SCALE: 3" = 1'-0"

TWO ONE TWO

45 WEST 21st STREET, SUITE 403
NEW YORK, NY 10010

IN ASSOCIATION WITH THE ARCHITECT:

R H SWEERS II, PROPRIETOR

R H SWEERS ARCHITECT

ALL DRAWINGS AND WRITTEN MATERIAL APPEARING HEREIN CONSTITUTE ORIGINAL AND UNPUBLISHED WORK OF THE ARCHITECT AND MAY NOT BE DUPLICATED, USED OR DISCLOSED WITHOUT WRITTEN CONSENT OF THE ARCHITECT. THIS DOCUMENT IS INTENDED SOLELY FOR THE CONSTRUCTION OF THE PROJECT NAMED HEREIN AND SHALL NOT BE USED BY ANY OTHER CONSTRUCTION WITHOUT WRITTEN CONSENT OF THE ARCHITECT.

THIS DRAWING WAS PREPARED UNDER MY SUPERVISION AND I DISCLAIM ANY RESPONSIBILITY FOR THE EXISTING BUILDING CONSTRUCTION ELEMENTS, SITE CONDITIONS, OR ANY DOCUMENTS WHICH DO NOT BEAR MY SEAL.

SEAL

DRAWINGS ISSUED

No.	Rev	Date	Description
1		06.18.26	LL REVIEW SET
2		06.24.26	ISSUE FOR PERMIT
3		07.02.26	ISSUE FOR BID

PROJECT NAME:

TWP NAPLES

TWP

PROJECT ADDRESS:

WATERSIDE SHOPS

5455 TAMIAMI TRL N

NAPLES, FL 34108

DRAWING TITLE:


STOREFRONT DETAILS

SCALE: AS SHOWN

Project No.	26TWP05
Scale:	As indicated
Date:	08-20-2026
Drawn By:	212
Checked By:	212


DRAWING NO:

 A-702


$$1/4'' = 1' - 0''$$

BIDDING CONTRACTORS SHALL HAVE A WORKING KNOWLEDGE OF LOCAL CODES AND ORDINANCES AND SHALL INCLUDE IN THEIR BIDS THE COSTS FOR ALL WORK INSTALLED IN STRICT ACCORDANCE WITH GOVERNING CODES, THE PLANS AND SPECIFICATIONS NOT WITHSTANDING. THE CONTRACTOR SHALL ALERT ARCHITECT, ENGINEER OR OWNER OF ANY APPARENT DISCREPANCIES BETWEEN GOVERNING CODES AND DESIGN INTENT.

E-100

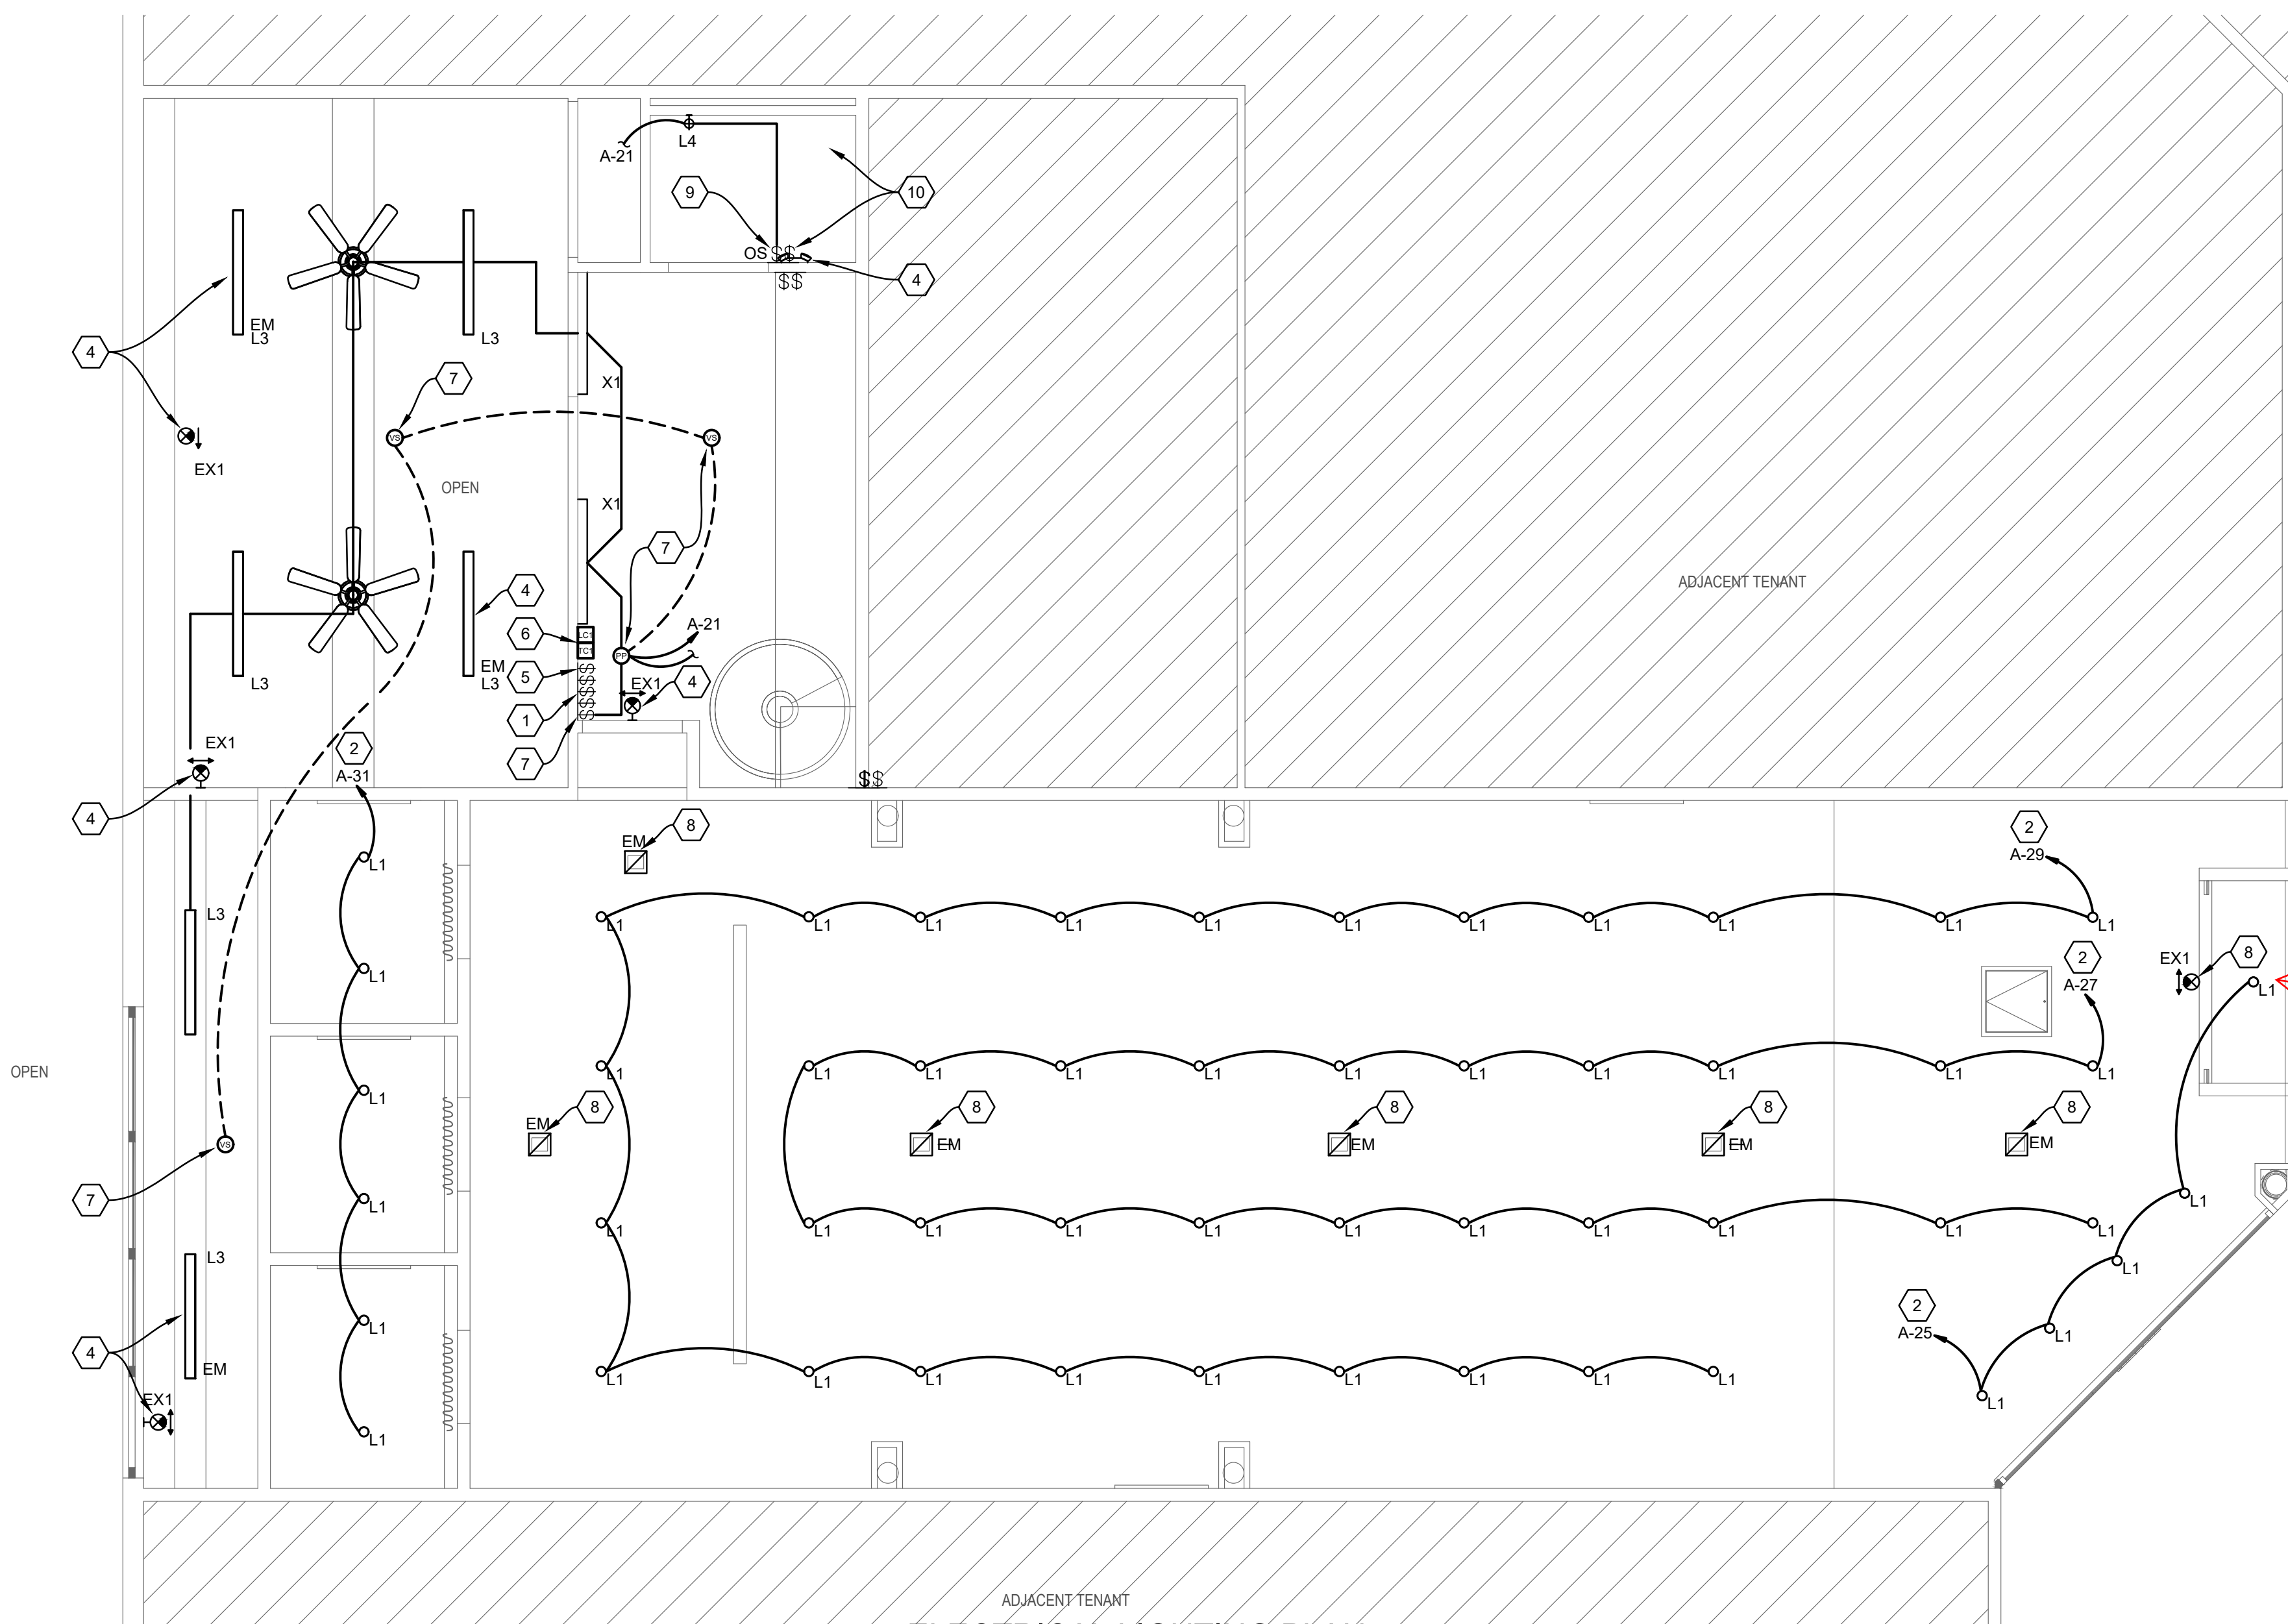

ELECTRICAL LIGHTING PLAN


1/4"=1'-0"

MASTER LIGHTING SWITCH BANK NOTES:

- REFER TO "LIGHTING CONTROL SCHEMATIC" ON SHEET E-300 FOR ADDITIONAL INFORMATION.
- LABEL SWITCHES AS SHOWN BELOW.
- DIMMER SWITCH: LUTRON MAESTRO PRO LED PLUS DIMMER 250 W LED. WHITE.

NON-SALES AREA LIGHTING MANUAL ON SPST	SALES AREA	SALES AREA	SALES AREA	FITTING ROOM AREA	SALES AREA
7	SPST	DIM	DIM		5
MOMENTARY CONTACT SWITCH	STRFRNT LTG	DOWN LTG	DOWN LTG	FITT RM DOWN LTG	2 HOUR OVERRIDE/ MANUAL ON
	"a"	"b"	"c"	"d"	

MASTER LIGHTING SWITCH BANK
NTS

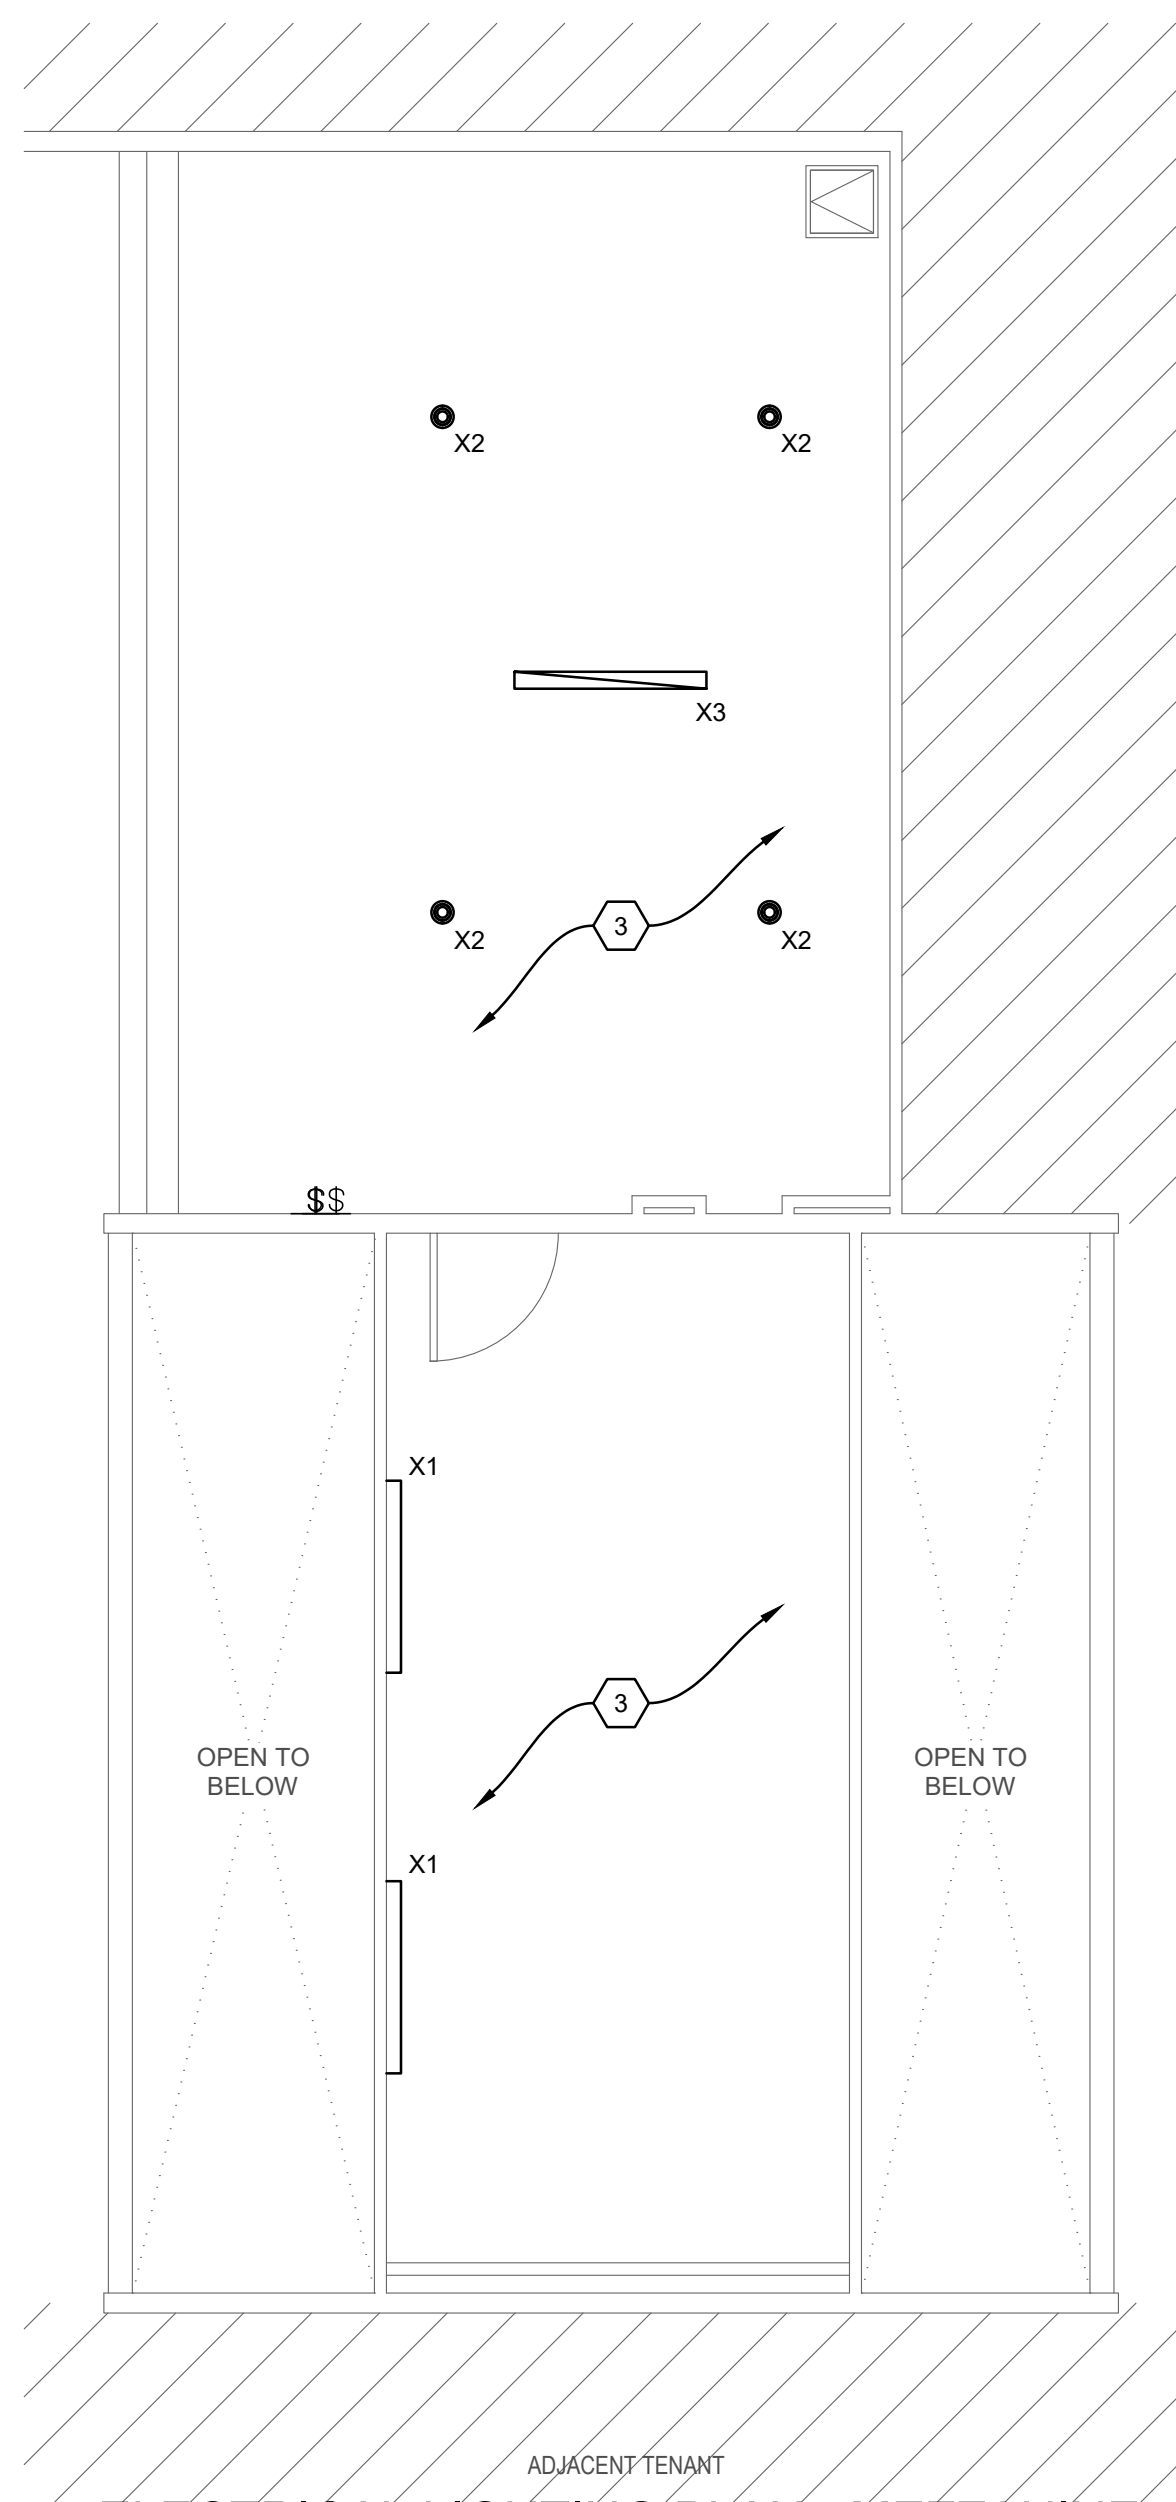

ELECTRICAL LIGHTING PLAN - MEZZANINE

1/4"=1'-0"

LIGHTING GENERAL NOTES:

- LIGHTING SHALL BE CIRCUITED EXACTLY AS SHOWN ON PLANS.
- SEE ARCHITECTURAL REFLECTED CEILING PLAN FOR EXACT LOCATION AND QUANTITY OF LIGHTING FIXTURES.
- EMERGENCY AND EXIT LIGHTS SHALL BE INSTALLED AND CIRCUITED PER THE LATEST NATIONAL ELECTRICAL CODE AND ALL LOCAL CODES. ALL EMERGENCY AND EXIT FIXTURES SHALL BE DUAL VOLTAGE (120/277 VOLT INPUT) WITH BATTERY BACKUP.
- CONTRACTOR IS RESPONSIBLE FOR ALL REFLECTED CEILING PLAN NOTES ON ARCHITECTURAL DRAWINGS.

SEE SHEET E-300 FOR POWER SYMBOL LEGEND

SEE SHEET E-300 FOR LIGHT FIXTURE SCHEDULES

FIELD VERIFY ALL CONDITIONS

DESIGN DRAWINGS ARE SCHEMATIC. THIS CONTRACTOR SHALL VISIT THE SITE PRIOR TO BIDDING OR AWARD OF CONTRACT TO INSPECT EXISTING FIELD CONDITIONS. THIS CONTRACT SHALL INCLUDE ALL LABOR AND MATERIALS NECESSARY FOR FIELD MODIFICATIONS DUE TO EXISTING CONDITIONS.

THE CONTRACTOR SHALL CONTACT THE ARCHITECT, ENGINEER OR OWNER PRIOR TO BIDDING FOR INTERPRETATIONS AND CLARIFICATIONS OF THE DESIGN AND INCLUDE IN HIS BID ALL COSTS TO MEET THE DESIGN INTENT. CLARIFICATIONS MADE BY THE ARCHITECT, ENGINEER OR OWNER AFTER BIDDING WILL BE FINAL AND SHALL BE IMPLEMENTED AT CONTRACTORS COST.

BIDDING CONTRACTORS SHALL HAVE A WORKING KNOWLEDGE OF LOCAL CODES AND ORDINANCES AND SHALL INCLUDE IN THEIR BIDS THE COSTS FOR ALL WORK INSTALLED IN STRICT ACCORDANCE WITH GOVERNING CODES, THE PLANS AND SPECIFICATIONS NOT WITHSTANDING. THE CONTRACTOR SHALL ALERT ARCHITECT, ENGINEER OR OWNER OF ANY APPARENT DISCREPANCIES BETWEEN GOVERNING CODES AND DESIGN INTENT.



Mark P. Huffrage, LLC
750 Brookside Blvd.
Westerville, Ohio 43081
phone: 614.839.4639
fax: 614.839.2222

Authorization #29103

THIS ITEM HAS BEEN DIGITALLY SIGNED AND SEALED BY MARK P. HUFFRAGE ON THIS DATE ADJACENT TO THE SEAL. PRINTED COPIES OF THIS DOCUMENT ARE NOT CONSIDERED SIGNED AND SEALED AND THE SIGNATURE MUST BE VERIFIED ON ANY ELECTRONIC COPIES.

SEAL

DRAWINGS ISSUED

No.	Rev	Date	Description
1		06.18.26	LL REVIEW SET
2		06.25.26	ISSUE FOR PERMIT

PROJECT NAME:

TWP NAPLES



PROJECT ADDRESS:

WATERSIDE SHOPS
5455 TAMiami TRL N
NAPLES, FL 34108

DRAWING TITLE:


**ELECTRICAL
LIGHTING
PLAN**

Project No.	2642110
Scale:	AS NOTED
Date:	05-15-2026
Drawn By:	BB
Checked By:	CF
DRAWING NO:	

E-200

POWER AND SIGNAL SYMBOL LEGEND					
SYMBOL	DESCRIPTION	SYMBOL	DESCRIPTION	SYMBOL	DESCRIPTION
	RECESSED CEILING SPEAKER. "X" INDICATES SPEAKER ZONE. SPEC: STEALTH ACOUSTICS INVISIBLE SPEAKERS & SUBWOOFERS, EACH WIRED BACK TO A/V RACK. SEE VENDOR'S A/V PLAN FOR VOLUME CONTROL SWITCH LOCATIONS.		NEW WALL JUNCTION BOX LOCATED BEHIND WALL ACCESS PANEL OR SURFACE MOUNTED.		SECURITY KEYPAD
	MUSIC SPEAKER VOLUME CONTROL. WALL SWITCH KNOB AT 48" AFF. "X" INDICATES SPEAKER ZONE. (1) CAT6 CABLE RUN FROM EACH CONTROL TO A/V RACK.		(1) 22/4 SHIELD AUDIO CABLE RUN FROM WALL MOUNTED ipad @ 48" AFF TO A/V RACK. PROVIDE SINGLE GANG BRUSH WALL PLATE FOR CABLE PASS-THRU.		ELECTRIC DOOR STRIKE (BY GC) & CARD READER (DEVICE PROVIDED BY SECURITY VENDOR)
	WALL LIGHTING CONTROL SWITCH. ROOM NAMES SHOWN TO INDICATE SWITCH CONTROL. (D) INDICATES DIMMER		DATA CONNECTION IN A 1, 2 OR 4 PORT WALL PLATE. THE FIRST # IN SEQUENCE (#1) IS THE QUANTITY OF FEMALE RJ45 PORTS AT WALL PLATE. THE SECOND # IN SEQUENCE (#2) IS THE QUANTITY OF CAT6 CABLE(S) RUN TO IT RACK. TERMINATED INTO PATCH A PANEL PORT. EACH CABLE TO HAVE A RJ45 MALE CONNECTOR ON EACH END.		WIRELESS SECURITY GLASS BREAK AUDIO SENSOR
	WALL LIGHTING CONTROL SWITCH BANK. QUANTITY OF SWITCHES BASED ON ZONES. REFER TO ELECTRICAL DWGS.		CEILING DATA CONNECTION AP = W/F ACCESS POINT DEVICE ST = SHOPPER TRACK DEVICE RUN 2 CABLES (ONE ACTIVE, ONE SPARE) TO IT RACK. EACH TERMINATED INTO A PORT AT PATCH PANEL. EACH CABLE TO HAVE A RJ45 MALE CONNECTOR ON EACH END. LEAVE (1) 24" COILED CABLE POKED-THRU CEILING AT DEVICE LOCATION FOR FINAL VENDOR CONNECTION. SPARE CABLE CAN REMAIN COILED ABOVE CEILING.		SECURITY DOOR CONTACT
	WALL DUPLEX OUTLET, WHITE FINISH. ALL OUTLETS IN CUSTOMER FACING AREAS TO RECEIVE LEVITON DECORA WHITE SCREWLESS SNAP-ON FACEPLATE.		FIRE ALARM MANUAL PULL STATION - WALL MOUNTED		WALL MOUNTED SECURITY MOTION DETECTOR
	FLUSH TAPE-IN CEILING DUPLEX OUTLET, WHITE FINISH.		FIRE ALARM HORN AND/OR STROBE - WALL MOUNTED / CEILING MOUNTED		CEILING MOUNTED SECURITY MOTION DETECTOR
	WALL QUAD OUTLET. WHITE FINISH.		FIRE ALARM ANNUNCIATOR PANEL		SECURITY PANIC BUTTON
	FLOOR DEDICATED DUPLEX OUTLET [2 - 20 AMP DEDICATED CIRCUITS FOR FUTURE SHOW WINDOW DISPLAYS] WITH FLUSH TO FLOOR COVER PLATE. BRUSHED NICKEL FINISH.		REAR DOOR BUZZER AND ASSOCIATED INTERIOR WALL MOUNTED CHIME. (1) DOOR BUZZER AT REAR DOOR, (1) CHIME LOCATED AT BOH. SPEC: EDWARDS CHIME #338 SERIES; BUZZER #1786C-B; TRANSFORMER #592		EXISTING PHONE INTERCOM WITH DOOR RELEASE BUTTON
	FULLY RECESSED DUPLEX OUTLET, 4" ROUND POKE-THRU FLOOR BOX, WITH FLUSH TO FLOOR COVER PLATE. BRUSHED NICKEL FINISH.		THERMOSTAT CONTROL @ 48" AFF		POWER PACK FOR CEILING MOUNTED VACANCY SENSOR
	NEW JUNCTION BOX LOCATED ABOVE FINISHED CEILING NEAR CEILING ACCESS PANEL OR ABOVE ACT.		WALL MOUNTED SECURITY CAMERA		VACANCY SENSOR IN CONJUNCTION WITH POWER PACK
	CEILING MOUNTED SECURITY DOME CAMERA SYSTEM				

LIGHTING SCHEDULE								
TAG	QTY	LOCATION	COMMENTS	SPEC	WATTS	MANUF.	PROVIDED BY	INSTALLED BY
EM	7	EMERGENCY CONCEALED LIGHTS THROUGHOUT SPACE	EMERGENCY LIGHTS THROUGHOUT	APAL-WH-UI	9 W	Evenlite	OWNER	GC
EX1	1	SALES, BOH VESTIBULE, BOH	EDGE-LIT SINGLE FACE EXIT SIGN - GREEN LETTERS ON CLEAR PANEL	PINN-G-AC90MINBU-CR/WR-1 -C-BAL	3 W	Pinnacle	OWNER	GC
L1	53	SALES DOWNLIGHTS	TRIMLESS RECESSED DOWNLIGHTS THROUGHOUT SALES AREA. LIGHTS TO BE ADJUSTABLE.	H3R-2035ZW00LE NNC TRIM H3T-LR-A/WWHTL	21W	LiteLine	OWNER	GC
L3	6	BOH LINEAR PENDANTS	NEW LINEAR PENDANTS FOR BOH	12100-22-P-FLT-24-WH-SHD-B -RCP-OS	10W/FT	Alcon Lighting	OWNER	GC
L4	1	BATHROOM WALL SCONCE	WALL SCONCE IN BATHROOM TO BE REPLACED IN SAME LOCATION	FMVCCLS 24IN MVOLT 30K 90CRI BN	18W	Lithonia	OWNER	GC
EXISTING LIGHTING SCHEDULE								
TAG	QTY	LOCATION	COMMENTS	SPEC	WATTS	MANUF.		
X1	4	WALL MOUNTED FLUORESCENT LIGHT	EXISTING BOH AND MECHANICAL ROOM WALL MOUNTED LIGHT	LAMP UP 4/39 LAMP DOWN 1/382D TRIM STYLE-A/120V	54 W	LIGHTOLIER		
X2	4	RECESSED DOWNLIGHT	EXISTING RECESSED DOWNLIGHT LOCATED AT MEZZANINE	REFLECTOR 8031CLW/TRIPL. LUBE LAMP. 26W	26 W	LIGHTOLIER		
X3	1	CEILING FLUORESCENT LIGHT	EXISTING BOH MEZZANINE LIGHT AT CEILING	SILVANIA #FP54/835/HO	54 W	LIGHTOLIER		

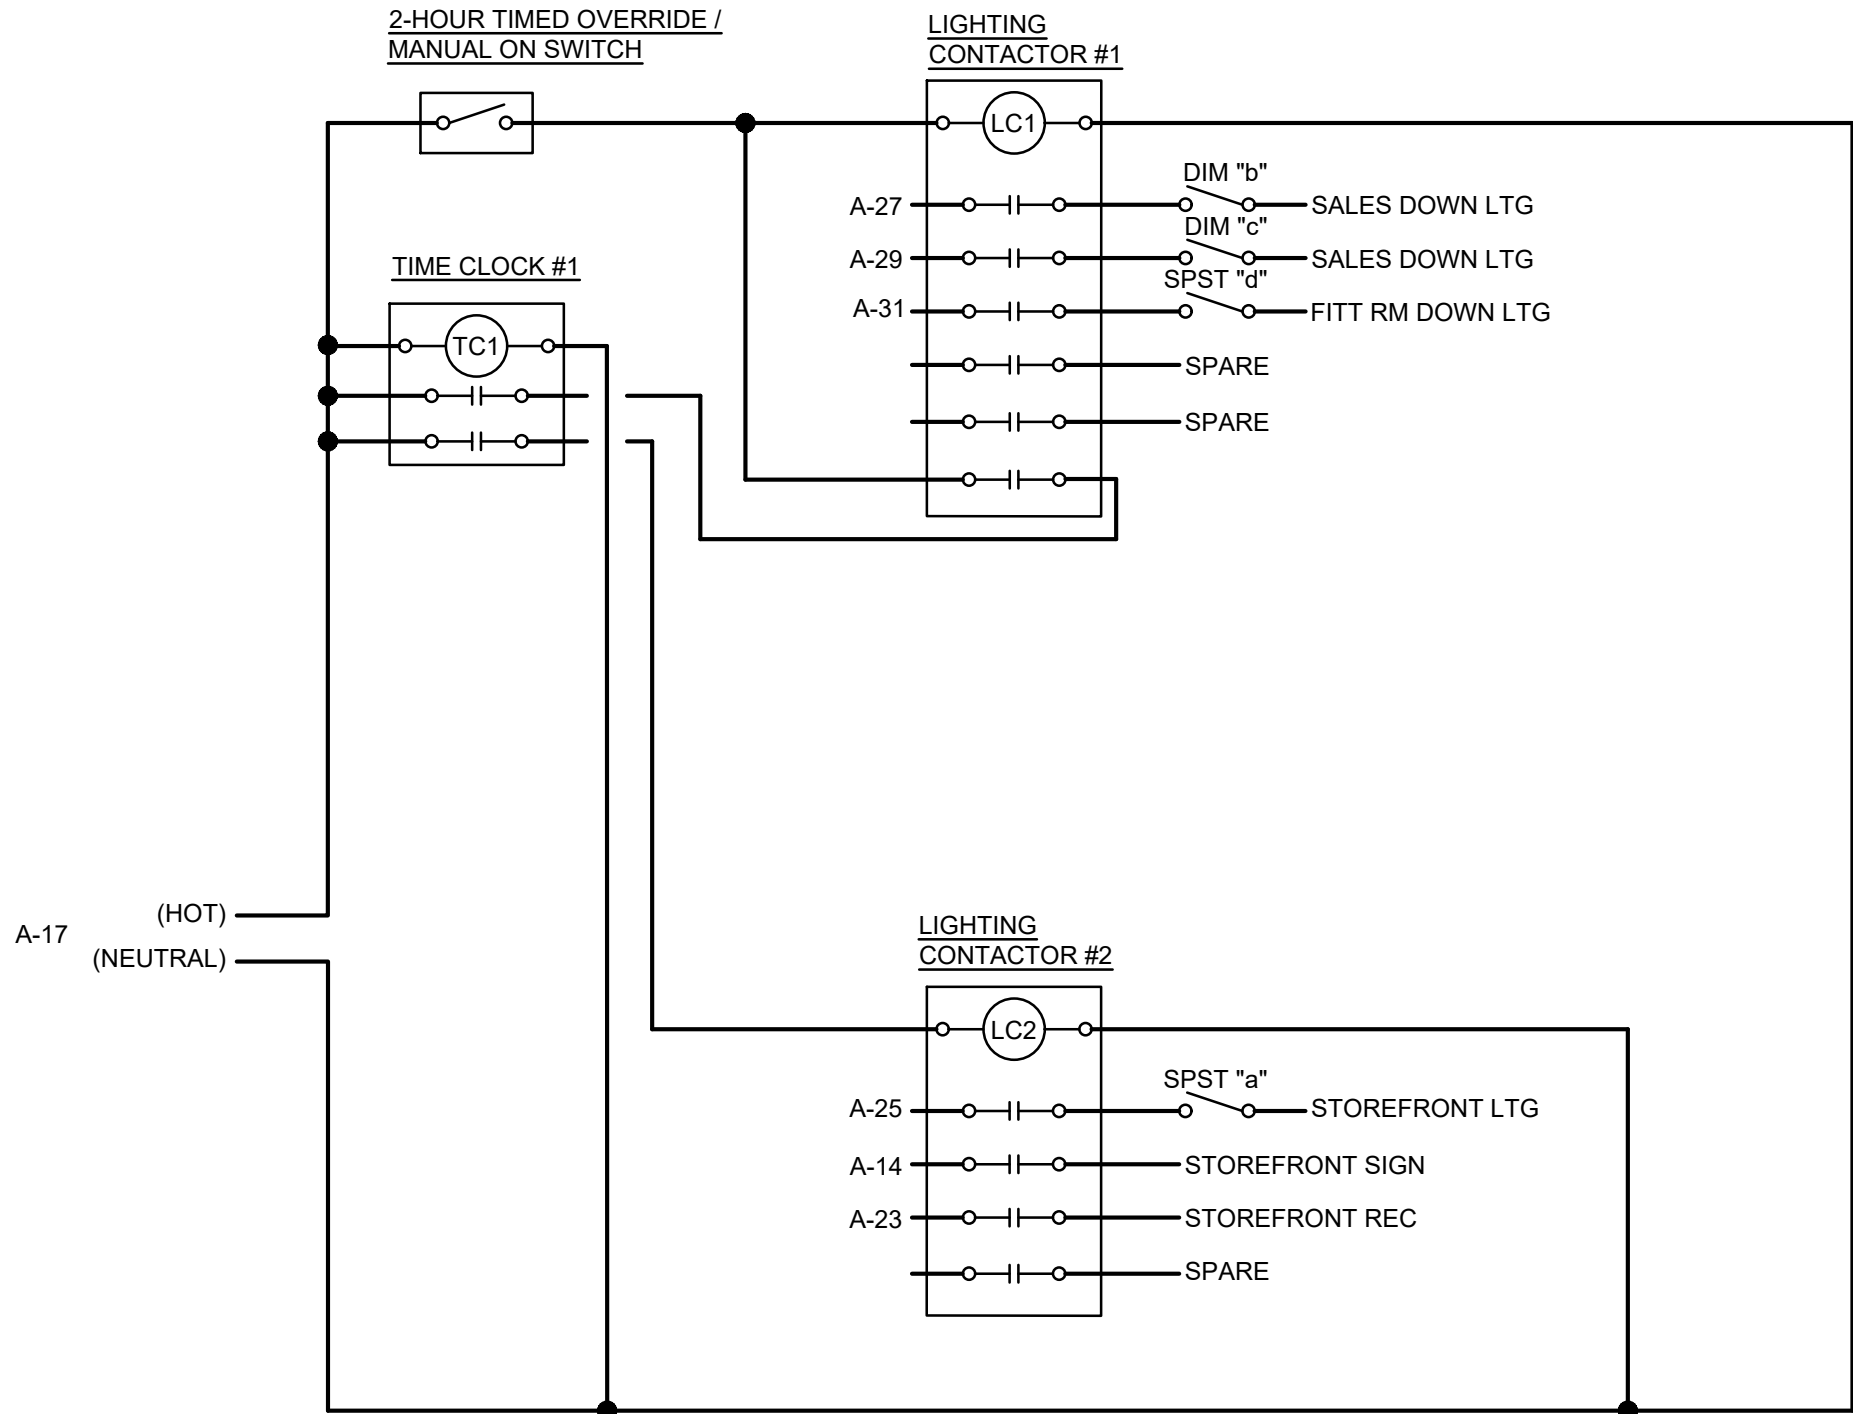

LIGHTING CONTROL SCHEMATIC

CONTROL SCHEMATIC NOTES:

- TIME CLOCK**
PROVIDE TORK DIGITAL DZS SERIES 24 HOUR/7 DAY TIME CLOCK WITH POLE QUANTITY AS INDICATED. SET TO TURN ON 1 HOUR BEFORE MALL OPENS AND TURN OFF 1 HOUR AFTER MALL CLOSSES.
- OVERRIDE**
PROVIDE TORK MODEL SSA200 DIGITAL TIME SWITCH. REFER TO LIGHTING PLAN FOR SWITCH LOCATION.
- CONTACTOR**
PROVIDE SQUARE D MODEL 8903 ELECTRICALLY HELD CONTACTOR WITH POLE QUANTITY AS INDICATED.



THIS ITEM HAS BEEN DIGITALLY SIGNED AND SEALED BY MARK P. HUFFNAGLE ON THIS DATE ADJACENT TO THE SEAL. PRINTED COPIES OF THIS DOCUMENT ARE NOT CONSIDERED SIGNED AND SEALED AND THE SIGNATURE MUST BE VERIFIED ON ANY ELECTRONIC COPIES.

SEAL

DRAWINGS ISSUED

No.	Rev	Date	Description
1		06.18.26	LL REVIEW SET
2		06.25.26	ISSUE FOR PERMIT

PROJECT NAME:

TWP NAPLES



PROJECT ADDRESS:

WATERSIDE SHOPS
5455 TAMIAAMI TRL N
NAPLES, FL 34108

DRAWING TITLE:

ELECTRICAL
SCHEDULES AND
SCHEMATICS

Project No.	2642110
Scale:	AS NOTED
Date:	05-15-2026
Drawn By:	BB
Checked BY:	CF

DRAWING NO:

E-300

ELECTRICAL EQUIPMENT CONNECTION SCHEDULE									
UNIT	VOLTAGE	FLA	MCA	MOCP	CONDUCTORS	CONDUIT SIZE	DISCONNECTING MEANS AT UNIT	CIRCUIT	CONNECTION NOTES
EX ACCU -1	480V, 3 PHASE	36.10 A	48.00 A	80/3	EXISTING	EXISTING	EXISTING	A-37/39/41	1
EX AHU -2	480V, 3 PHASE	6.20 A	7.80 A	15/3	EXISTING	EXISTING	EXISTING	A-38/40/42	1

NOTE:
VERIFY EXACT OVERCURRENT PROTECTION / DISCONNECT REQUIREMENTS (PER LATEST N.E.C. CHAPTER 4, ARTICLES 422 THROUGH 440) WITH EQUIPMENT MANUFACTURER'S NAMEPLATE DATA UPON RECEIPT AT JOB SITE. CONTACT ENGINEER WITH ANY DISCREPANCIES. ELECTRICAL CONTRACTOR TO MAKE ALL FINAL ELECTRICAL POWER CONNECTIONS.

CONNECTION NOTES:
1. UNIT AND ALL ITS COMPONENTS (WIRE, CONDUIT, DISCONNECT, CIRCUIT BREAKER, ETC.) IS EXISTING TO REMAIN.

ELECTRIC LOAD SUMMARY				
208Y/120V SERVICE				
DESCRIPTION	N.E.C. CONNECTED KVA	NEC DEMAND NOTES	N.E.C. DEMAND FACTOR	N.E.C. DEMAND KVA
LIGHTING (CONTINUOUS)	3.095	[1]	1.25	3.869
TRACK LIGHT DEMAND ALLOWANCE	-	[2]	-	0.000
SHOW WINDOW DEMAND ALLOWANCE	-	[3]	-	2.400
KIT APPLIANCE	0.000	[4]	1.00	0.000
RECEPTACLES	7.200	[5]	-	7.200
MOTORS	0.000	[6]	-	0.000
HVAC SYSTEM	15.240	[6]	-	18.176
HVAC SYSTEM - NON COINCIDENT	0.000	[7]	0.00	0.000
ELECTRIC WATER HEATER	1.500	-	1.25	1.875
EV CHARGING	0.000	-	1.25	0.000
MISCELLANEOUS	2.100	-	1.00	2.100
	29.135			35.620
N.E.C. DEM. KVA X 1000 = MINIMUM FEEDER AMPERAGE				
SYS. VOLTAGE X 1.732				
35.620 X 1000 = 98.9 AMPS				
208 X 1.732				

LOAD SUMMARY NOTES:
[1] POWER FACTOR IS ALREADY INCLUDED IN LIGHTING LOAD.
[2] 150VA/2FT OF LINE VOLTAGE TRACK + SUM LOW VOLTAGE XFRMS - CONNECTED LOAD
[3] 200VA/1F - ACTUAL CONNECTED LOAD
[4] KIT APPLIANCE DEMAND FACTOR PER NEC 220-56
[5] 0.0 < 10KW = 100%, REMAINING = 50%
[6] 125% OF THE LARGEST MOTOR OR COMPRESSOR IN SYSTEM APPLIED ON ONE UNIT.
[7] EQUIPMENT WILL NOT BE OPERATING WHILE SYSTEM IS AT MAXIMUM DEMAND.

Panel Wiring Schedule (3-Phase)

Panelboard		Voltage		Phase		Options/Notes: EXISTING PANEL						
Panel Type	"A"	OC/PD	208Y/120	Wire	3							
NEMA Type	EXISTING	Mounting	M.L.O.	Bus	4							
	1		SURFACE		225A	A/C Rating	EXISTING					
Ckt. No.	Zone	Load Description	Brkr. Size *	Brkr. Opts.	N.E.C. kVA	Phase	N.E.C. kVA	Brkr. Opts.	Brkr. Size *	Load Description	Zone	Ckt. No.
1	EX	EX MEZZ / MECH RM LTG			0.266	A	0.360			DESK REC		2
3		SPARE			0.000	B	0.360	LO		CASHWRAP REC		4
5		GENERAL CONV REC			0.720	C	0.360	LO		CASHWRAP REC		6
7		GENERAL CONV REC			0.900	A	0.000			SPARE		8
9		GENERAL CONV REC			1.080	B	0.000			SPARE		10
11		GENERAL CONV REC			1.080	C	0.000			SPARE		12
13		GENERAL CONV REC			0.720	A	1.200			STOREFRONT SIGN	LC2	14
15		GENERAL CONV REC			0.720	B	0.000			SPARE		16
17		LTG CONTROL			0.100	C	0.000			SPARE		18
19		SPARE			0.000	A	1.000	LO		SECURITY CABINET		20
21		BOH LTG	LO		0.516	B	1.000	LO		IT CABINET		22
23	LC2	STOREFRONT REC			0.180	C	0.360	LO		MANAGERS DESK REC		24
25	LC2	SHOW WINDOW LTG			0.105	A	0.360	LO		MANAGERS DESK REC		26
27	LC1	SALES DOWN LTG			0.420	B	0.000			SPARE		28
29	LC1	SALES DOWN LTG	LO		0.462	C	1.500			EX WATER HEATER	EX	30
31	LC1	FITT RM DOWN LTG			0.126	A	0.000			SPARE		32
33		SPARE			0.000	B	0.000			SPARE		34
35		SPARE			0.000	C	0.000			SPARE		36
37					4.335	A	0.745					38
39	EX	EX ACCU-1	80/3	HACR	4.335	B	0.745	HACR	15/3	EX AHU-1	EX	40
41					4.335	C	0.745					42

Notes
* All circuit breakers to be 20-Amp, 1-Pole unless otherwise noted.
** All Phases to be balanced to within 10% using Actual Load Totals.

Breaker Options:
RCS Remote Controlled Solenoid
LO Handle lock-on device
ST Shunt Trip Type
AUX Auxiliary Contacts
PA Handle Padlock Attachment
GFCI Ground Fault Circuit Interrupter
HACR Heating, A/C & Refrigeration
SF Subfeed
AFCI Arc Fault Circuit Interrupter
HT Handle Tie

Connected Load: 80.9 amps
NEC Demand Feeder Load: 98.9 amps

THE DESIGN OF THIS PORTION OF THIS STORE IS BASED ON THE ASSUMPTION THAT THE ORIGINAL STORE DRAWINGS/SCHEDULES REFLECT ACCURATE "AS-BUILT" CONDITIONS. TENANT'S E.C. SHALL CONFIRM/VERIFY ALL EXISTING CONDITIONS IN THE FIELD AND NOTIFY THE CONSTRUCTION MGR OF ANY DISCREPANCIES BETWEEN THESE PLANS AND ACTUAL FIELD CONDITIONS PRIOR TO BIDS. TENANT E.C. TO CHECK CURRENT CIRCUIT CAPACITY TO ACCEPT INCREASED LOAD PRIOR TO ADDING TO CIRCUIT. EXACT LOCATION OF EXISTING CIRCUITS IN PANELS SHALL BE FIELD VERIFIED.

TENANT'S ELECTRICAL CONTRACTOR TO REUSE EXISTING ELECTRICAL EQUIPMENT. VERIFY THAT IT IS IN GOOD OPERATING CONDITION, MEETS ALL CODES, AND MATCHES THE CAPACITIES AND CHARACTERISTICS OF THE EQUIPMENT INDICATED ON THESE DRAWINGS AND SPECIFICATIONS. REUSED EQUIPMENT MUST HAVE THE TERMINALS CLEANED AND ALL FUSES AND CIRCUIT BREAKERS MUST BE REPLACED WITH NEW. THIS CONTRACTOR SHALL WARRANTEE ALL EXISTING EQUIPMENT REUSED FOR THE DURATION OF THIS CONTRACT WARRANTEE. IF EXISTING ELECTRICAL EQUIPMENT IS NOT ABLE TO BE REUSED CONTACT ARCHITECT/ENGINEER.

GENERAL REMODELING NOTES

- ALL DRAWINGS ARE CONCEPTUAL AND SCHEMATIC AND ARE INTENDED FOR USE AS A DESIGN/BUILD GUIDELINE. THE CONTRACTORS ARE RESPONSIBLE FOR VERIFYING ALL FIELD CONDITIONS AND ADJUSTING OR MODIFYING THE SPECIFIC ELEMENTS OF THEIR WORK AS REQUIRED TO MEET THE DESIGN INTENT. THE CONTRACTORS ARE RESPONSIBLE FOR THE FOLLOWING:
 - COORDINATION WITH OTHER TRADES.
 - PROVIDING ADDITIONAL DRAWINGS, CALCULATIONS AND OTHER DOCUMENTATION REQUIRED FOR THE BUILDING DEPARTMENT. THE ELECTRICAL CONTRACTOR SHALL DOCUMENT ALL CIRCUITING AND PROVIDE ALL TESTS REQUIRED TO SUBSTANTIATE CODE COMPLIANCE AS REQUIRED BY THE BUILDING DEPARTMENT AND LOCAL INSPECTOR. SUBMIT FINAL AS-BUILT DRAWINGS TO BUILDING DEPARTMENT FOR RECORD AT COMPLETION.
- THE ELECTRICAL CONTRACTOR SHALL DOCUMENT ALL NEW AND EXISTING LOADS ON PANELS AND MAIN SERVICE TO DETERMINE LOADS ARE WITHIN LIMITS OF EXISTING OVER CURRENT DEVICES AND WIRING WITH A 25% SAFETY FACTOR INCLUDED. (BASED ON POWER COMPANY RECORDED HIGH DEMAND KW). ALL PANELS SHALL BE BALANCED WITHIN 10% HIGH LEG TO LOW LEG.
- REMOVE EXISTING LIGHTING AND INSTALL NEW LIGHTING AS SHOWN AND SCHEDULED ON PLANS. REUSE EXISTING CIRCUITS WHENEVER POSSIBLE. DOCUMENT ALL CIRCUITING FOR BUILDING DEPARTMENT REVIEW AND APPROVAL.
- CONTRACTOR SHALL RECORD, ON A SET OF "AS-BUILTS" DRAWINGS, ALL CHANGES OR MODIFICATIONS MADE IN THE FIELD, TO AN ORIGINAL SET OF CONSTRUCTION DOCUMENTS, FOR TURN-OVER TO THE ARCHITECT / ENGINEER UPON COMPLETION OF THE PROJECT.
- ALL WORK SHALL BE IN STRICT ACCORDANCE WITH STATE AND LOCAL CODES AND ORDINANCES AND THE NATIONAL ELECTRIC CODE.

FIELD VERIFY ALL CONDITIONS

DESIGN DRAWINGS ARE SCHEMATIC. THIS CONTRACTOR SHALL VISIT THE SITE PRIOR TO BIDDING OR AWARD OF CONTRACT TO INSPECT EXISTING FIELD CONDITIONS. THIS CONTRACT SHALL INCLUDE ALL LABOR AND MATERIALS NECESSARY FOR FIELD MODIFICATIONS DUE TO EXISTING CONDITIONS.

THE CONTRACTOR SHALL CONTACT THE ARCHITECT, ENGINEER OR OWNER PRIOR TO BIDDING FOR INTERPRETATIONS AND CLARIFICATIONS OF THE DESIGN AND INCLUDE IN HIS BID ALL COSTS TO MEET THE DESIGN INTENT. CLARIFICATIONS MADE BY THE ARCHITECT, ENGINEER OR OWNER AFTER BIDDING WILL BE FINAL AND SHALL BE IMPLEMENTED AT CONTRACTORS COST.


BIDDING CONTRACTORS SHALL HAVE A WORKING KNOWLEDGE OF LOCAL CODES AND ORDINANCES AND SHALL INCLUDE IN THEIR BIDS THE COSTS FOR ALL WORK INSTALLED IN STRICT ACCORDANCE WITH GOVERNING CODES, THE PLANS AND SPECIFICATIONS NOT WITHSTANDING. THE CONTRACTOR SHALL ALERT ARCHITECT, ENGINEER OR OWNER OF ANY APPARENT DISCREPANCIES BETWEEN GOVERNING CODES AND DESIGN INTENT.

ELECTRICAL RESPONSIBILITY SCHEDULE

	EXISTING	FURNISHED BY				INSTALLED BY				REMARKS
		LANDLORD	OWNER	TENANT CONTRACTOR	OTHERS	LANDLORD	OWNER	TENANT CONTRACTOR	OTHERS	
MAIN OVERCURRENT DEVICE IN LANDLORD'S ELECTRIC ROOM	●									VERIFY IN FIELD
ELECTRIC SERVICE CONDUIT TO LEASE SPACE	●									VERIFY IN FIELD
ELECTRIC SERVICE FEEDERS TO LEASE SPACE	●									VERIFY IN FIELD
METER REQUIREMENTS	●									VERIFY IN FIELD
LIGHT FIXTURES AND LAMPS		●						●		
OUTLETS AND SWITCHES			●					●		
GENERAL CONDUIT & WIRING			●					●		
TELEPHONE SERVICE CONDUIT W/ PULL WIRE	●		●					●		VERIFY IN FIELD
TELEPHONE CONDUIT W/ PULL WIRE			●					●		
TELEPHONE CABLING		●					●			
TELEPHONE EQUIPMENT		●					●			
DATA CONDUIT			●					●		
DATA CABLING			●					●		
TEMPORARY UTILITY CHARGES			●					●		
TENANT ELECTRICAL PANELS	●									VERIFY IN FIELD
TRANSFORMER										N/A

POWER RISER DIAGRAM GENERAL NOTES

- HVAC CIRCUIT BREAKERS SHALL BE "HACR" TYPE WHERE REQUIRED BY EQUIPMENT NAMEPLATE PER N.E.C.
- TENANT'S ELECTRICAL CONTRACTOR SHALL FIELD VERIFY EXACT A.I.C. RATING OF LANDLORD'S DISTRIBUTION EQUIPMENT, FURNISH AND INSTALL TENANT'S SYSTEM TO MATCH.
- ELECTRICAL CONTRACTOR SHALL BALANCE ALL PANELS AND ELECTRICAL EQUIPMENT TO ±10% BETWEEN PHASES: A/B B/C, A/C REGARDLESS OF CIRCUITING INDICATED.
- PROPER CLEARANCE MUST BE MAINTAINED ABOUT ELECTRICAL EQUIPMENT PER N.E.C. FIELD VERIFY EXACT MOUNTING SPACE AVAILABLE IN ELECTRICAL ROOM/AREA PRIOR TO INSTALLATION OF ELECTRICAL EQUIPMENT.
- ELECTRICAL CONTRACTOR SHALL MAKE ALL FINAL ELECTRICAL CONNECTIONS FOR A COMPLETE ELECTRICAL DISTRIBUTION SYSTEM.
- TENANT'S NAME AND SPACE NUMBER SHALL BE APPLIED TO DISCONNECT SWITCH AT SWITCHGEAR WITH BLACK PLASTIC LAMENT WITH WHITE LETTERS.

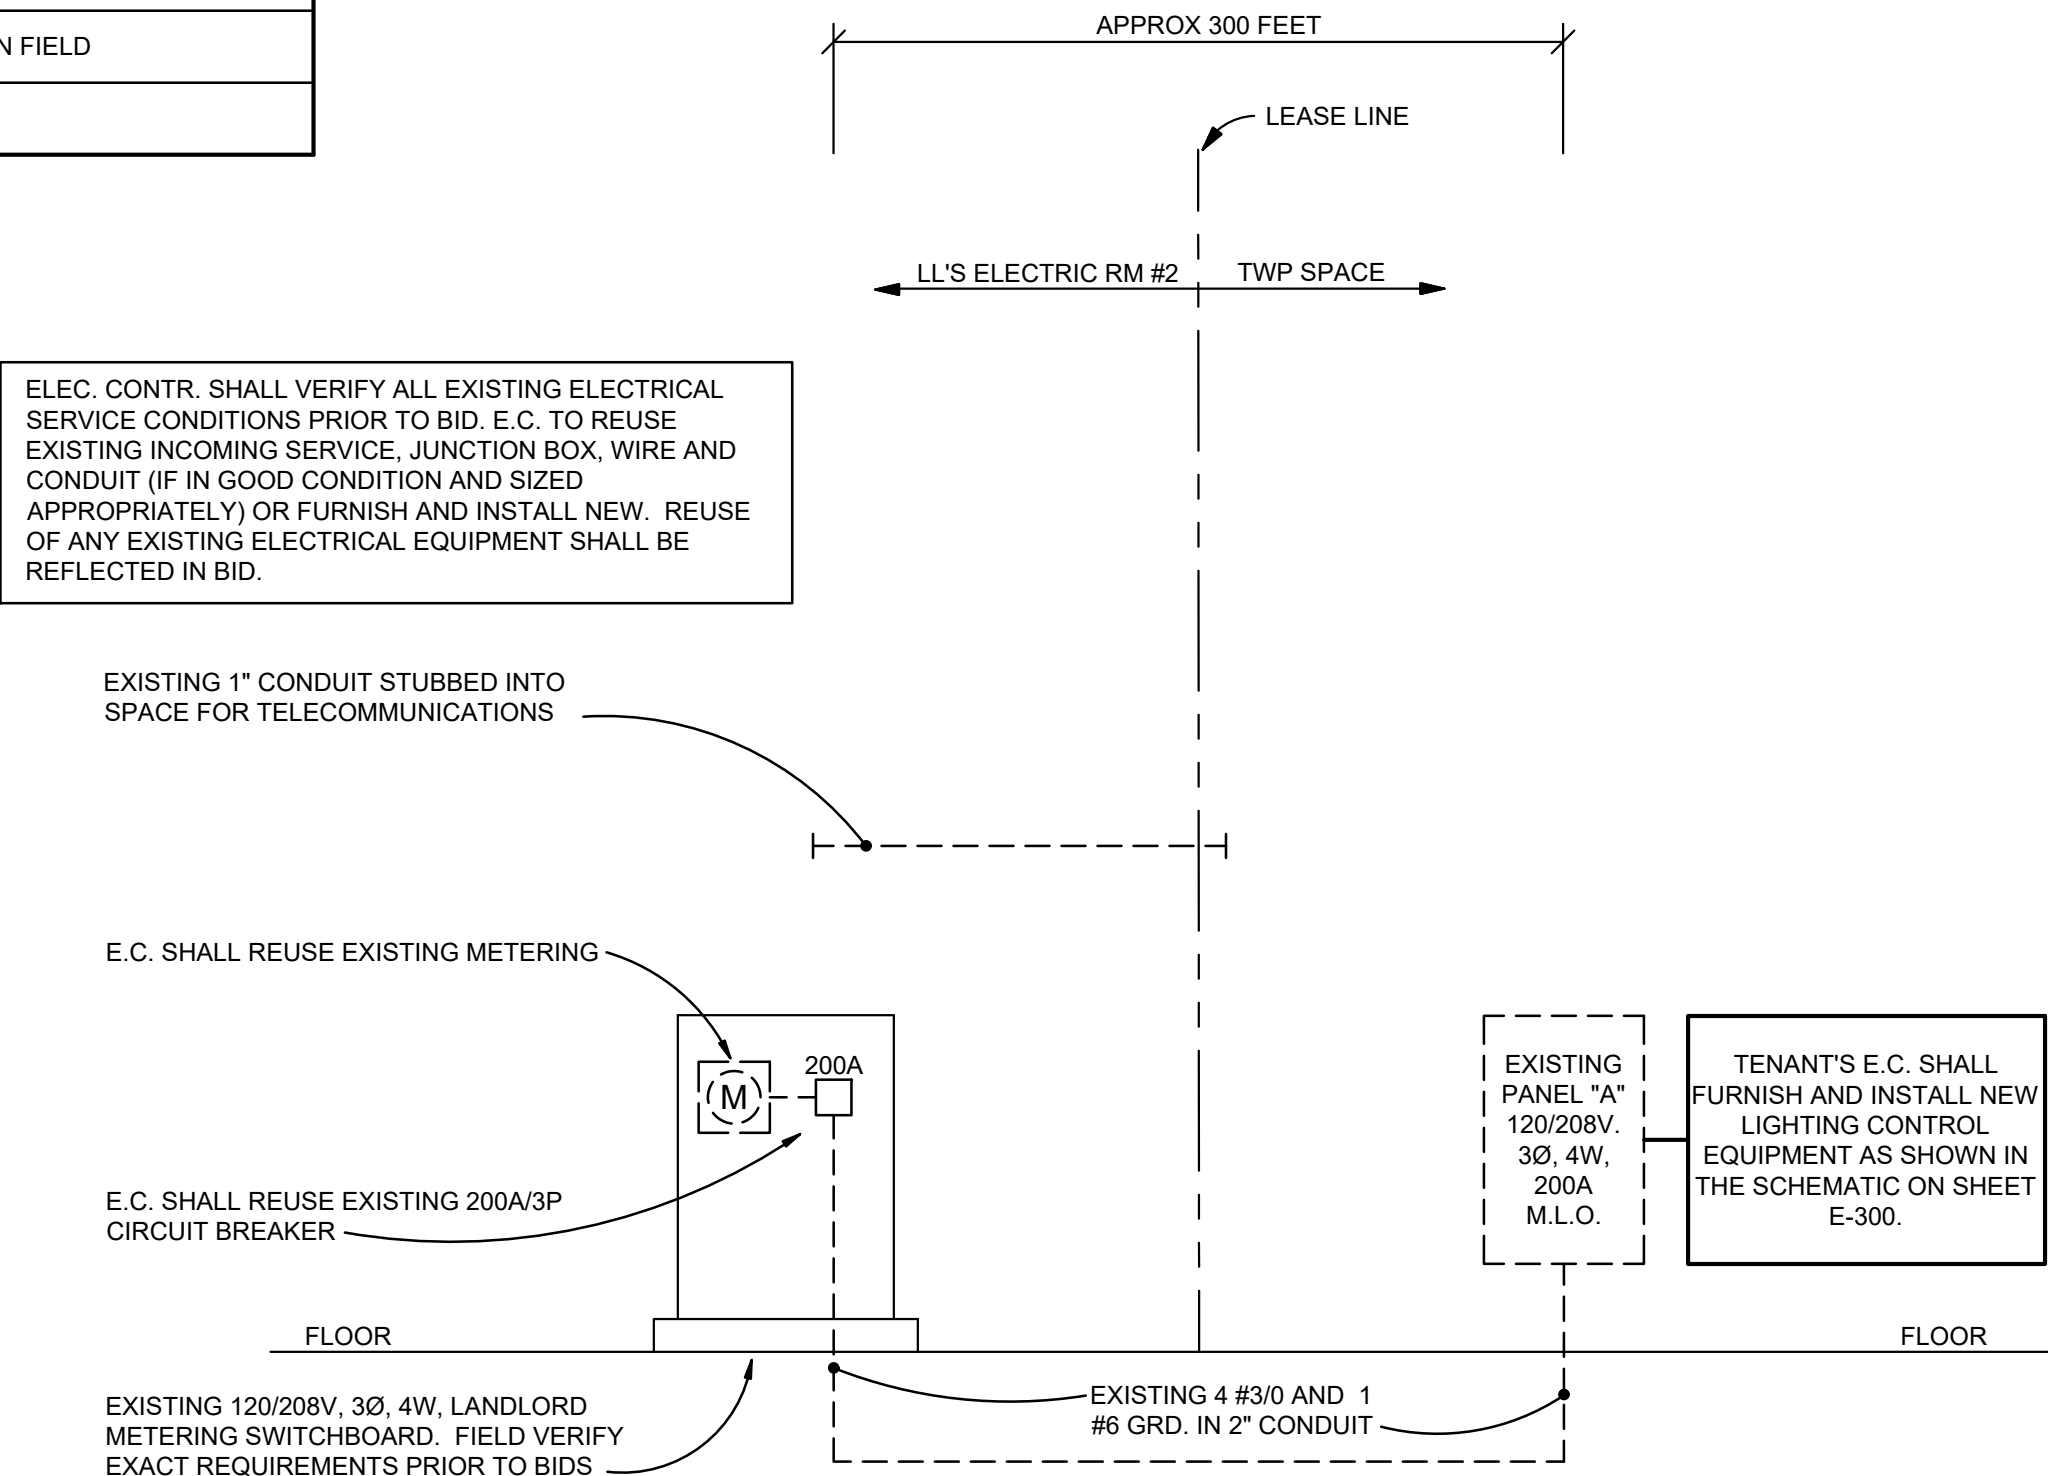

EXISTING POWER RISER DIAGRAM NTS



M, LLC
750 Brooksedge Blvd.
Westerville, Ohio 43081
phone: 614.839.4639
fax: 614.839.2222

Authorization #29103

THIS ITEM HAS BEEN DIGITALLY SIGNED AND SEALED BY MARK P. HUFFNAGLE ON THIS DATE ADJACENT TO THE SEAL. PRINTED COPIES OF THIS DOCUMENT ARE NOT CONSIDERED SIGNED AND SEALED AND THE SIGNATURE MUST BE VERIFIED ON ANY ELECTRONIC COPIES.

SEAL

DRAWINGS ISSUED

No.	Rev	Date	Description
1		06.18.26	LL REVIEW SET
2		06.25.26	ISSUE FOR PERMIT

PROJECT NAME:

TWP NAPLES



PROJECT ADDRESS:

WATERSIDE SHOPS
5455 TAMAMIAMI TRL N
NAPLES, FL 34108

DRAWING TITLE:

ELECTRICAL SCHEDULES AND DETAILS

Project No.	2642110
Scale:	AS NOTED
Date:	05-15-2026
Drawn By:	BB
Checked BY:	CF
DRAWING NO:	

E-400

E-500



COMcheck Software Version COMcheckWeb
Interior Lighting Compliance Certificate

Project Information

Energy Code: 90.1 (2019) Standard
Project Title: 2642110 - TWP - Waterside Shops
Project Type: Alteration

Construction Site: 5455 Tamiami Trail Ln. - Suite B-7
Naples, Florida 34108
Owner/Agent: TWP
Designer/Contractor: M-Engineering
750 Brookside Blvd.
Westerville, Ohio 43081
614-839-4639
www.mengineering.us.com

Allowed Interior Lighting Power

A Area Category	B Floor Area (ft2)	C Allowed Watts / ft2	D Allowed Watts
1-Restroom (Common Space Types:Restrooms)	39	0.63	25
2-Stock (Common Space Types:Storage >=50 - <=1000 sq.ft.)	488	0.43	210
3-Fitting Room (Retail:Dressing/Fitting Room)	144	0.51	73
4-Sales Area (Retail:Sales Area)	1288	1.05	1352
5-Corridor (Common Space Types:Corridor/Transition <8 ft wide)	102	0.41	42
Total Allowed Watts =			1702

Proposed Interior Lighting Power

A Fixture ID : Description / Lamp / Wattage Per Lamp / Ballast	B Lamps/ Fixture	C # of Fixture	D Fixture Watt.	E (C X D)
Restroom (Common Space Types: Restrooms, 39 sq.ft.) LED: L4: Wall Sconce: Other:	1	1	18	18
Stock (Common Space Types: Storage >=50 - <=1000 sq.ft., 488 sq.ft.) LED: L3: Linear Strip: Other:	1	4	40	160
Fitting Room (Retail: Dressing/Fitting Room, 144 sq.ft.) LED: L1: Adjustable Downlight: Other:	1	6	21	126
Sales Area (Retail: Sales Area, 1288 sq.ft.) LED: L1: Adjustable Downlight: Other:	1	47	21	987
Corridor (Common Space Types: Corridor/Transition <8 ft wide, 102 sq.ft.) LED: L3: Linear Strip: Other:	1	2	40	80
Total Proposed Watts =				1371

Project Title: 2642110 - TWP - Waterside Shops
Data filename: Report date: 06/16/26
Page 1 of 5

Interior Lighting PASSES

Interior Lighting Compliance
Statement

Compliance Statement: The proposed interior lighting alteration project represented in this document is consistent with the building plans, specifications, and other calculations submitted with this permit application. The proposed interior lighting systems have been designed to meet the 90.1 (2019) Standard requirements in COMcheck Version COMcheckWeb and to comply with any applicable mandatory requirements listed in the Inspection Checklist.

Brian Barta - Electrical Designer
Name - Title Signature Date 06/16/26

Project Title: 2642110 - TWP - Waterside Shops
Data filename: Report date: 06/16/26
Page 2 of 5



COMcheck Software Version COMcheckWeb
Inspection Checklist

Energy Code: 90.1 (2019) Standard

Requirements: 100.0% were addressed directly in the COMcheck software

Text in the "Comments/Assumptions" column is provided by the user in the COMcheck Requirements screen. For each requirement, the user certifies that a code requirement will be met and how that is documented, or that an exception is being claimed. Where compliance is itemized in a separate table, a reference to that table is provided.

Section # & Req.ID	Plan Review	Complies?	Comments/Assumptions
4.2.2, 8.4.1.1, 8.4.1.2, 8.7 [PR6] ²	Plans, specifications, and/or calculations provide all information with which compliance can be determined for the electrical systems and equipment and document where exceptions are claimed. Feeder connectors sized in accordance with approved plans and branch circuits sized for maximum drop of 3%.	☐ Complies ☐ Does Not ☐ Not Observable ☐ Not Applicable	Requirement will be met. Location on plans/spec: E-200, E-300
4.2.2, 9.4.3, 9.7 [PR4] ¹	Plans, specifications, and/or calculations provide all information with which compliance can be determined for the interior lighting and electrical systems and equipment and document where exceptions to the standard are claimed. Information provided should include interior lighting power calculations, wattage of bulbs and ballasts, transformers and control devices.	☐ Complies ☐ Does Not ☐ Not Observable ☐ Not Applicable	Requirement will be met. Location on plans/spec: E-200, E-300

Additional Comments/Assumptions:

1 High Impact (Tier 1) 2 Medium Impact (Tier 2) 3 Low Impact (Tier 3)

Project Title: 2642110 - TWP - Waterside Shops
Data filename: Report date: 06/16/26
Page 3 of 5

Section # & Req.ID	Rough-In Electrical Inspection	Complies?	Comments/Assumptions
8.4.2 [EL10] ²	At least 50% of all 125 volt 15- and 20-Amp receptacles are controlled by an automatic control device.	☐ Complies ☐ Does Not ☐ Not Observable ☐ Not Applicable	Requirement will be met. Location on plans/spec: E-100, E-300
8.4.3 [EL11] ²	New buildings have electrical energy use measurement devices installed. Where tenant spaces exist, each tenant is monitored separately. In buildings with a digital control system the energy use is transmitted to to control system and displayed graphically.	☐ Complies ☐ Does Not ☐ Not Observable ☐ Not Applicable	Exception: Individual tenant spaces less than 10,000 R2.
9.4.1.1 [EL1] ²	Automatic control requirements prescribed in Table 9.6.1, for the appropriate space type, are installed. Mandatory lighting controls (labeled as "REQ") and optional choice controls (labeled as "ADD1" and "ADD2") are implemented.	☐ Complies ☐ Does Not ☐ Not Observable ☐ Not Applicable	Requirement will be met. Location on plans/spec: E-200, E-300
9.4.1.1 [EL2] ²	Independent lighting controls installed per approved lighting plans and all manual controls readily accessible and visible to occupants.	☐ Complies ☐ Does Not ☐ Not Observable ☐ Not Applicable	Requirement will be met. Location on plans/spec: E-200
9.4.1.1f [EL13] ¹	Daylight areas under skylights and roof monitors that have more than 150 W combined input power for general lighting are controlled by photoccontrols.	☐ Complies ☐ Does Not ☐ Not Observable ☐ Not Applicable	Requirement will be met. Location on plans/spec: E-200
9.4.1.3 [EL4] ²	Separate lighting control devices for specific uses installed per approved lighting plans.	☐ Complies ☐ Does Not ☐ Not Observable ☐ Not Applicable	Requirement will be met. Location on plans/spec: E-200
9.6.2 [EL8] ¹	Additional interior lighting power allowed for special functions per the approved lighting plans and is automatically controlled and separated from general lighting.	☐ Complies ☐ Does Not ☐ Not Observable ☐ Not Applicable	Requirement will be met. Location on plans/spec: E-200

Additional Comments/Assumptions:

1 High Impact (Tier 1) 2 Medium Impact (Tier 2) 3 Low Impact (Tier 3)

Project Title: 2642110 - TWP - Waterside Shops
Data filename: Report date: 06/16/26
Page 4 of 5

Section # & Req.ID	Final Inspection	Complies?	Comments/Assumptions
8.7.1 [FI16] ³	Furnished as-built drawings for electric power systems within 30 days of system acceptance.	☐ Complies ☐ Does Not ☐ Not Observable ☐ Not Applicable	Requirement will be met.
8.7.2 [FI17] ³	Furnished O&M instructions for systems and equipment to the building owner or designated representative.	☐ Complies ☐ Does Not ☐ Not Observable ☐ Not Applicable	Requirement will be met.
9.2.2.3 [FI18] ¹	Interior installed lamp and fixture lighting power is consistent with what is shown on the approved lighting plans, demonstrating proposed watts are less than or equal to allowed watts.	☐ Complies ☐ Does Not ☐ Not Observable ☐ Not Applicable	See the Interior Lighting fixture schedule for values.
9.4.4 [FI20] ¹	At least 75% of all permanently installed lighting fixtures in dwelling units have >= 55 lm/W efficacy or a >= 45 lm/W total luminaire efficacy.	☐ Complies ☐ Does Not ☐ Not Observable ☐ Not Applicable	Exception: Requirement does not apply.

Additional Comments/Assumptions:

1 High Impact (Tier 1) 2 Medium Impact (Tier 2) 3 Low Impact (Tier 3)

Project Title: 2642110 - TWP - Waterside Shops
Data filename: Report date: 06/16/26
Page 5 of 5




M , LLC
750 Brookside Blvd.
Westerville, Ohio 43081
phone: 614.839.4639
fax: 614.839.2222

Authorization #29103

THIS ITEM HAS BEEN DIGITALLY SIGNED AND SEALED BY MARK P. HUFFNAGLE ON THIS DATE ADJACENT TO THE SEAL. PRINTED COPIES OF THIS DOCUMENT ARE NOT CONSIDERED SIGNED AND SEALED AND THE SIGNATURE MUST BE VERIFIED ON ANY ELECTRONIC COPIES.

SEAL

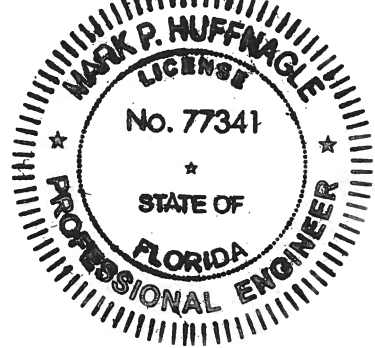

DRAWINGS ISSUED

No.	Rev	Date	Description
1		06.18.26	LL REVIEW SET
2		06.25.26	ISSUE FOR PERMIT

PROJECT NAME:

TWP NAPLES



PROJECT ADDRESS:


WATERSIDE SHOPS
5455 TAMAMI TRL N
NAPLES, FL 34108

DRAWING TITLE:

ELECTRICAL ENERGY
FORMS

Project No.	2642110
Scale:	AS NOTED
Date:	05-15-2026
Drawn By:	BB
Checked BY:	CF
DRAWING NO:	

E-600

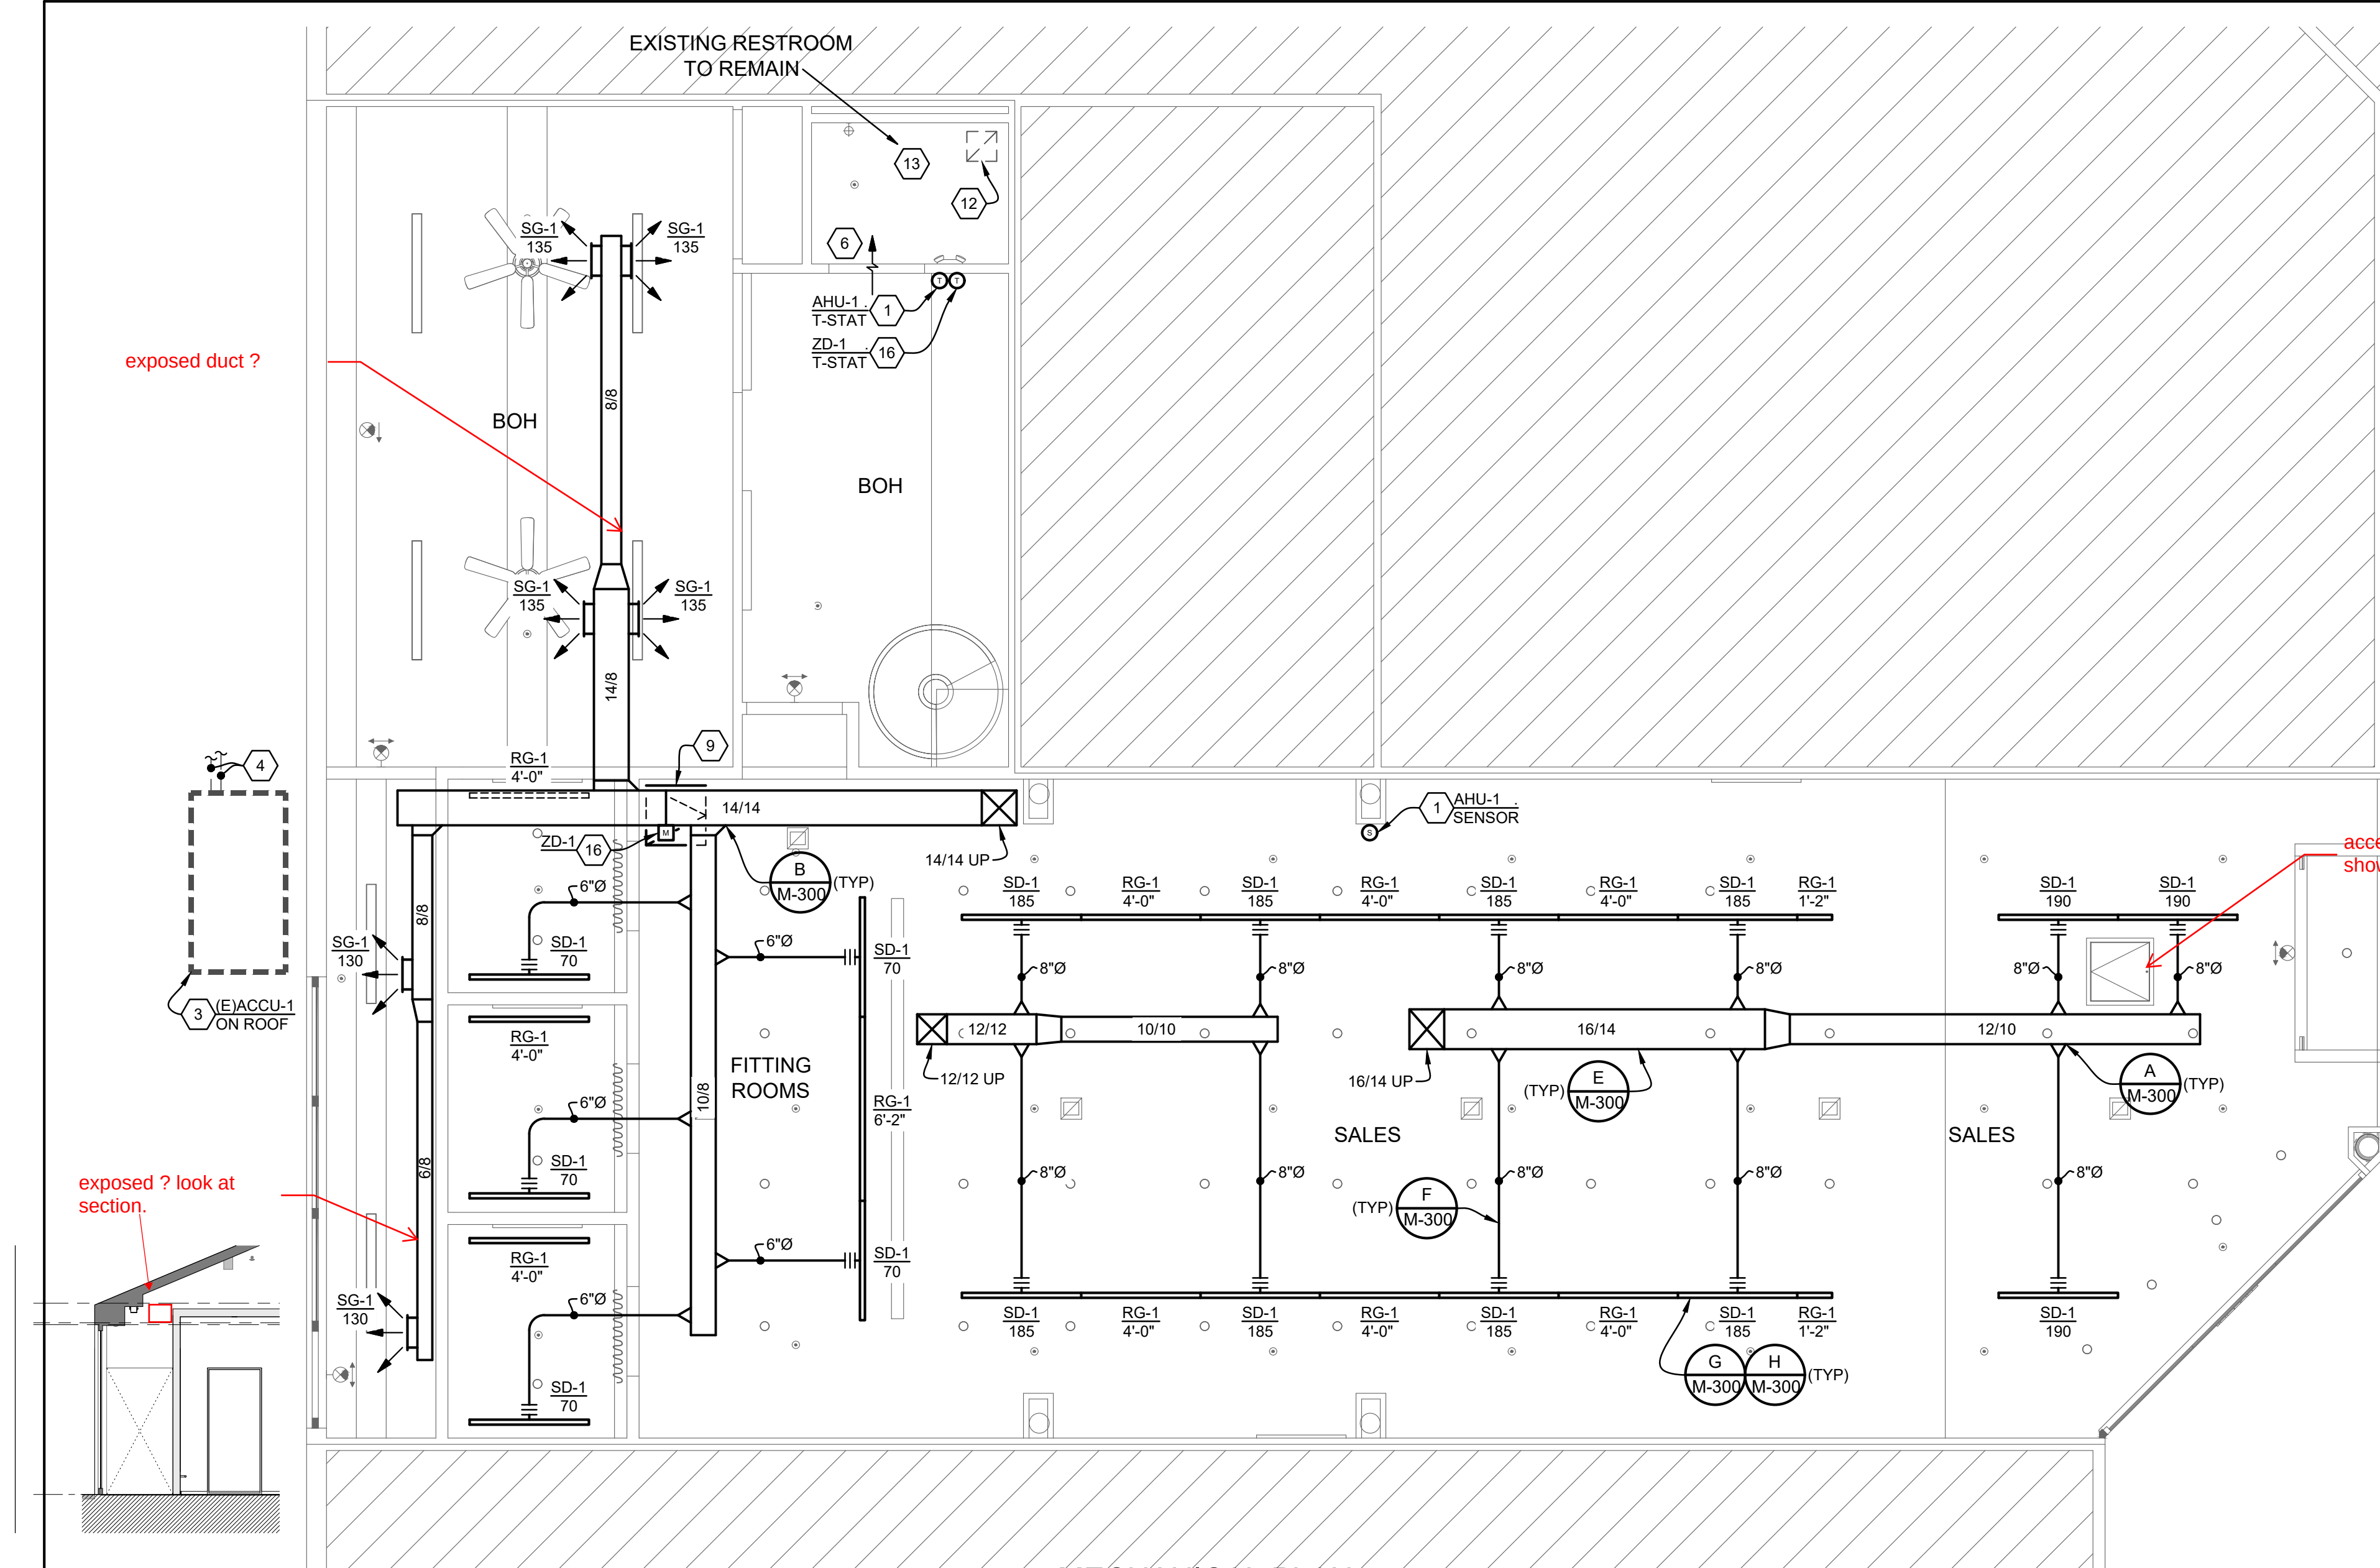

MECHANICAL PLAN

1/4"=1'-0"

GENERAL HVAC NOTES

- GENERAL CONTRACTOR SHALL BE RESPONSIBLE FOR DEMOLITION AND REMOVAL OF EXISTING HVAC EQUIPMENT, DUCTWORK, DIFFUSERS, GRILLES, CONTROLS, ETC., AS REQUIRED TO FACILITATE NEW INSTALLATIONS.
- MECHANICAL CONTRACTOR SHALL BE RESPONSIBLE FOR COORDINATION OF ALL TRADES, LANDLORD REQUIREMENTS, CEILING HEIGHTS AND EXISTING STRUCTURAL CONDITIONS PRIOR TO FABRICATION OF ANY DUCTWORK OR ORDERING OF ANY EQUIPMENT.
- ALL WORK SHALL BE IN STRICT ACCORDANCE WITH ALL FEDERAL, STATE AND LOCAL CODES AND ORDINANCES.
- FURNISH ALL LABOR, MATERIALS, TOOLS, INCIDENTALS AND DETAILS NECESSARY TO PROVIDE A COMPLETE HEATING, VENTILATING, AIR CONDITIONING SYSTEM. INCLUDE ANY LABOR AND MATERIAL NOT SPECIFICALLY MENTIONED, BUT NECESSARY TO PROVIDE A COMPLETE AND OPERATING SYSTEM. ALL WORK SHALL BE INSTALLED IN A PROFESSIONAL MANNER AND SHALL MEET ALL THE REQUIREMENTS OF THE STATE BUILDING CODE, CITY BUILDING CODE, SAFETY AND HEALTH CODES, NFPA CODES AND ALL OTHER APPLICABLE CODES AND REQUIREMENTS. ALL COSTS FOR SAID REQUIREMENTS SHALL BE INCLUDED IN THIS CONTRACTORS BID PRICE.
- THIS CONTRACTOR SHALL SECURE AND PAY FOR ALL REQUIRED PERMITS AND INSPECTIONS AND PERFORM ALL TESTS CALLED FOR OR REQUIRED AS A PART OF HIS WORK. FURNISHED APPROVED CERTIFICATE OF FINAL INSPECTION, AND TURN OVER TO OWNER AT COMPLETION OF PROJECT.
- MECHANICAL PLANS ARE DIAGRAMMATIC, NOT SHOWING EVERY ITEM IN EXACT LOCATION OR DETAIL. MEASUREMENTS AND LOCATIONS MUST BE FIELD VERIFIED AND COORDINATED WITH ARCHITECTURAL, HVAC, FIRE PROTECTION, STRUCTURAL, ELECTRICAL AND OTHER BUILDING DRAWINGS.
- MECHANICAL CONTRACTOR TO PROVIDE TENANT WITH AS-BUILT DRAWINGS, ALL EQUIPMENT SHOP DRAWINGS, INFORMATION ON THERMOSTATS, CONTROL WIRING DIAGRAMS AND OTHER PERTINENT INFORMATION AT COMPLETION OF PROJECT.
- CONTRACTOR SHALL VERIFY ALL EXISTING SITE CONDITIONS PRIOR TO BID AND INCLUDE IN BID ALL COSTS TO MAKE FIELD COORDINATION AND ADJUSTMENT TO DUCTWORK FOR FIT INTO EXISTING STRUCTURE. CONTRACTOR SHALL VERIFY AND FIELD COORDINATE FINAL LOCATION OF MECHANICAL EQUIPMENT.
- NEW DUCTS USED TO CONVEY THE CONDITIONED AIR SUPPLY AND VENTILATION AIR ARE TO BE MADE OF CONTINUOUS SHEET METAL.
- DUCT LININGS (THERMAL AND ACOUSTICAL), VIBRATION ISOLATION CONNECTORS, FLEXIBLE DUCT CONNECTORS, AND DUCT TYPE TO BE APPROVED BY CODE AND LANDLORD.

- ALL BRANCH TAKE-OFFS SHALL BE PROVIDED WITH MANUAL BALANCING DAMPERS.
- ALL RECTANGULAR SUPPLY AND RETURN AIR DUCTWORK SHALL BE LINED WITH 1" THICK ACOUSTICAL LINER. LINED DUCTWORK DOES NOT REQUIRE EXTERIOR INSULATION. IF REQUIRED, EXTERNALLY INSULATE ALL RECTANGULAR SUPPLY AND RETURN AIR DUCTWORK WITH 1 1/2" THICK, 1.5 LBS. DENSITY FOIL FACED FIBERGLASS INSULATION IN PLACE OF ACOUSTICAL LINER. DUCT DIMENSIONS SHOWN ARE INSIDE NET DIMENSIONS, ADD TO SHEET METAL SIZE FOR INSULATION. IN GENERAL, DUCTWORK TIGHT TO UNDERSIDE OF STRUCTURE UNLESS OTHERWISE NOTED OR REQUIRED BY FIELD CONDITIONS. COORDINATE EXACT MOUNTING HEIGHT IN FIELD WITH GENERAL CONTRACTOR, ROUND RIGID SUPPLY, RETURN, ALL RELIEF AIR AND ALL OUTSIDE AIR DUCTS SHALL BE EXTERNALLY INSULATED WITH 1 1/2" THICK, 1.5 LBS. DENSITY FOIL FACED FIBERGLASS INSULATION. ROUND DUCTWORK IN CONDITIONED SPACE DOES NOT REQUIRE INSULATION UNLESS OTHERWISE NOTED.
- ALL DUCTWORK SHALL BE SHEET METAL FABRICATED IN ACCORDANCE WITH ASHRAE GUIDE AND SMACNA MANUAL LATEST EDITIONS.
- FLEXIBLE INSULATED DUCTS SHALL BE MAXIMUM 5'-0" LONG AND SHALL MEET INSTALLATION AND MATERIAL REQUIREMENTS OF LOCAL CODES.
- THE MECHANICAL CONTRACTOR SHALL FURNISH AND INSTALL A COMPLETE TEMPERATURE CONTROL SYSTEM TO INCLUDE: PANELS, MODULES, RELAYS, WIRING, THERMOSTATS, SENSORS, DAMPERS, ACTUATORS AND ALL MISCELLANEOUS ITEMS AS REQUIRED TO FULFILL THE DESIGN INTENT AS INDICATED ON THE PLANS AND IN THE CODED NOTES.
- ALL TEMPERATURE CONTROLS, FIRE ALARM COMPONENTS, EQUIPMENT NAMEPLATES, LABELS, OR COLOR CODED COMPONENTS SHALL BE MASKED DURING PAINTING TO PREVENT DAMAGE FROM OVER-SPRAY OR OBSCURING INFORMATION.
- ALL LOW VOLTAGE WIRING AND CONDUIT REQUIRED FOR MECHANICAL EQUIPMENT SHALL BE FURNISHED AND INSTALLED BY MECHANICAL CONTRACTOR. CONTRACTOR SHALL BE RESPONSIBLE FOR COORDINATING WITH ELECTRICAL CONTRACTOR ALL WIRING AND CONDUIT REQUIRED FOR EQUIPMENT OPERATION AND CONTROL.
- EXISTING SPRINKLER SYSTEM TO BE MODIFIED AS REQUIRED FOR COVERAGE TO MEET LOCAL CODES AND LANDLORD REQUIREMENTS. APPROVAL ALSO REQUIRED BY LANDLORD'S INSURER. G.C. SHALL HIRE LANDLORD APPROVED SPRINKLER CONTRACTOR TO DESIGN, PERMIT AND INSTALL SPRINKLER SYSTEM. SHOP DRAWINGS SHALL BE SUBMITTED TO LANDLORD FOR REVIEW AND APPROVAL.
- IT IS THE CONTRACTOR'S RESPONSIBILITY TO ENSURE THAT THE MECHANICAL EQUIPMENT COMPONENTS ARE INSTALLED AT LOCATIONS AND ELEVATIONS WHICH MAKE THEM READILY ACCESSIBLE FOR ROUTINE MAINTENANCE WITHOUT REQUIRING ANY EXTRAORDINARY MEASURES.

MECHANICAL CODED NOTES


- MECHANICAL CONTRACTOR SHALL REMOVE EXISTING CONTROLS AND FURNISH AND INSTALL A PROGRAMMABLE THERMOSTAT WITH REMOTE SENSOR AT 4 FT. ABOVE FINISHED FLOOR. COORDINATE EXACT LOCATION WITH TENANT. THE ENTIRE CONTROL SYSTEM SHALL BE PROVIDED COMPLETE IN EVERY RESPECT BY THE MECHANICAL CONTRACTOR AND COMPATIBLE THE EXISTING SPLIT DX SYSTEM. THE CONTROL SYSTEM SHALL INCLUDE THE FOLLOWING COMPONENTS AND FUNCTIONS:
 - PROGRAMMABLE THERMOSTAT WITH REMOTE SENSOR
 - 2-POSITION OUTDOOR AIR DAMPER ACTUATOR (DAMPER BY MECHANICAL CONTRACTOR).
- (E)AHU-1 - AIR HANDLING UNIT EXISTING SPLIT SYSTEM DX AIR HANDLING UNIT SHALL BE REUSED AT EXISTING LOCATION. CLEAN, INSPECT AND REPAIR AS REQUIRED TO ENSURE PROPER OPERATING CONDITION. REBALANCE FANS TO CFM SHOWN ON PLANS. FURNISH UNIT WITH TWO SETS OF STANDARD FILTERS. FILTERS IN UNIT TO BE REPLACED PRIOR TO TURNING STORE OVER TO TENANT. SEE AIR HANDLING UNIT SCHEDULE FOR FURTHER INFORMATION
- (E)ACCU-1 - AIR COOLED CONDENSING UNIT EXISTING AIR COOLED CONDENSING UNIT TO BE REUSED AT EXISTING LOCATION. CLEAN, INSPECT AND REPAIR AS REQUIRED TO ENSURE PROPER OPERATING CONDITION. SEE AIR COOLED CONDENSING UNIT SCHEDULE FOR FURTHER INFORMATION.
- EXISTING REFRIGERANT LINES TO BE REUSED AT EXISTING LOCATIONS. VERIFY EXACT SIZE AND LOCATIONS IN THE FIELD.
- EXISTING CONDENSATE PIPING SHALL BE REUSED AT EXISTING LOCATIONS. VERIFY EXACT SIZE AND LOCATIONS IN THE FIELD. CLEAN EXISTING CONDENSATE DRAIN LINE TO ENSURE PROPER DRAINAGE. REPLACE IF REQUIRED.
- GENERAL CONTRACTOR TO UNDER CUT DOOR, 1" FOR AIR FLOW.
- MOTORIZED OUTDOOR AIR DAMPER. PROVIDE HONEYWELL LOW-LEAKAGE DAMPERS SIZED TO MATCH DUCT SHOWN AND 2-POSITION ACTUATOR. SUPPLY LINKAGE TO MATCH. WIRE DAMPER TO ASSOCIATED UNIT CONTROLS SO DAMPER IS OPEN IN OCCUPIED MODE AND CLOSED IN UNOCCUPIED MODE. ALL WIRING EQUIPMENT AND MISCELLANEOUS CONTROL DEVICES BY MECHANICAL CONTRACTOR.
- MECHANICAL CONTRACTOR SHALL FURNISH AND INSTALL DUCTWORK, SIZED AS INDICATED, FOR OUTSIDE AIR. CONTRACTOR SHALL CONNECT DUCTWORK TO THE RETURN AIR SIDE OF THE UNIT AND EXTEND DUCTWORK TO THE EXISTING OUTSIDE AIR DUCT AND MAKE NEW CONNECTION. VERIFY EXACT SIZE AND LOCATION OF EXISTING OUTSIDE AIR DUCT IN THE FIELD PRIOR TO BID.
- MECHANICAL CONTRACTOR SHALL FURNISH AND INSTALL A 24"x24" ACCESS PANEL FOR ACCESS TO EQUIPMENT ABOVE FINISHED CEILING.
- MECHANICAL CONTRACTOR SHALL PROVIDE AN OPENING IN THE WALL ABOVE FINISHED CEILING, SIZED AS INDICATED, FOR RETURN AIR BACK TO HVAC UNITS.

- DUCT SMOKE DETECTOR TO DE-ENERGIZE HVAC UNIT AND SIGNAL MALL FIRE ALARM SYSTEM. FURNISHED AND WIRED BY ELECTRICAL CONTRACTOR AND INSTALLED BY MECHANICAL CONTRACTOR. REFER TO ELECTRICAL DRAWINGS FOR DETAILS.
- EXISTING TOILET EXHAUST SYSTEM TO BE REUSED AT EXISTING LOCATION. MECHANICAL CONTRACTOR TO CLEAN, ADJUST AND LEAVE LIKE NEW.
- EXISTING PLUMBING FIXTURES, WATER HEATER, TRIM AND PIPING TO REMAIN. CLEAN ALL FIXTURES, TRIM, ETC., AND LEAVE IN "LIKE NEW" CONDITION.
- MAKE NEW CONNECTION TO (E)AHU-1 AND EXTEND NEW DUCTWORK AS INDICATED ON THE PLANS.
- EXISTING LOUVERED PANELS INTO THE MECHANICAL ROOM SHALL REMAIN FOR RETURN AIR BACK TO (E)AHU-1.
- ZD-1 - ZONE DAMPER MECHANICAL CONTRACTOR SHALL FURNISH AND INSTALL A ZONE DAMPER WITH CONTROLS EQUAL TO YOUNG REGULATOR. FURNISH #4075-IF ROUND DAMPER OR #3085-IF RECTANGULAR DAMPER. SIZED FOR DUCT INDICATED ON THE PLAN, WITH MODEL #T-720-IF ZONE THERMOSTAT MOUNTED AT 48" A.F.F. WHERE INDICATED ON THE PLAN. THE DAMPER AND THERMOSTAT SHALL BE MODULATING TYPE AND CAPABLE OF AUTO-CHANG-OVER. MOUNT CHANGE-OVER SENSOR IN THE DUCT PER MANUFACTURER'S PRINTED INSTRUCTIONS. THERMOSTAT SHALL CONTROL THE MOTOR OPERATED DAMPER IN THE SUPPLY DUCT AS FOLLOWS: WHEN THE MAIN AIR HANDLING UNIT IS IN THE COOLING MODE (LESS THAN 65 F., DUCT AIR TEMPERATURE) THE THERMOSTAT SHALL MODULATE THE DAMPER FROM ITS 20% (ADJUSTABLE) MINIMUM POSITION TO ITS 100% MAX POSITION AS REQUIRED TO MAINTAIN THE SET POINT. WHEN THE MAIN AIR HANDLING UNIT IS IN THE HEATING MODE THE MOTOR OPERATED DAMPER SHALL BE LOCKED OUT AND RETURNED TO ITS 100% MAXIMUM POSITION. 120V. CONNECTION BY THE ELECTRICAL CONTRACTOR. ALL LOW VOLTAGE SYSTEM BY THE MECHANICAL CONTRACTOR.

VERIFY ALL CONDITIONS IN THE FIELD PRIOR TO BID.

confused about mexx hvac scope. need to review. can we not leave as is ? why all new dropped duct

access panel not show on your plans.

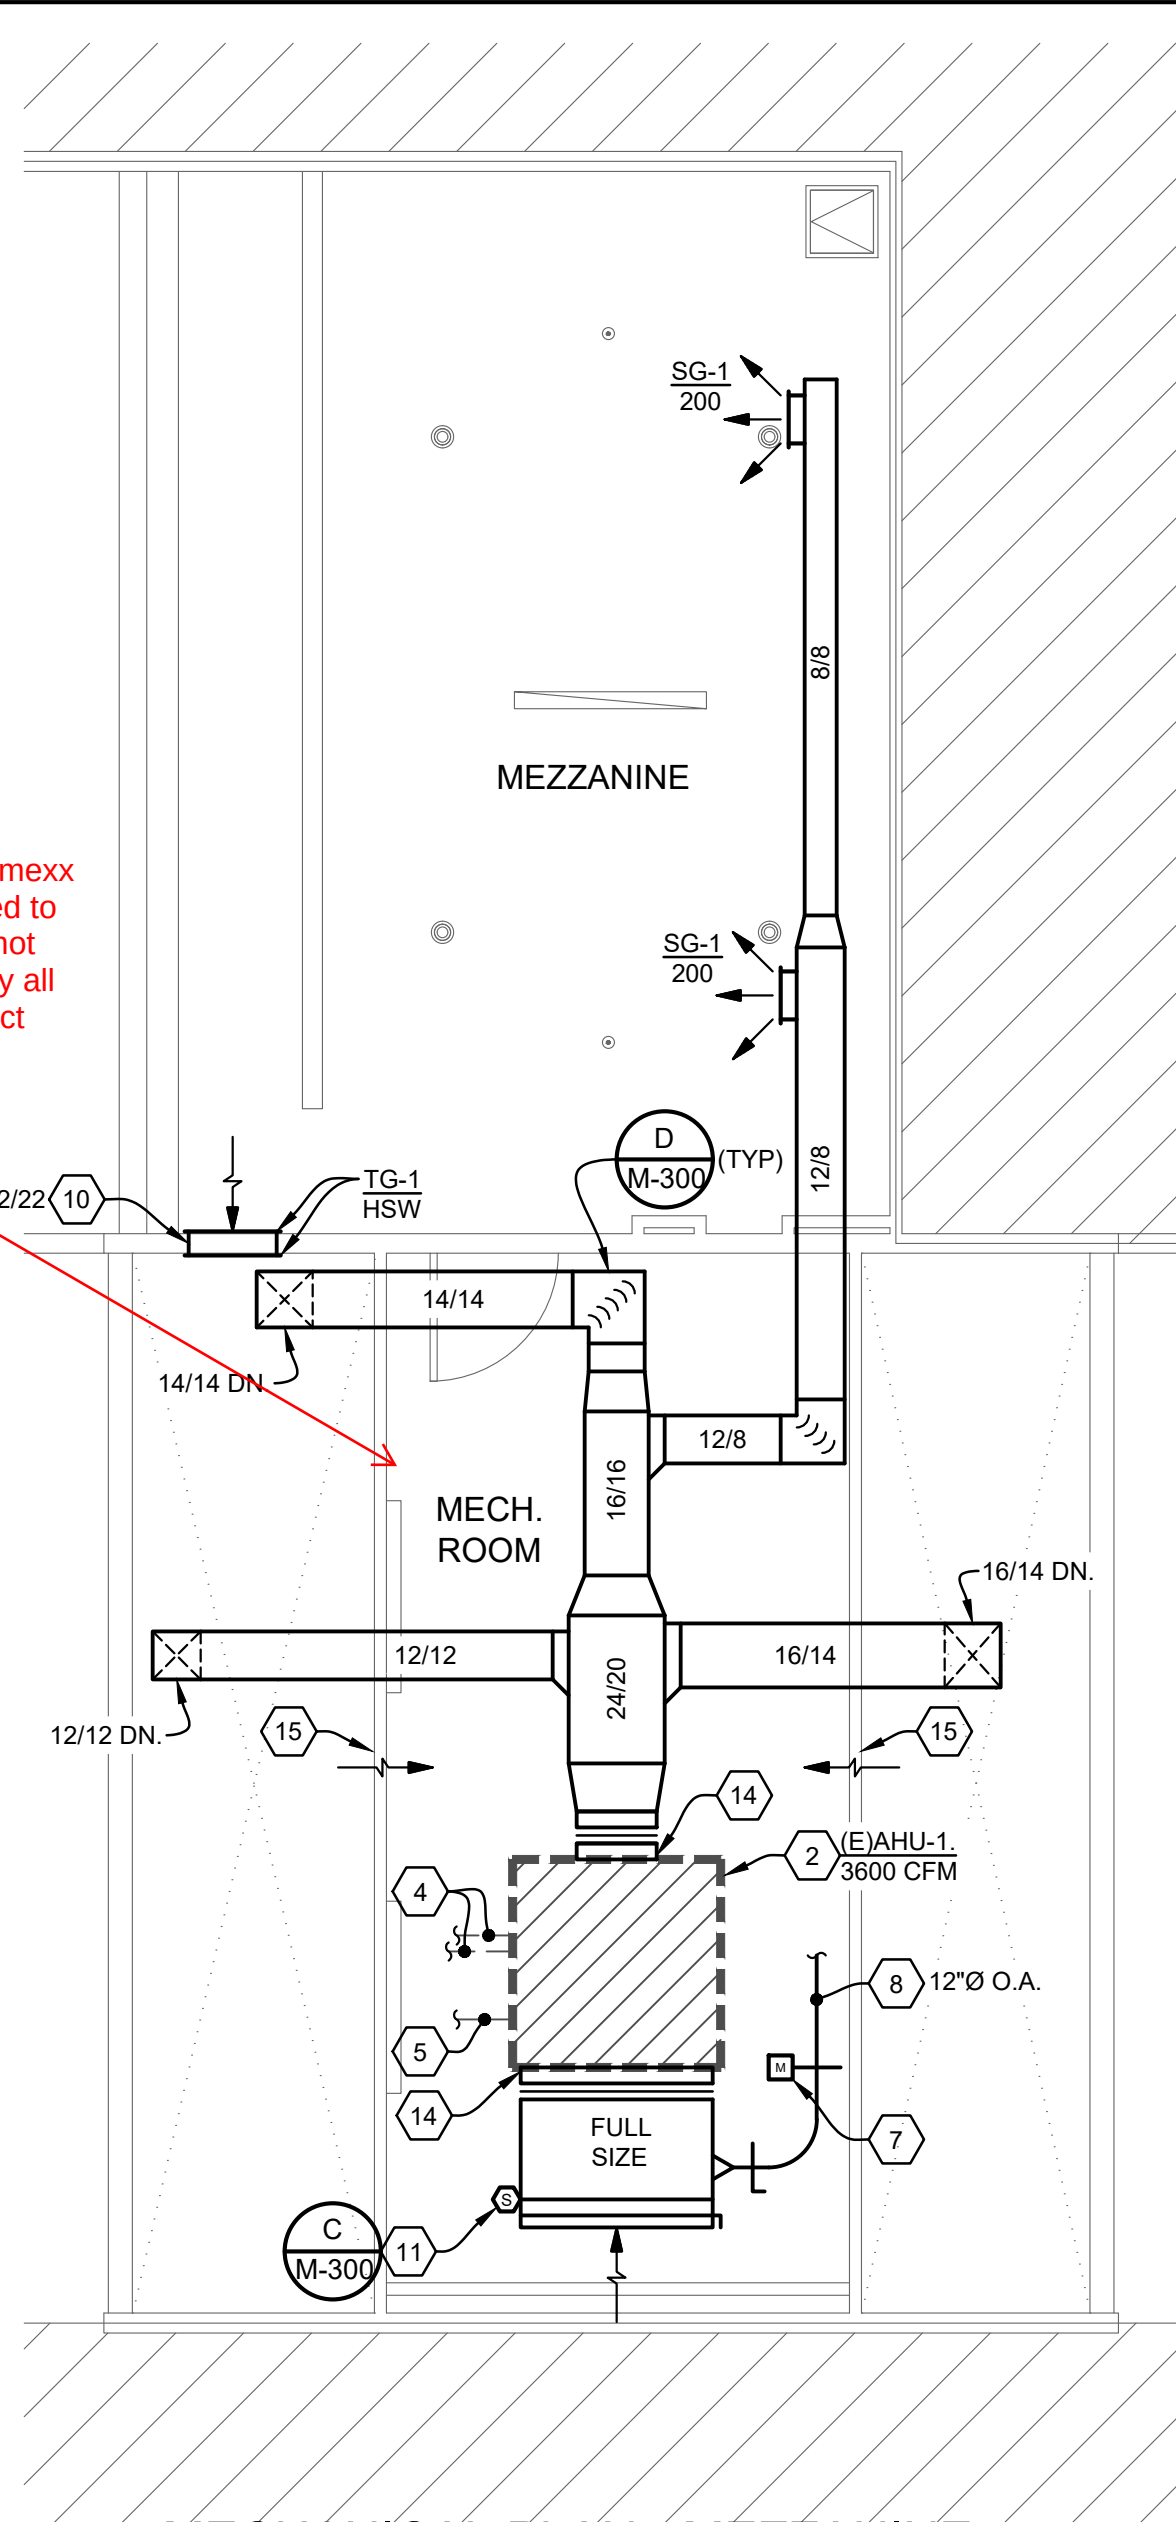

MECHANICAL PLAN - MEZZANINE

1/4"=1'-0"

FIELD VERIFY ALL CONDITIONS

DESIGN DRAWINGS ARE SCHEMATIC. THIS CONTRACTOR SHALL VISIT THE SITE PRIOR TO BIDDING OR AWARD OF CONTRACT TO INSPECT EXISTING FIELD CONDITIONS. THIS CONTRACT SHALL INCLUDE ALL LABOR AND MATERIALS NECESSARY FOR FIELD MODIFICATIONS DUE TO EXISTING CONDITIONS.


THE CONTRACTOR SHALL CONTACT THE ARCHITECT, ENGINEER OR OWNER PRIOR TO BIDDING FOR INTERPRETATIONS AND CLARIFICATIONS OF THE DESIGN AND INCLUDE IN HIS BID ALL COSTS TO MEET THE DESIGN INTENT. CLARIFICATIONS MADE BY THE ARCHITECT, ENGINEER OR OWNER AFTER BIDDING WILL BE FINAL AND SHALL BE IMPLEMENTED AT CONTRACTORS COST.

BIDDING CONTRACTORS SHALL HAVE A WORKING KNOWLEDGE OF LOCAL CODES AND ORDINANCES AND SHALL INCLUDE IN THEIR BIDS THE COSTS FOR ALL WORK INSTALLED IN STRICT ACCORDANCE WITH GOVERNING CODES. THE PLANS AND SPECIFICATIONS NOT WITHSTANDING, THE CONTRACTOR SHALL ALERT ARCHITECT, ENGINEER OR OWNER OF ANY APPARENT DISCREPANCIES BETWEEN GOVERNING CODES AND DESIGN INTENT.

SYMBOL LEGEND			
SYMBOL	DESCRIPTION	SYMBOL	DESCRIPTION
	SUPPLY AIR DIFFUSER		ROOF MOUNTED EQUIPMENT AS NOTED
	RETURN AIR GRILLE OR DUCT		CEILING EXHAUST FAN
	DUCT MOUNTED DIFFUSER		T-DENOTES THERMOSTAT
	SIDEWALL MOUNTED SUPPLY OR RETURN AIR LINEAR DIFFUSER		S-DENOTES SENSOR
	CEILING MOUNTED SUPPLY OR RETURN AIR LINEAR DIFFUSER		TURNING VANES
	SUPPLY AIR DUCT RISE		DUCT TRANSITIONS
	SIMILAR FOR RETURN AIR		BRANCH DUCT WITH SPIN-IN FITTING AND VOLUME DAMPER
	SUPPLY AIR DUCT DROP		F.D. - FIRE DAMPER
	SIMILAR FOR RETURN AIR		DUCT SMOKE DETECTOR
	EXISTING		MECHANICAL CONTRACTOR
	RELOCATED		ELECTRICAL CONTRACTOR
	HIGH SIDE WALL		
	LOW SIDE WALL		



THIS ITEM HAS BEEN DIGITALLY SIGNED AND SEALED BY MARK P. HUFFMAGE ON THIS DATE ADJACENT TO THE SEAL. PRINTED COPIES OF THIS DOCUMENT ARE NOT CONSIDERED SIGNED AND SEALED AND THE SIGNATURE MUST BE VERIFIED ON ANY ELECTRONIC COPIES.

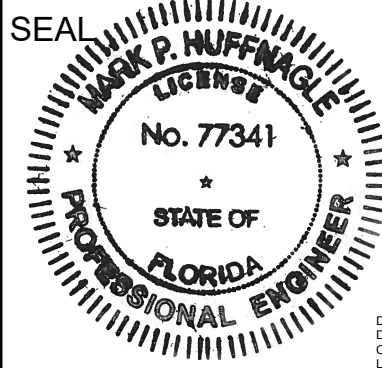

Copyright 2018 by Mark P. Huffmage
All Rights Reserved. No part of this document may be reproduced without written permission from Mark P. Huffmage, LLC. 2.5.4. 2018/08/25/09:00:00
Licensee: Mark P. Huffmage
Date: 2018/08/25 09:00:00

DRAWINGS ISSUED

No.	Rev	Date	Description
1		06.18.26	LL REVIEW SET
2		06.25.26	ISSUE FOR PERMIT

PROJECT NAME:

TWP NAPLES



PROJECT ADDRESS:

WATERSIDE SHOPS
5455 TAMiami TrL N
NAPLES, FL 34108

DRAWING TITLE:

MECHANICAL
PLAN

Project No.	2642110
Scale:	AS NOTED
Date:	05-15-2026
Drawn By:	CAH
Checked By:	JD
DRAWING NO:	

M-100

DESIGN WEATHER PARAMETERS														
Design Parameters:														
City Name	Naples													
Location	Florida													
Latitude	26.6	Deg.												
Longitude	81.9	Deg.												
Elevation	16.0	ft.												
Summer Design Dry-Bulb	94.0	°F												
Summer Coincident Wet-Bulb	77.0	°F												
Summer Daily Range	16.9	°F												
Winter Design Dry-Bulb	42.0	°F												
Winter Design Wet-Bulb	35.3	°F												
Atmospheric Clearness Number	0.90													
Average Ground Reflectance	0.20													
Soil Conductivity	0.800	BTU/(hr-ft²-F)												
Local Time Zone (GMT +/- N hours)	5.0	hours												
Consider Daylight Savings Time	No													
Simulation Weather Data	N/A													
Current Data is	User Modified													
Design Cooling Months	January to December													

HVAC LOAD CALCULATIONS

Air System Information														
Air System Name	TWP-Waterside Shops													
Equipment Class	SPLT AHU													
Air System Type	SZCAV													
Number of zones	1													
Floor Area	2321.0 ft²													
Location	Naples, Florida													

Sizing Calculation Information			
Calculation Months	Jan to Dec	Zone CFM Sizing	Sum of space airflow rates
Sizing Data	Calculated	Space CFM Sizing	Individual peak space loads

Central Cooling Coil Sizing Data														
Total coil load	8.5	Tons												
OA DB / WB	101.9	MBH												
Sensible coil load	77.2	MBH												
Coil CFM at Aug 1400	3600	CFM												
Max rack CFM	3600	CFM												
Sum of peak zone CFM	3600	CFM												
Sensible heat ratio	0.757													
CFM/Ton	424.1													
ft³/Ton	273.4													
BTU/(hr-ft²)	43.9													
Water flow @ 10.0 °F rise	N/A													
Load occurs at	Aug 1400													
OA DB / WB	93.5 / 76.9	°F												
Entering DB / WB	77.8 / 66.2	°F												
Leaving DB / WB	58.0 / 56.9	°F												
Coil ADP	55.8	°F												
Bypass Factor	0.100													
Resulting RH	55	%												
Design supply temp	57.2	°F												
Zone T-stat Check	1 of 1	OK												
Max zone temperature deviation	0.0	°F												

Central Heating Coil Sizing Data														
Max coil load	37.6	MBH												
Coil CFM at Des Htg	3600	CFM												
Max coil CFM	3600	CFM												
Water flow @ 20.0 °F drop	N/A													
Load occurs at	Des Htg													
BTU/(hr-ft²)	16.2													
Ent. DB / Lvg DB	65.3 / 75.0	°F												









Supply Fan Sizing Data														
Actual max CFM	3600	CFM												
Standard CFM	3598	CFM												
Actual max CFM/R²	1.55	CFM/R²												
Fan motor BHP	0.01	BHP												
Fan motor kW	0.01	kW												

Outdoor Ventilation Air Data														
Design airflow CFM	564	CFM/person												
CFM/R²	0.24	CFM/R²												

Space Loads and Airflows

Zone Name / Space Name	Mult.	Cooling Sensible (MBH)	Time of Peak Flow Load	Air Flow (CFM)	Heating Load (MBH)	Floor Area (ft²)	Space CFM/ft²
Zone 1 thru 5							
Z1-SALES	1	32.7	Jul 1400	2050	7.8	1080.0	1.90
Z2-Fitting Rooms	1	5.5	Jul 1400	350	0.7	344.0	1.02
Z3-BOH	1	11.5	Jul 1400	680	5.7	535.0	1.27
Z4-Hallway	1	4.2	Jul 1500	260	5.0	102.0	2.55
Z5-Mezzanine	1	3.8	Jul 1400	260	1.1	260.0	1.00

DESIGN COOLING				DESIGN HEATING			
COOLING DATA AT Aug 1400				HEATING DATA AT DES HGT			
COOLING OA DB / WB 93.5 °F / 76.9 °F				HEATING OA DB / WB 42.0 °F / 35.3 °F			
ZONE LOADS	Details	Sensible (BTU/hr)	Latent (BTU/hr)	Details	Sensible (BTU/hr)	Latent (BTU/hr)	
Window & Skylight Solar Loads	198 ft²	3581	-	198 ft²	-	-	-
Wall Transmission	140 ft²	140	-	140 ft²	256	-	-
Roof Transmission	2596 ft²	12711	-	2596 ft²	4770	-	-
Window Transmission	198 ft²	3013	-	198 ft²	4579	-	-
Skylight Transmission	0 ft²	0	-	0 ft²	0	-	-
Door Loads	0 ft²	0	-	0 ft²	0	-	-
Floor Transmission	0 ft²	0	-	0 ft²	0	-	-
Partitions	585 ft²	5389	-	585 ft²	8190	-	-
Ceiling	0 ft²	0	-	0 ft²	0	-	-
Overhead Lighting	0 W	0	-	0	0	-	-
Task Lighting	4532 W	13466	-	0	0	-	-
Electric Equipment	2425 W	7416	-	0	0	-	-
People	30	9949	8000	0	0	0	0
Infiltration	-	0	0	-	0	0	0
Miscellaneous	-	0	0	-	0	0	0
Safety Factor	10% / 10%	5167	800	15%	2669	-	-
>> Total Zone Loads	-	56834	8800	-	20465	-	0
Zone Conditioning	-	65823	8800	-	20865	-	-
Plenum Wall Load	0%	0	-	0	0	-	-
Plenum Roof Load	0%	0	-	0	0	-	-
Plenum Lighting Load	0%	0	-	0	0	-	-
Return Fan Load	3600 CFM	0	-	3600 CFM	0	-	0
Ventilation Fan	564 CFM	11308	15907	564 CFM	16807	-	0
Supply Fan Load	3600 CFM	28	-	3600 CFM	-28	-	-
Space Fan Coil Fans	-	0	-	0	0	-	-
Duct Heat Gain / Loss	0%	0	-	0%	0	-	-
>> Total System Loads	-	77159	24707	-	37644	-	0
Central Cooling Coil	-	77159	24709	-	37644	-	0
Central Heating Coil	-	0	-	-	37644	-	0
>> Total Conditioning	-	77159	24709	-	37644	-	0
Key:	Positive values are ckg loads Negative values are hgt loads			Positive values are hgt loads Negative values are ckg loads			

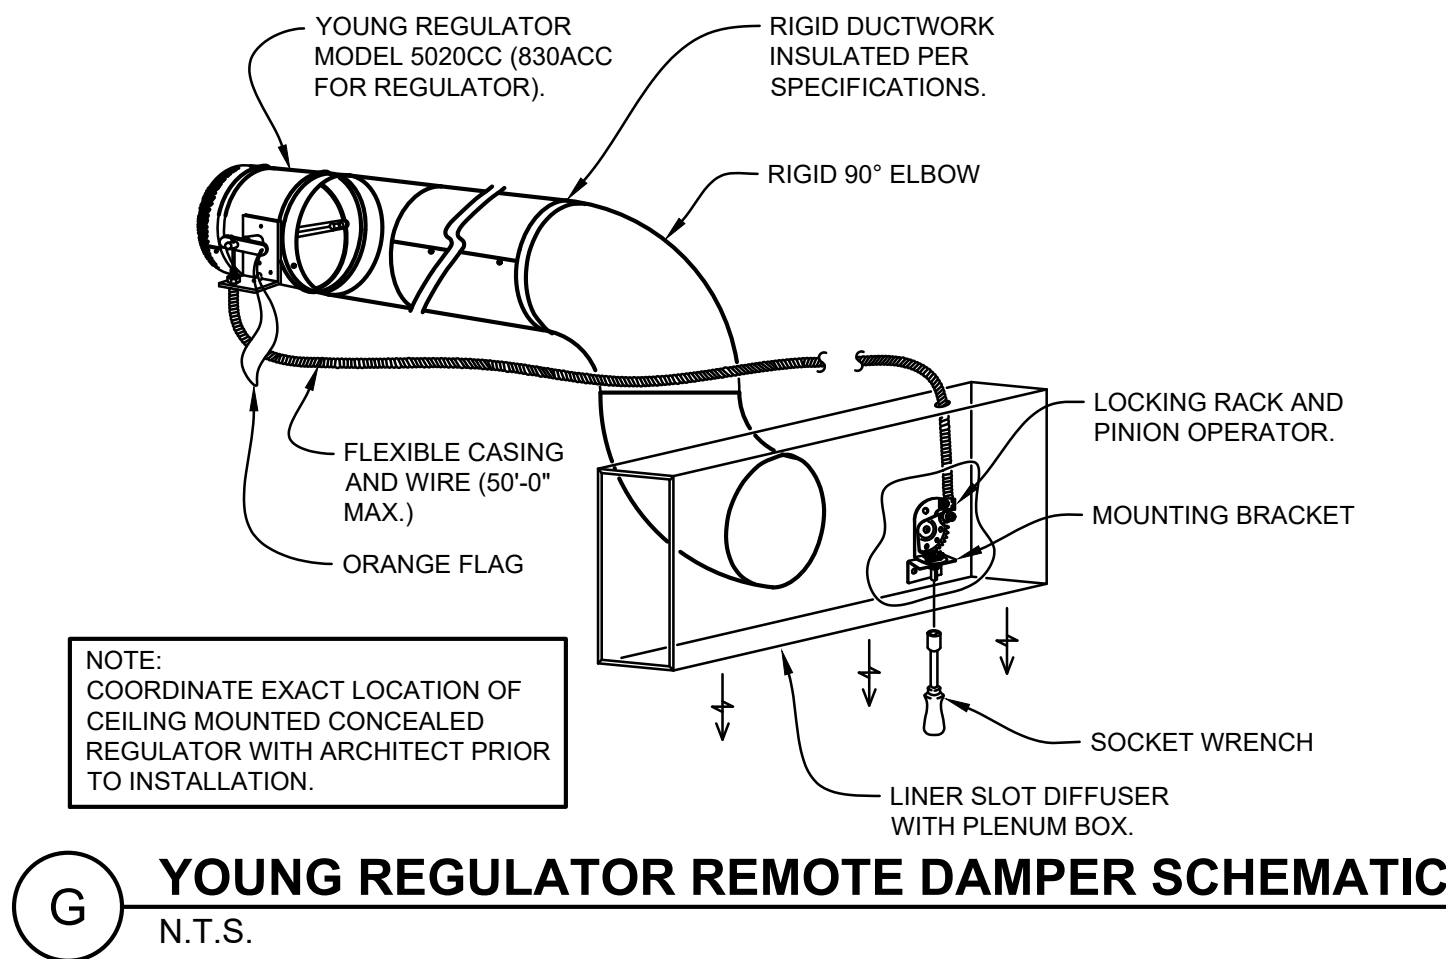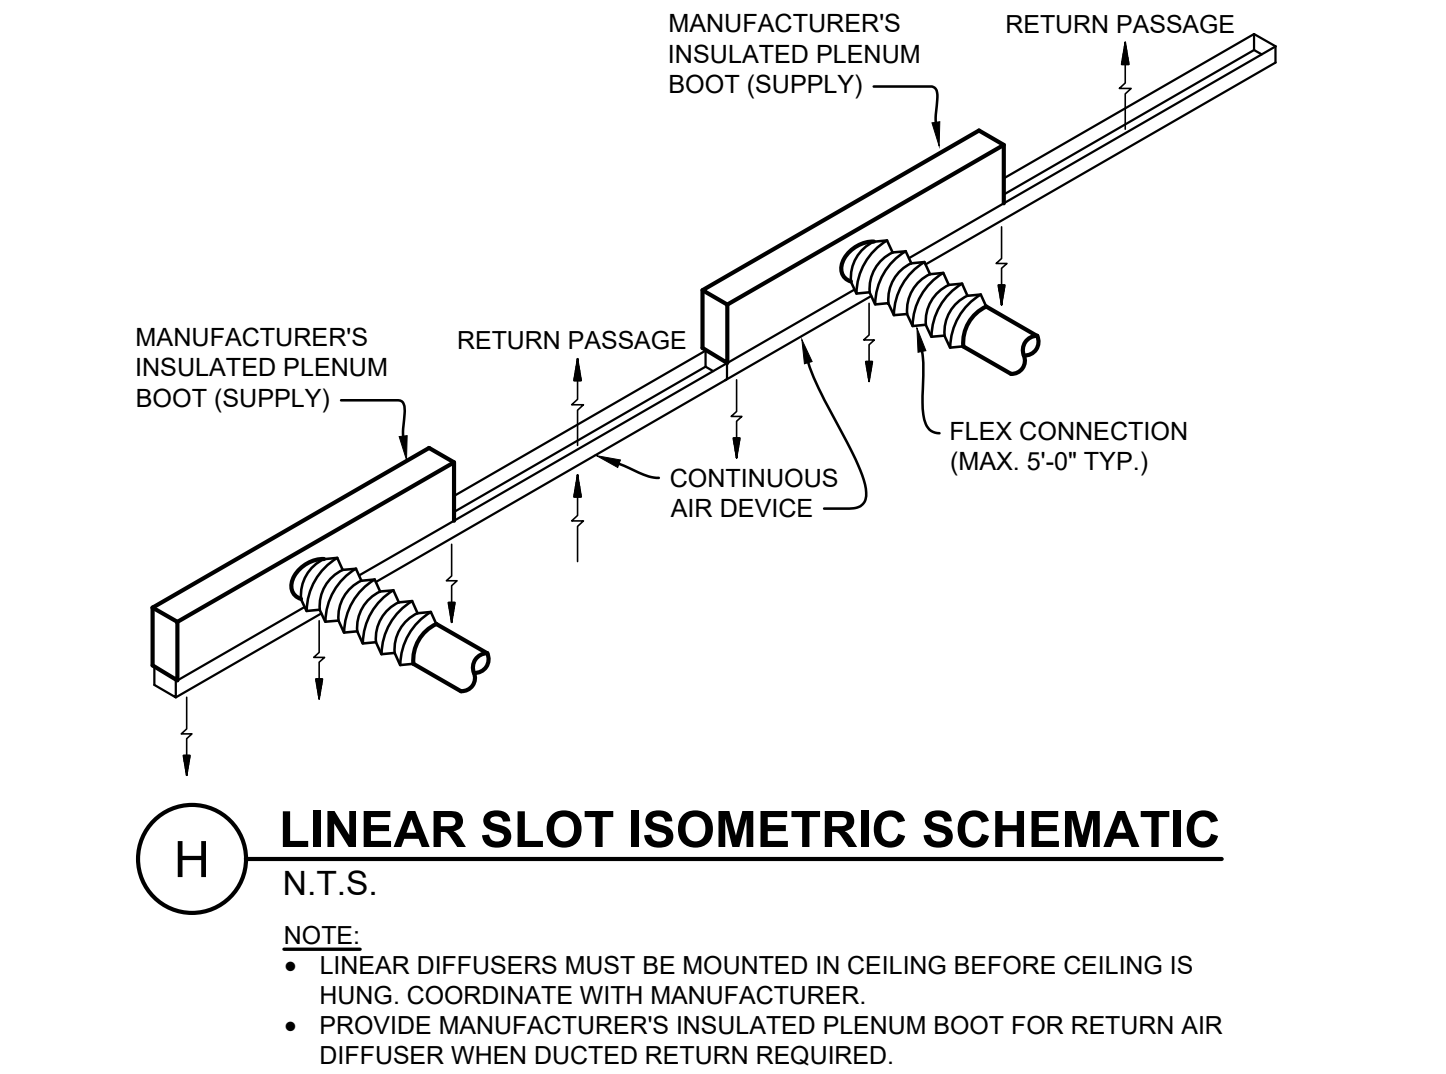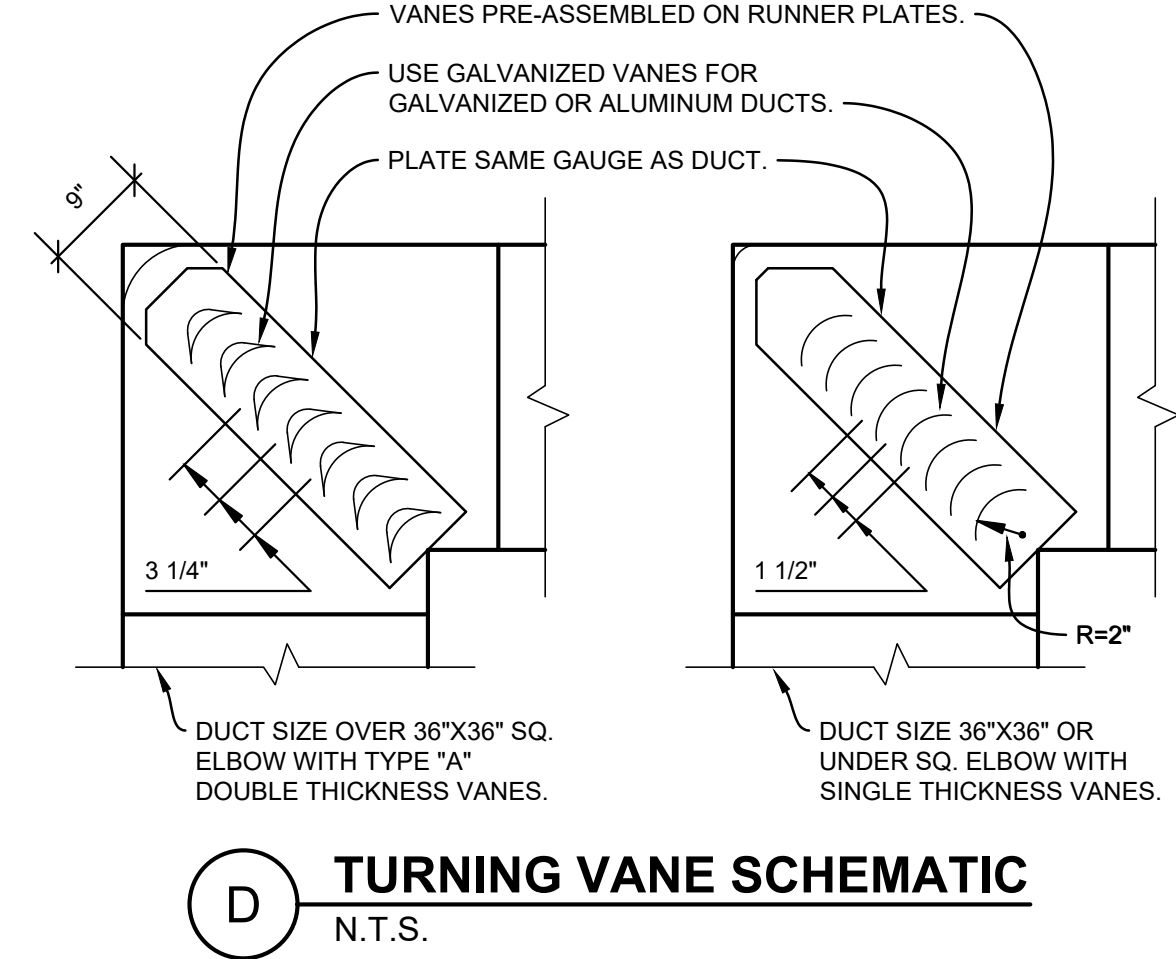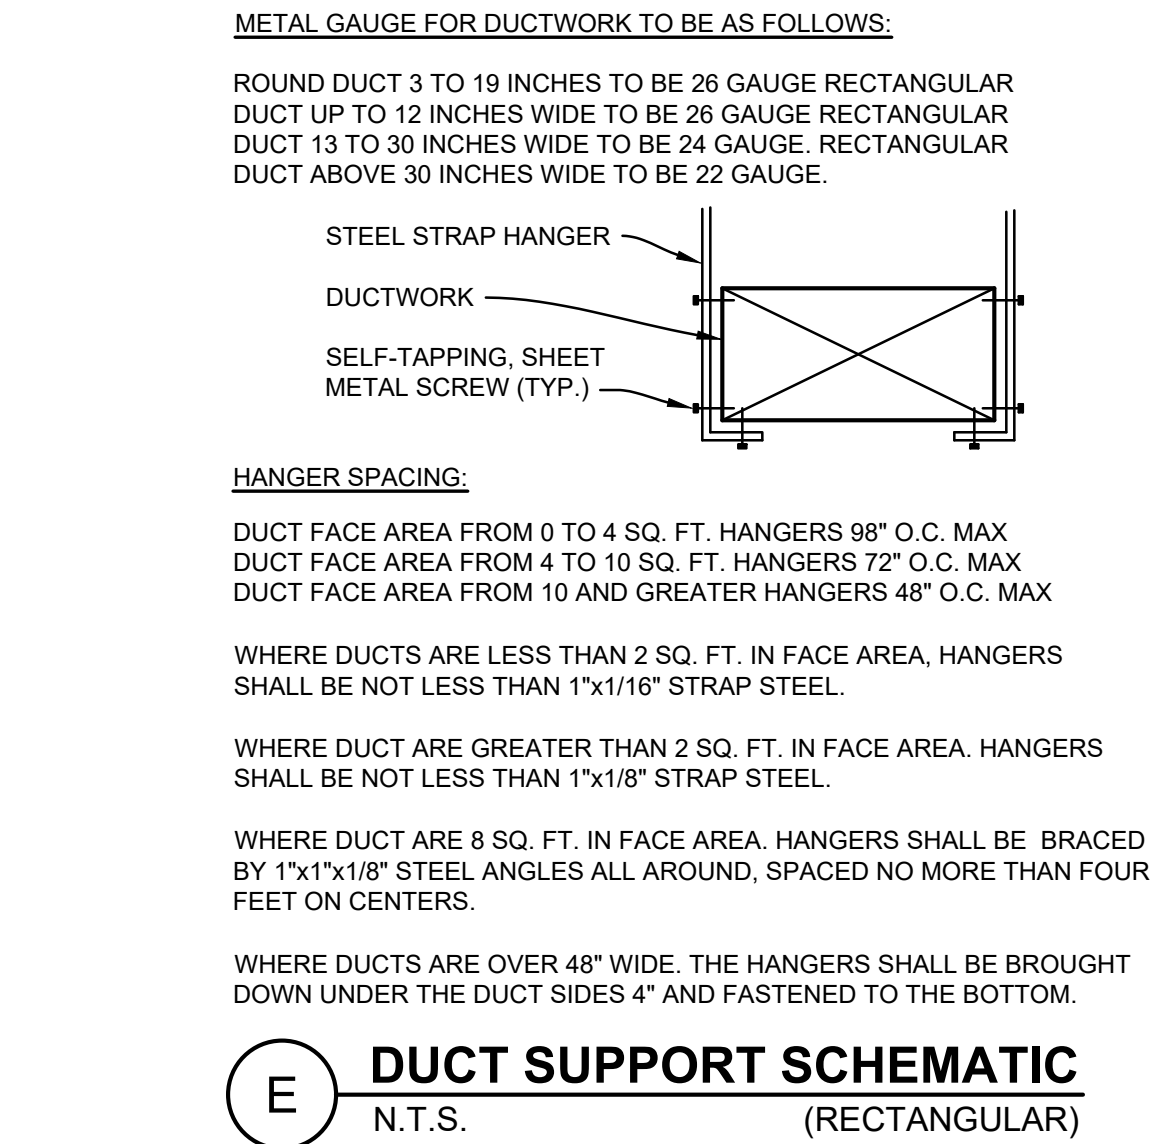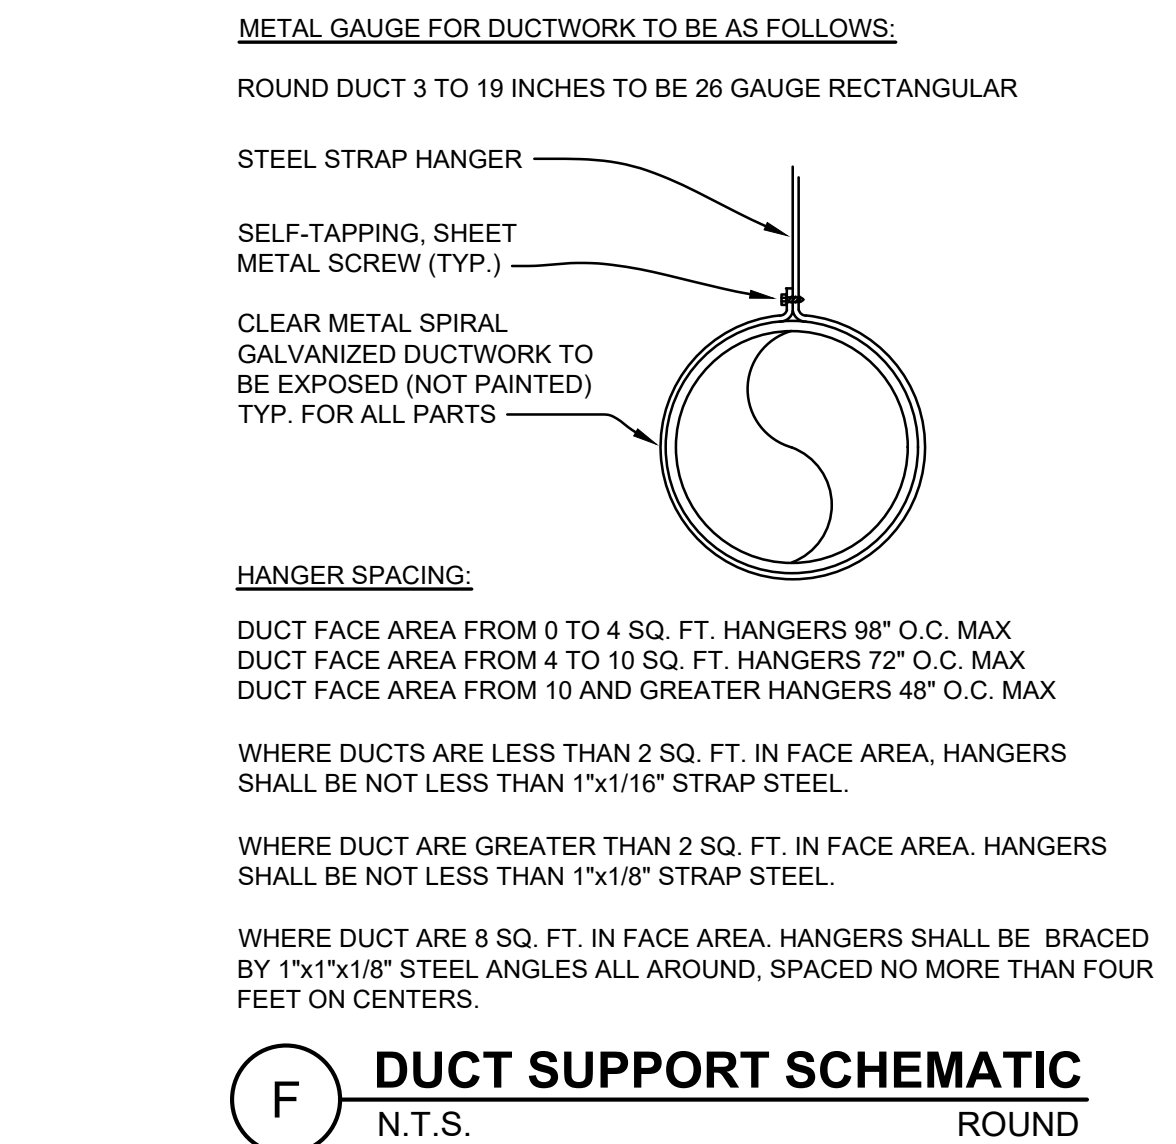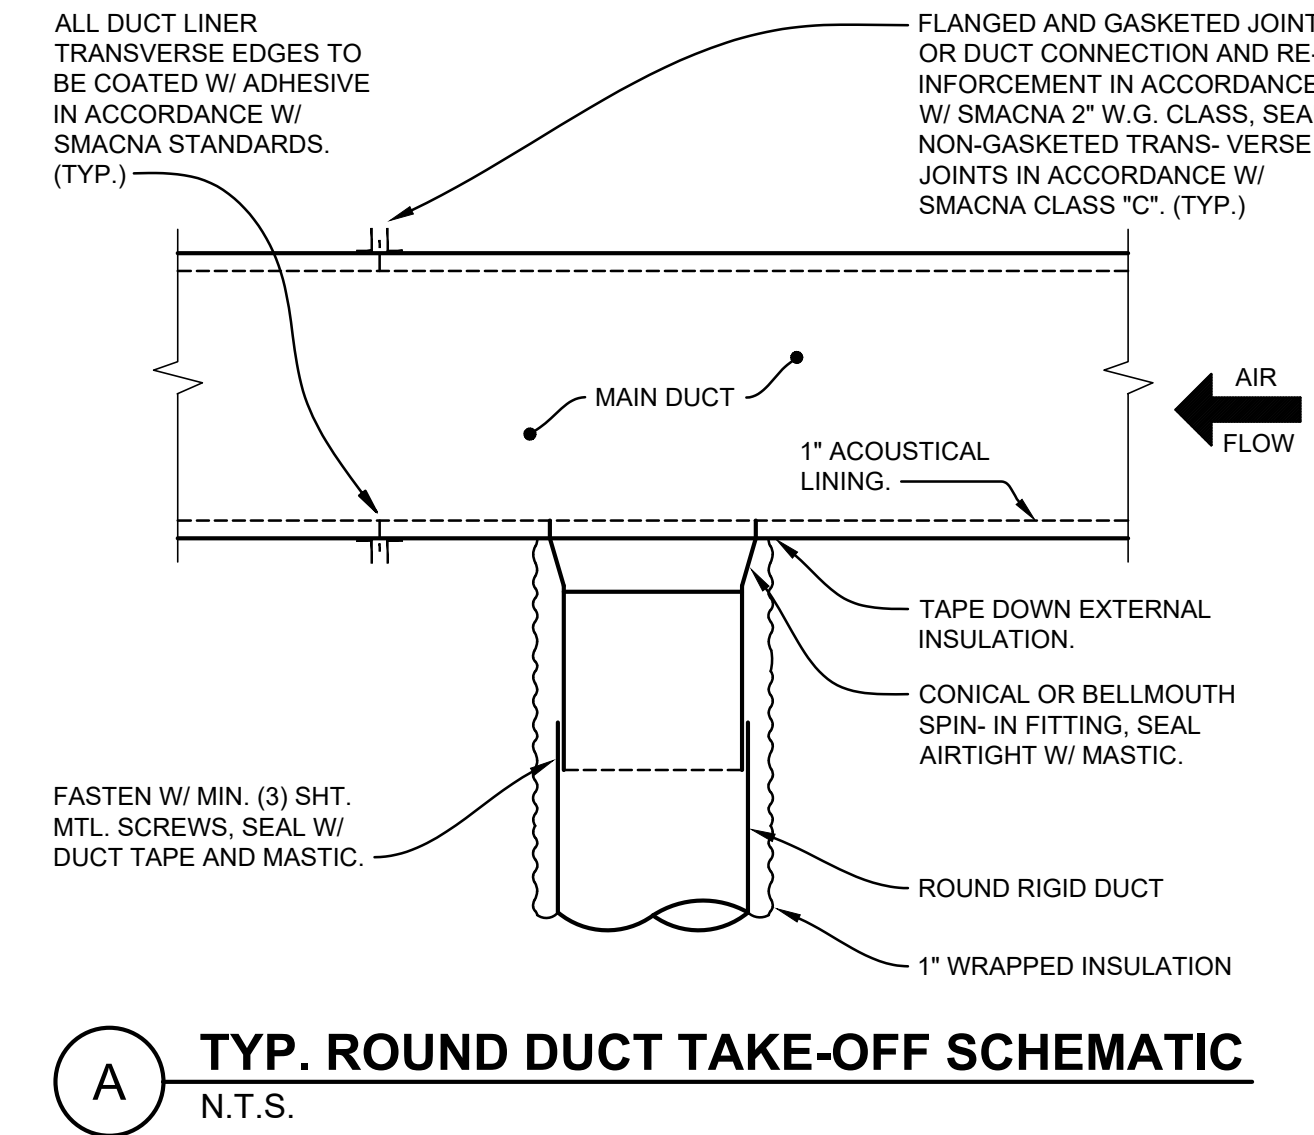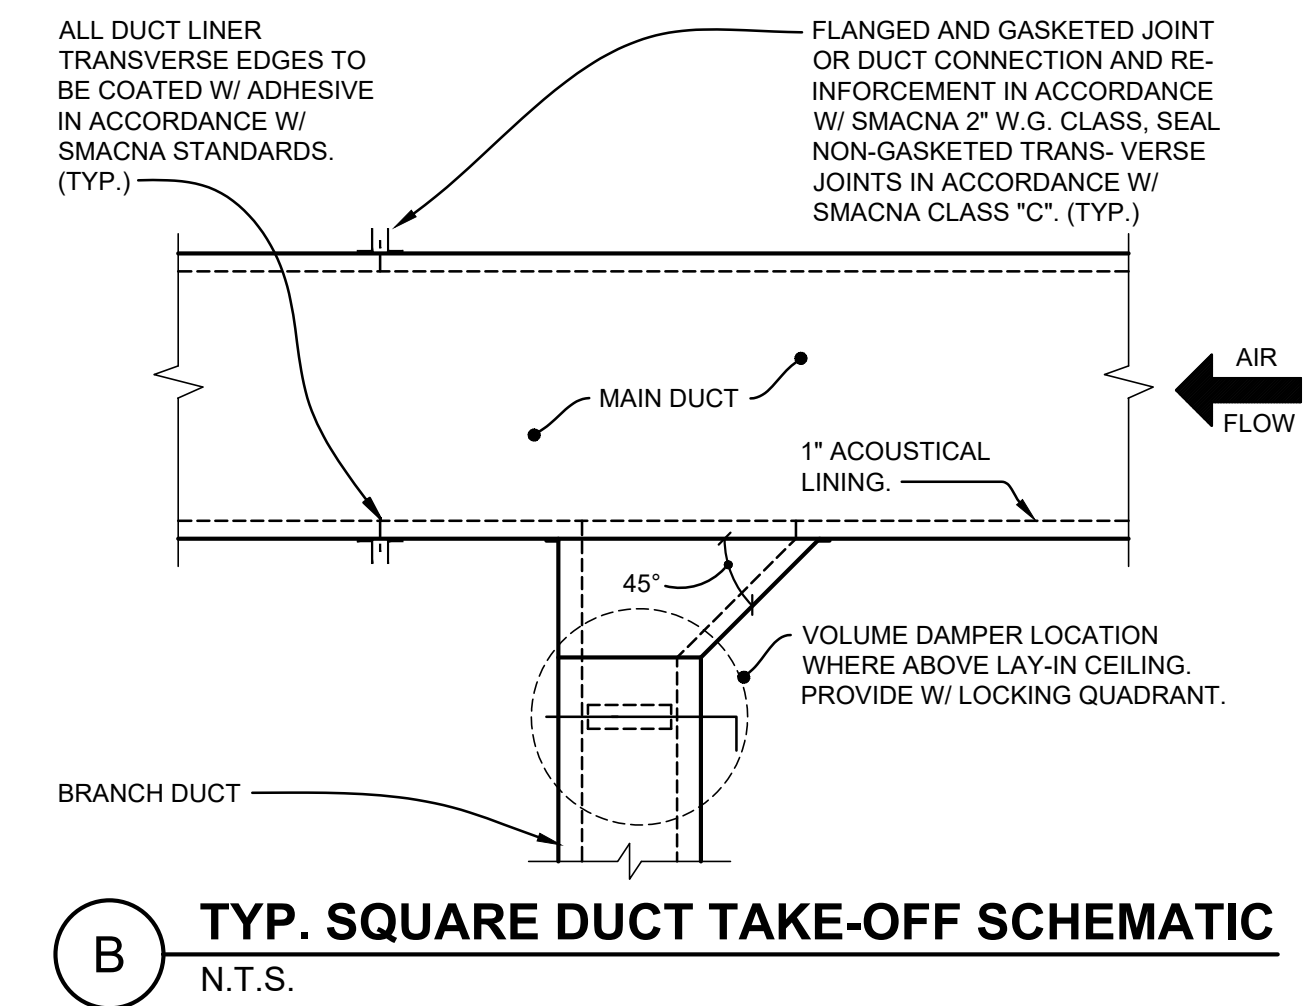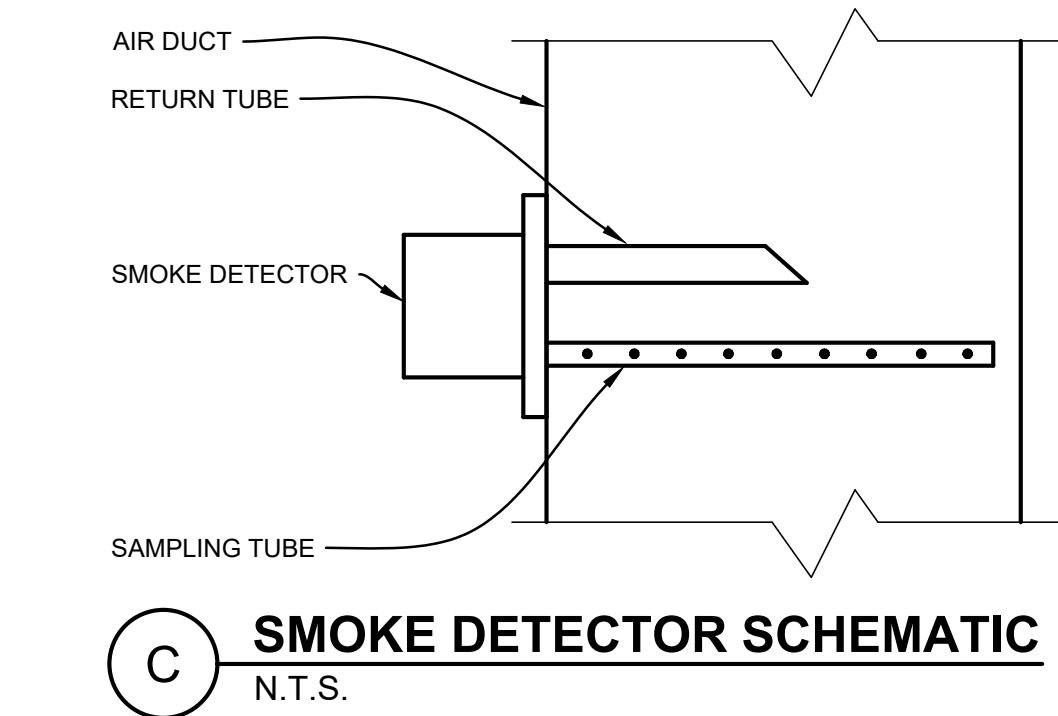

SEAL

DRAWINGS ISSUED

No.	Rev	Date	Description
1		06.18.26	LL REVIEW SET
2		06.25.26	ISSUE FOR PERMIT

PROJECT NAME:

TWP NAPLES



PROJECT ADDRESS:

WATERSIDE SHOPS
5455 TAMiami TRL N
NAPLES, FL 34108

DRAWING TITLE:

MECHANICAL
SCHEMATICS

Project No.	2642110
Scale:	AS NOTED
Date:	05-15-2026
Drawn By:	CAH
Checked BY:	JD

DRAWING NO:

